

# KEY TO SYMBOLS

- 6kw oven supply
- 13 amp double socket
- electrical switch over worktop with concealed socket under
- Lightswitch
- Exterior wall mounted LED movement sensor operated light
- Surface mounted LED downlight
- LED batten light under wall unit
- Shaving Point
- Wash hand basin in vanity unit with LED down lighter over back mirror operated by string pull cord
- CO2 fire extinguisher/ fire blanket mounted on wall brackets
- Television Point
- Control Panel (for Intruder Alarm)
- Smoke Detector
- Heat Detector
- Sounder
- Carbon monoxide Detector
- Emergency Lighting
- Bathroom Extract Fan
- Cooker Hood

- 19.09.25 LIFT AMENDED, SECTION LINES ADDED
- 09.09.25 PARTITIONS AMENDED, DETAIL ADDED
- 22.08.25 WALL DEPTH AMENDED
- 23.07.25 LIFT AND DUCTS MOVED, SETTING OUT AMENDED FOR INTRASTACK, PLANT ROOM MADE BIGGER
- 08.07.25 WINDOW W148 REMOVED
- 06.07.25 WALL ALONG GLA BETWEEN GL1 AND GL4 MOVED 150mm BACK TOWARD GLB
- 23.06.25 LIFT AND LOBBY AMENDED, FF SLAB OVER RETAIL RE-SET AT ORIGINAL LEVEL, DOWN-PIPES MOVED BACK TO INSIDE
- 09.05.25 INTRASTACK GRID ADDED, DRAINAGE SCHEMATIC ADDED
- 28.05.25 W137 REMOVED, W138 TO W141 AND ADJACENT WALL MOVED
- 18.03.25 WINDOW POSITIONS AMENDED ALONG DRAKE STREET ELEVATION
- 17.03.25 WALLS AMENDED TO ALIGN WITH GF AND ALONG GL C2 TO OUTER WALL
- 05.03.25 WALLS ALONG GRID LINE A AMENDED
- 20.02.25 WINDOW AND EXTERNAL DOOR REFERENCES ADDED

REV. DATE. DETAILS

BM ARCHITECTURAL DESIGNS  
APARTMENT 8  
224 GREAT CLOWES STREET  
MANCHESTER M7 2ZS  
TEL: 07415 493002

PROJECT: NEW BUILDING,  
42-46 DRAKE STREET  
AND NELSON STREET,  
ROCHDALE OL16 1NU


CLIENT: CASSEL AND FLETCHER  
PROPERTY LTD

TITLE: FIFTH FLOOR PLAN

SCALE: 1:50@A1 DATE: 02/ 2025 DRAWN:

STATUS: CONSTRUCTION


DRAWING NO: BM/0225/DRAKE/BR7 REV: 0

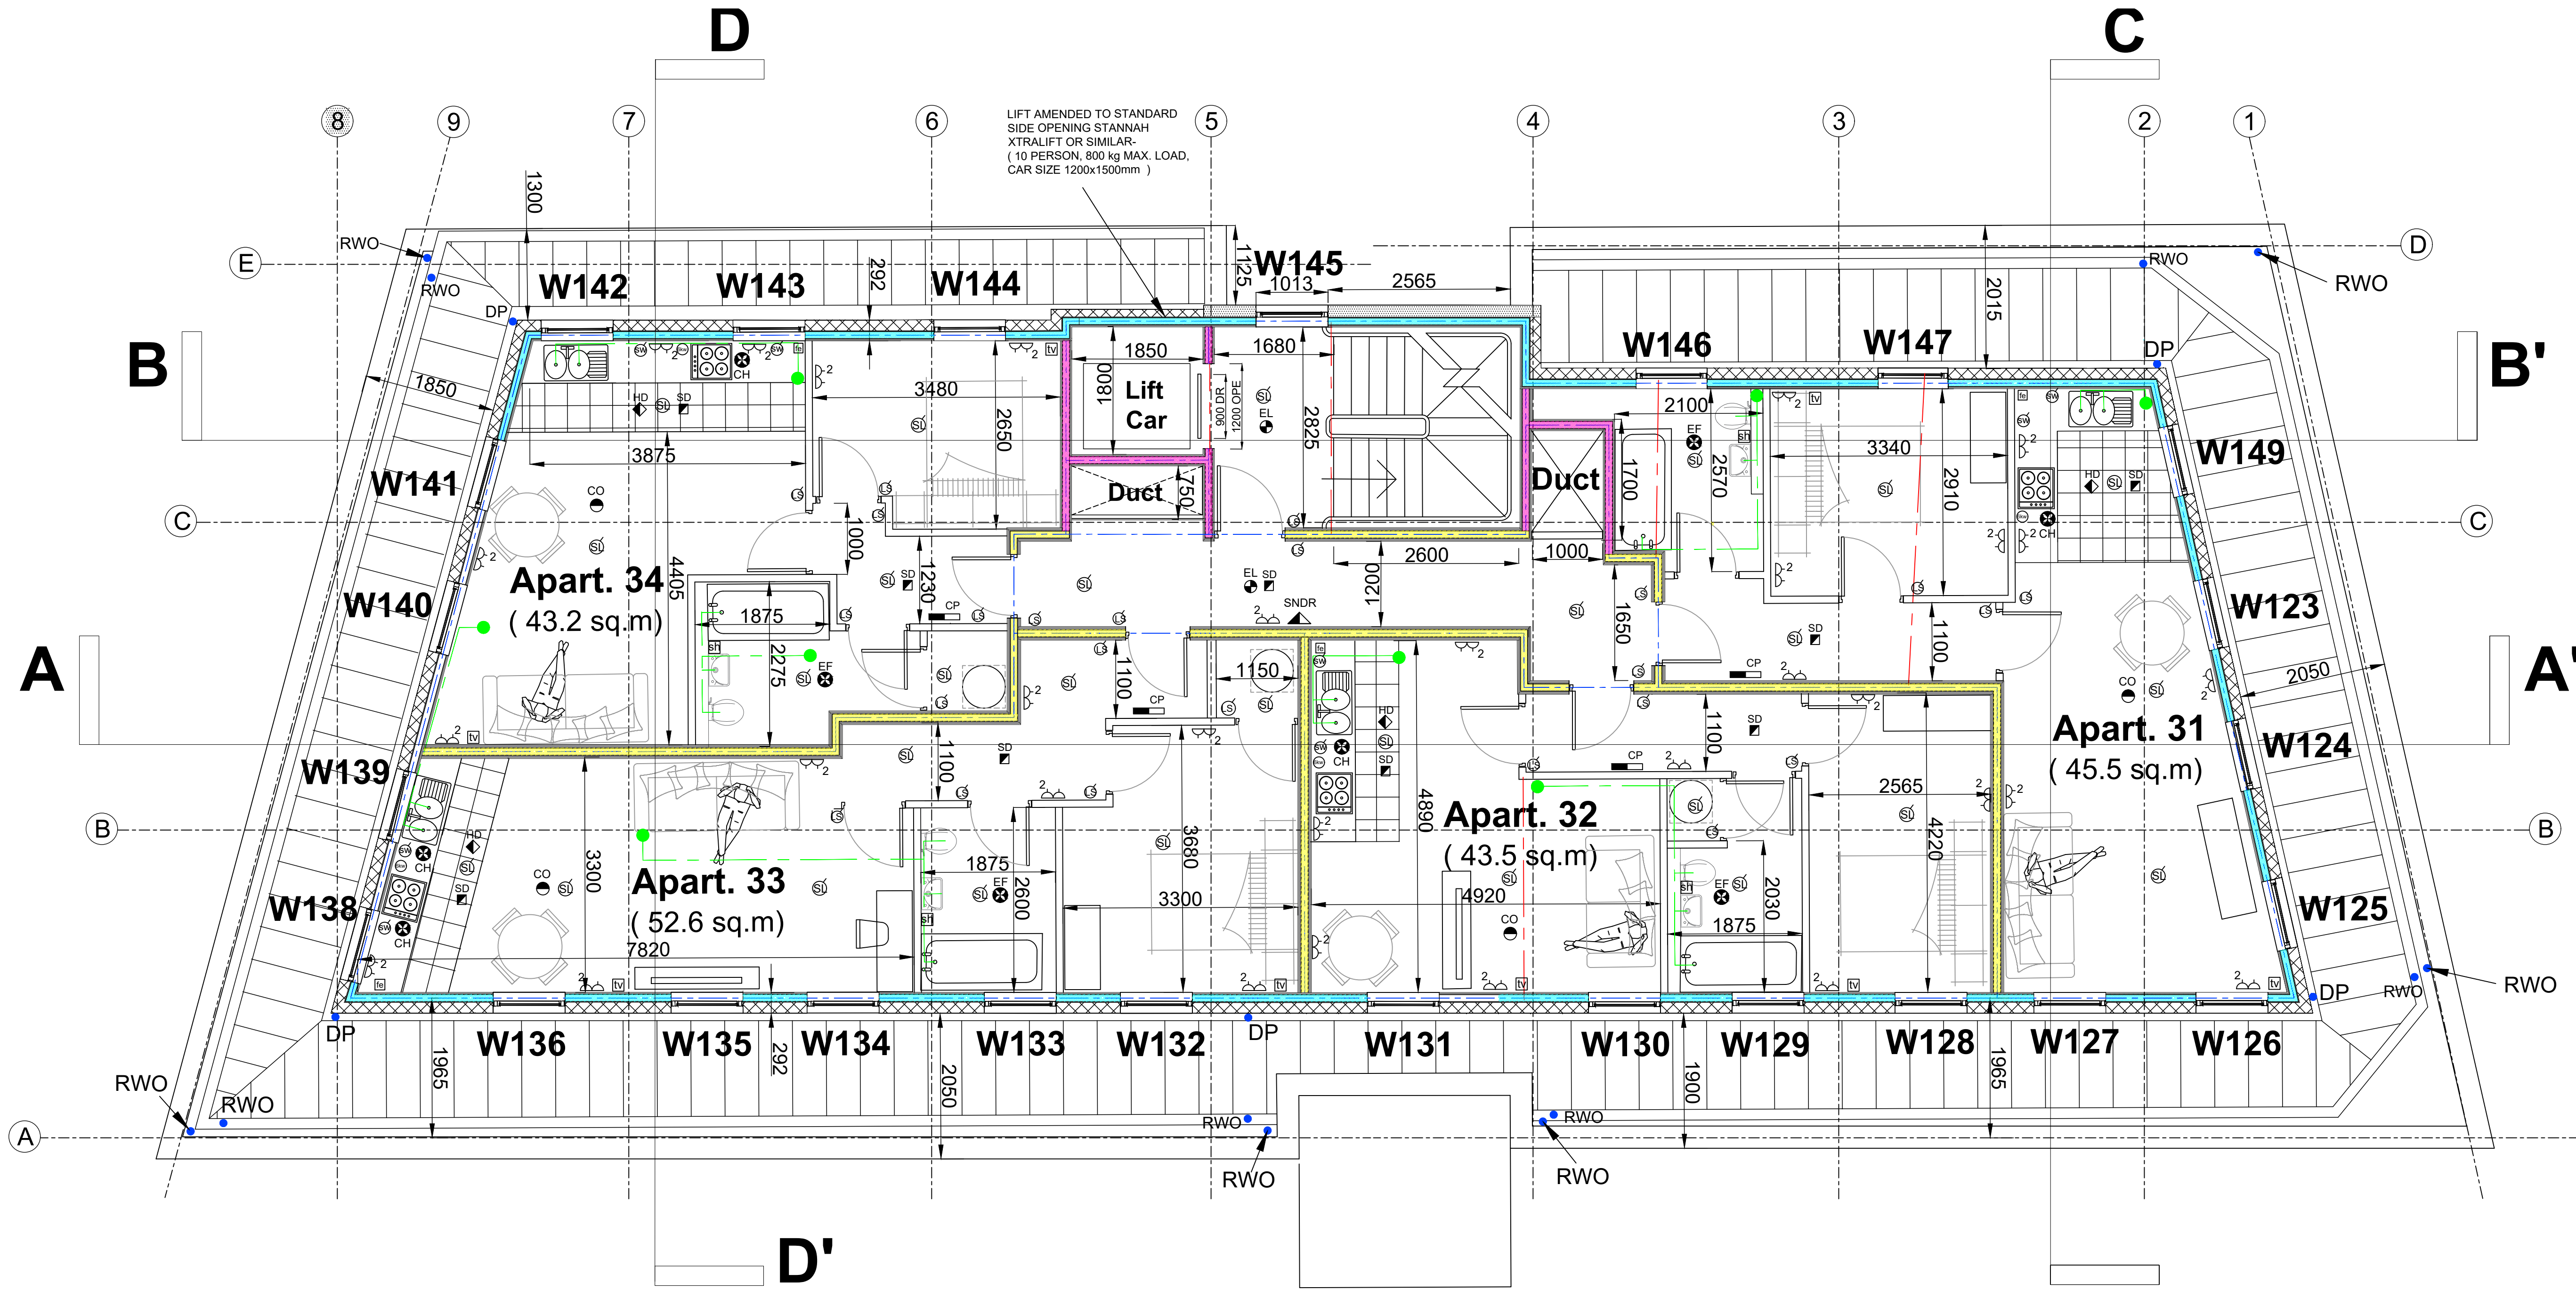


## FIFTH FLOOR PLAN

0 2 4 6m

### EXTERNAL WALL

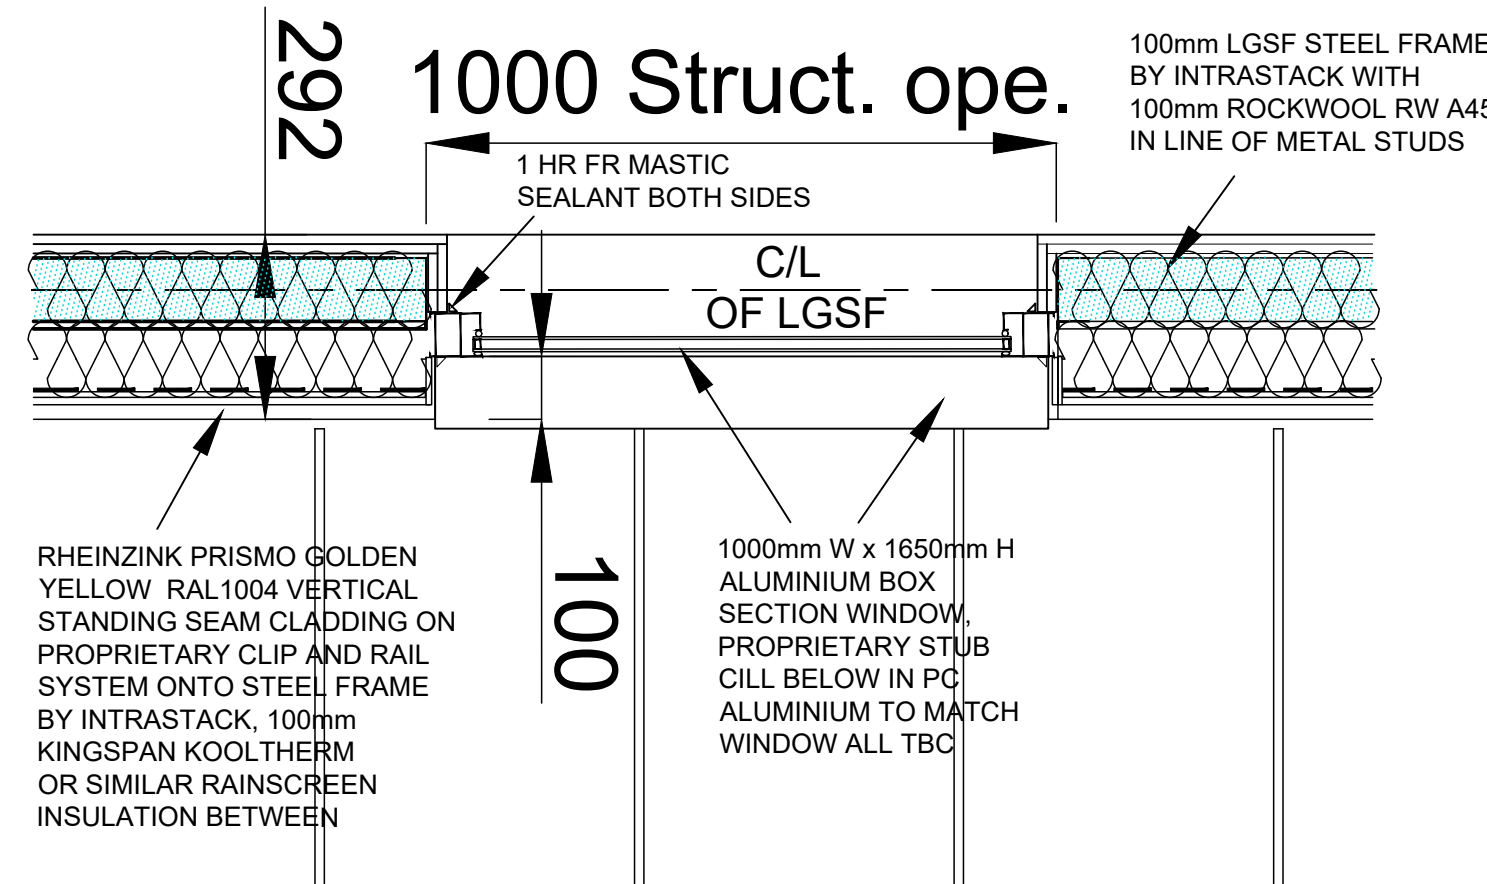

### INTERNAL PARTITION WALL TYPES

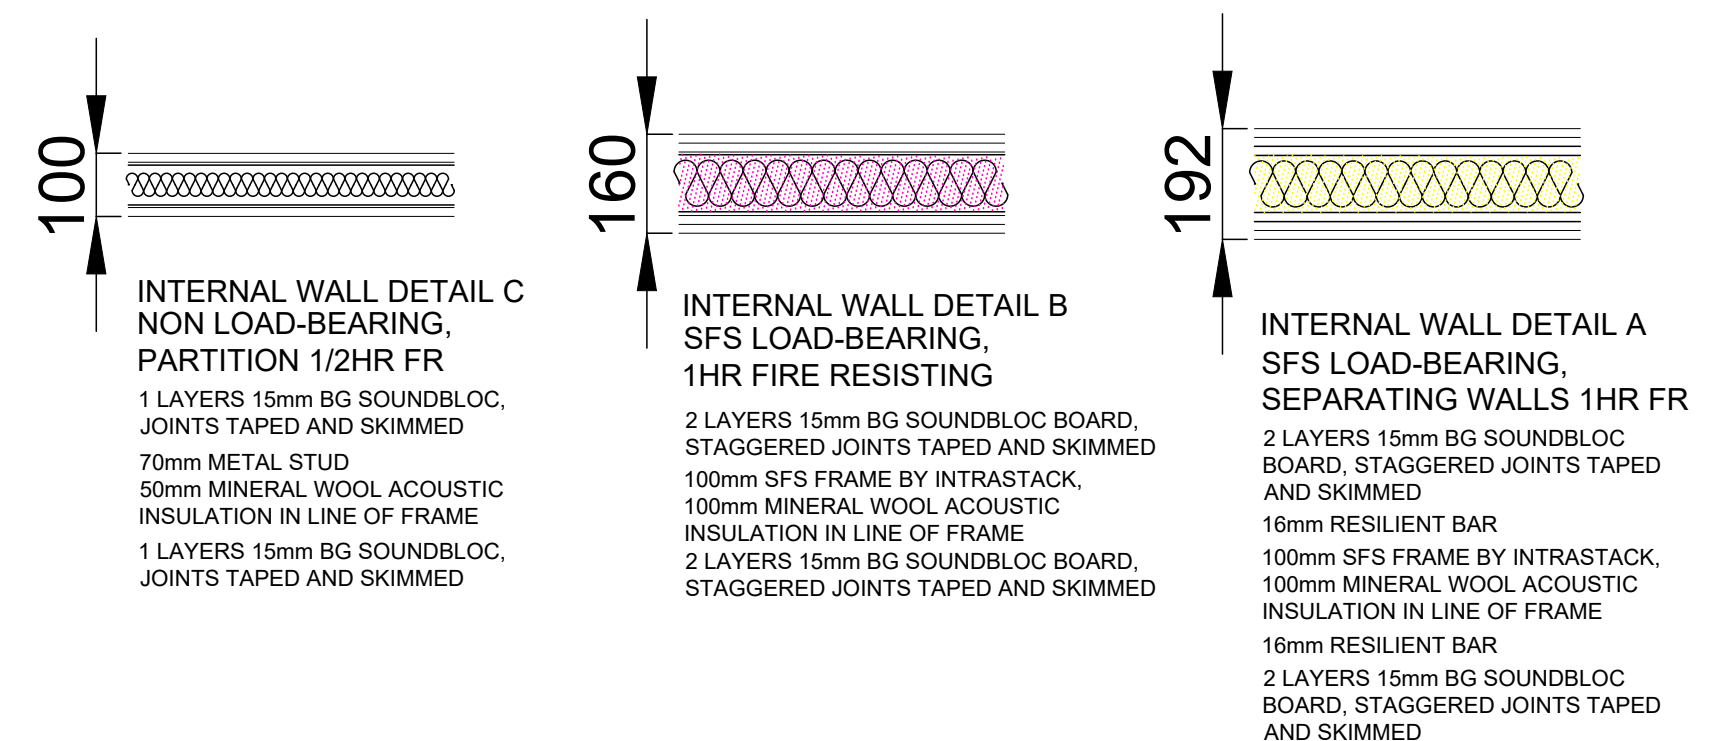

C/L  
OF LGSF