


LIGHTING LEGEND

-  ANSELL LUPPA BLACK 16W WALL LIGHT
-  ANSELL LUPPA BLACK 16W WALL LIGHT WITH INTEGRATED EMERGENCY
-  EMERGENCY EXTERNAL BULKHEAD FITTING
-  PHOTO ELECTRIC CELL (EXTERNAL LIGHTING CONTROL)

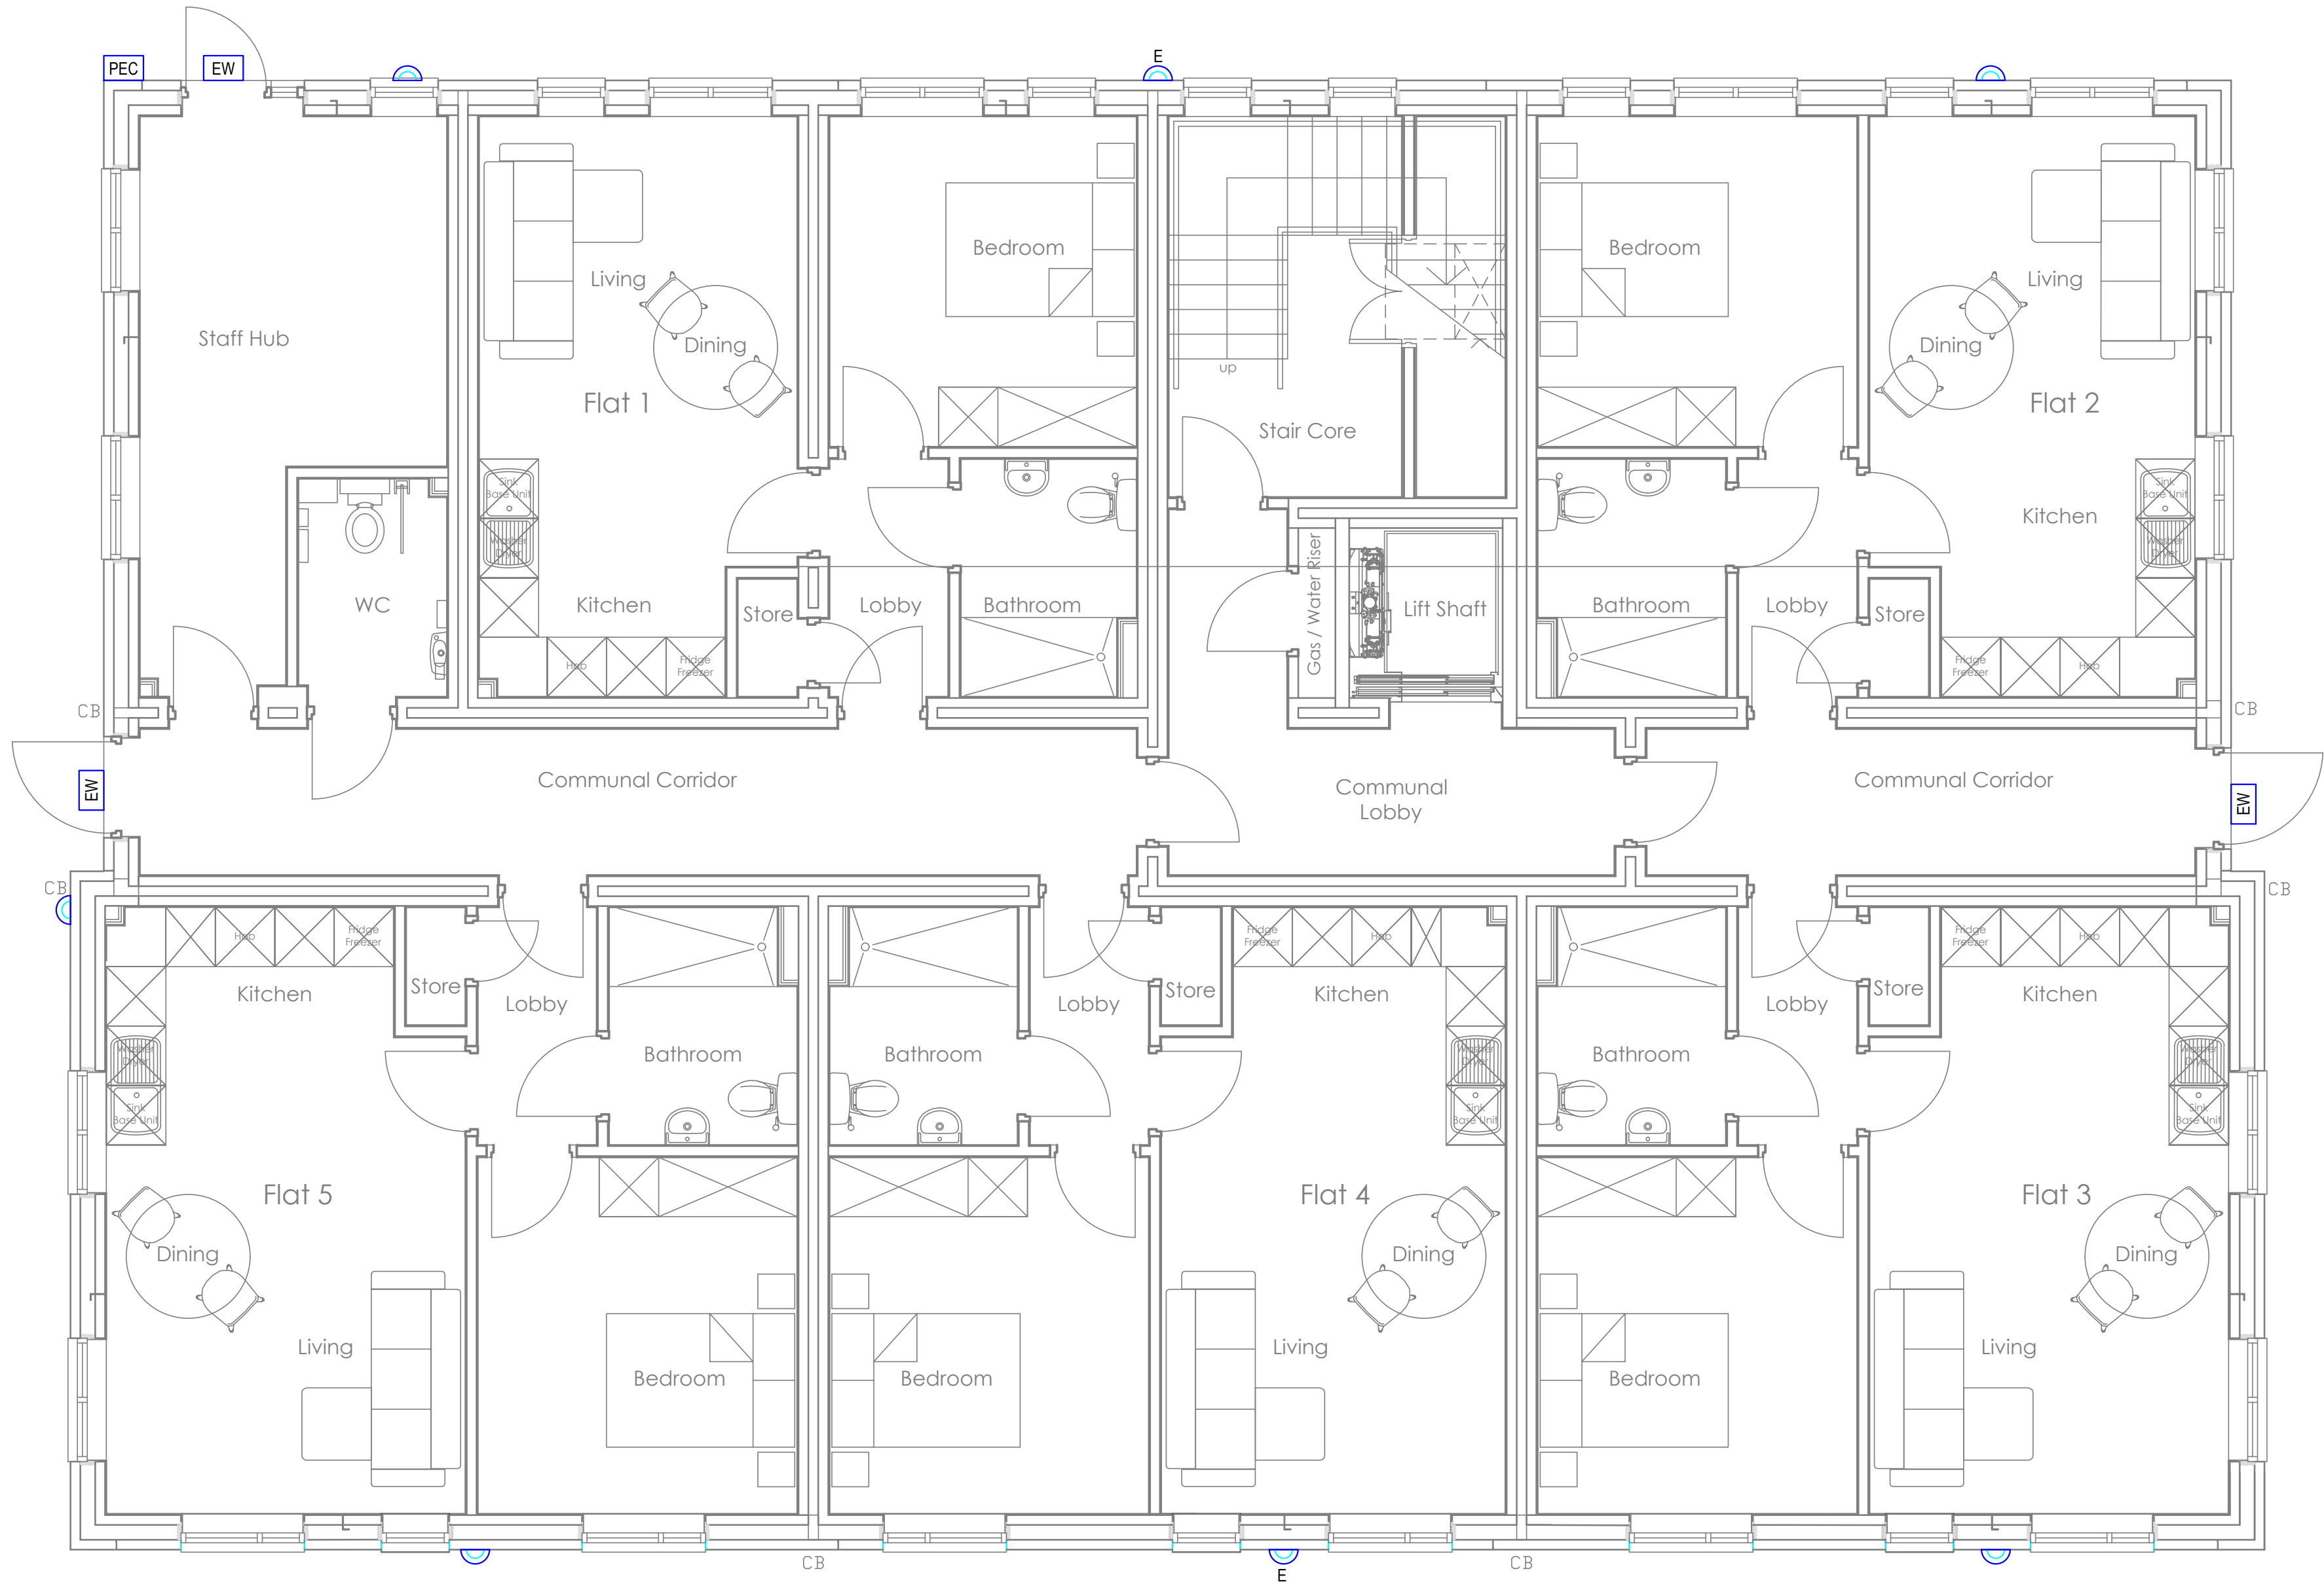

C01	ISSUED FOR CONSTRUCTION	28/10/25
Rev	Description	Date

LNC Electrical Services

LNC ELECTRICAL SERVICES LTD,
53 THE HILL,
GLAPWELL,
CHESTERFIELD,
DERBYSHIRE,
S44 5LX.

Status:
CONSTRUCTION ISSUE

Client:
URBAN WAVE

Project:
**CARE HOME DEVELOPMENT
7 STARKEY STREET
HEYWOOD**

Drawing Title:
**ELECTRICAL SERVICES
BLOCK A - GROUND FLOOR
EXTERNAL LIGHTING LAYOUT**

Scale: 1:50 (A1)	Project No: -	Date: 28/10/2025
Drawn: IRC	Checked: LS	Approved: LC
Drawing Number: LNC-SSH01-BA-20-01	Rev: C01	