



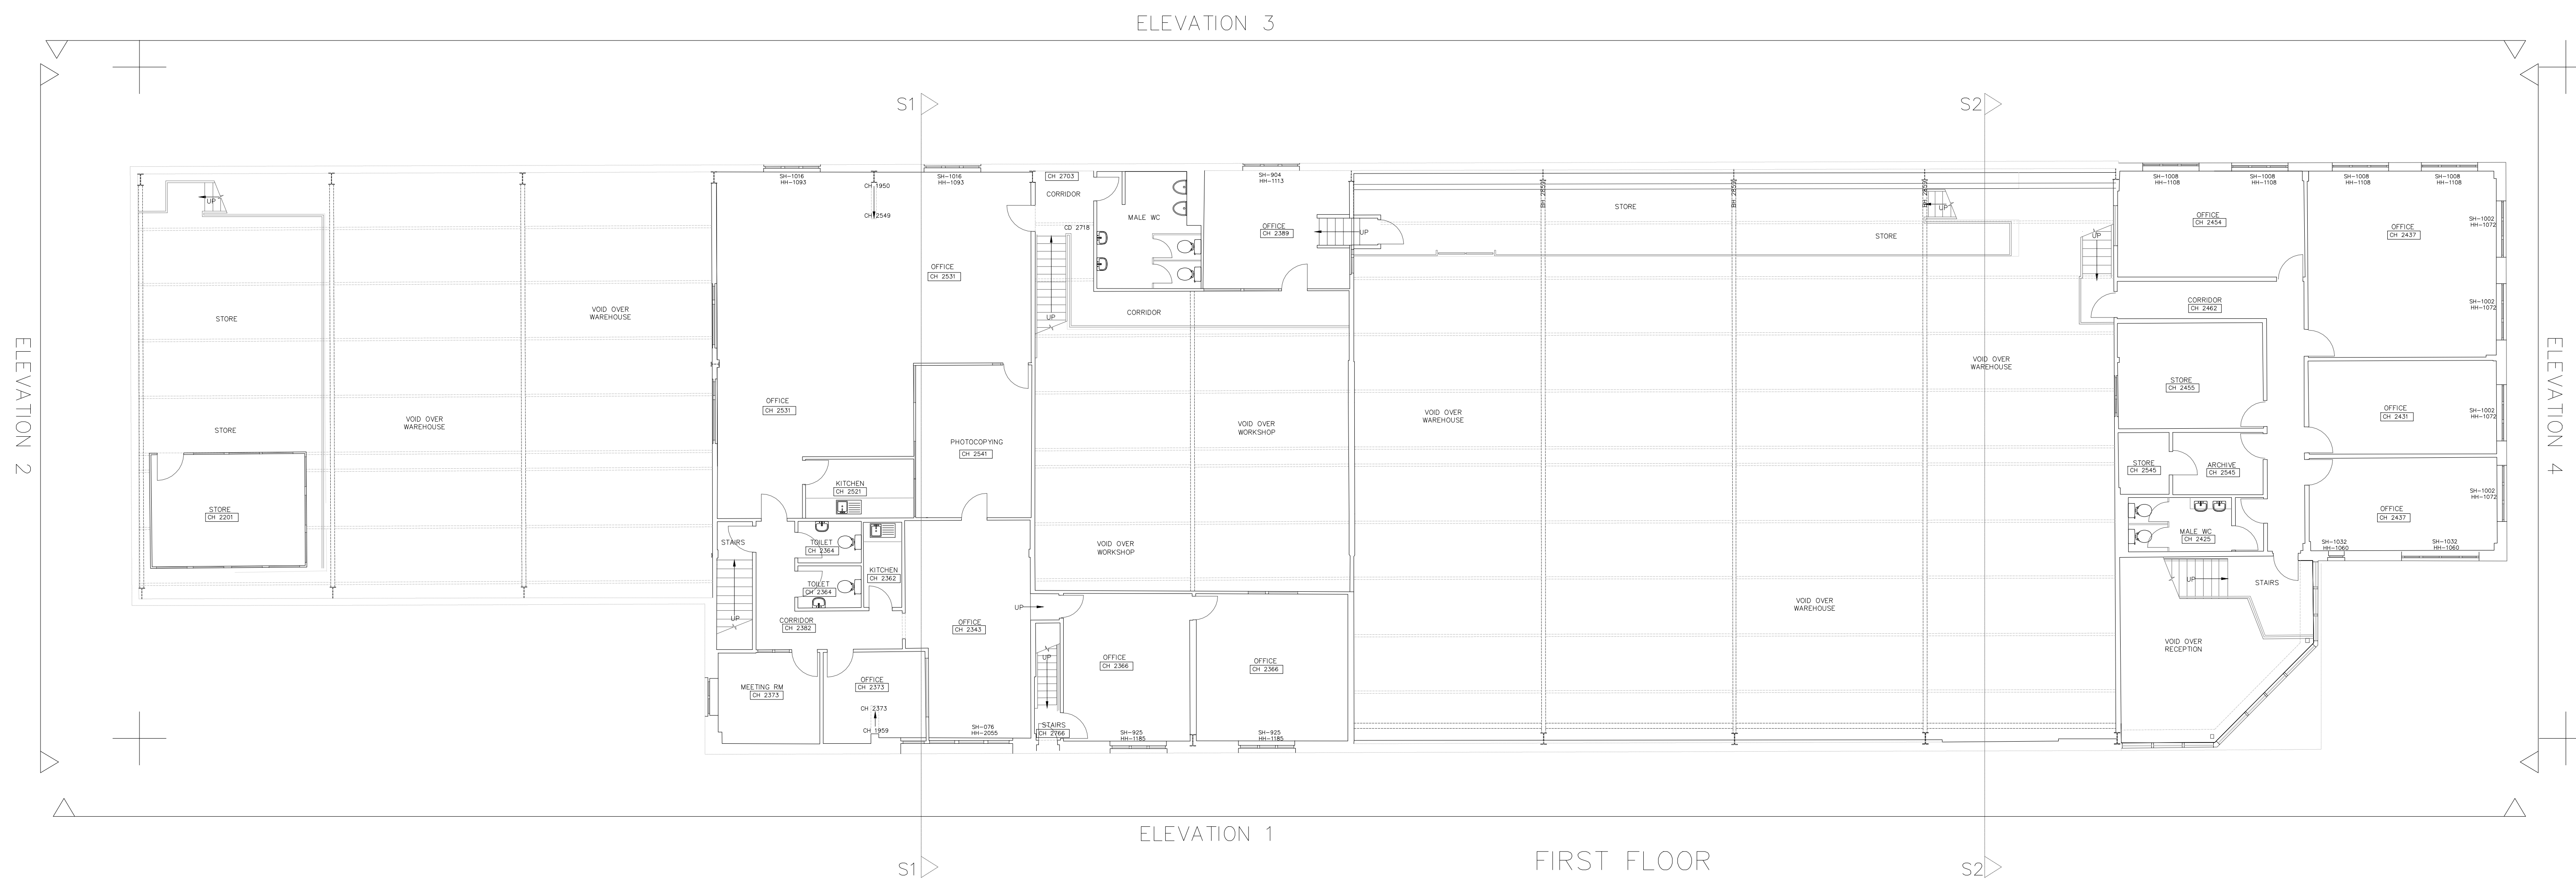

Abbreviations/Symbols (Measured Building Surveys):	
C:	Window Cill Height
H:	Window Head Height
BH:	Beam Height
DH:	Door Height
COL:	Column
SVP:	Soil Vent Pipe
FL:	Floor Level
TH:	Threshold Level
6.50	Floor to Ceiling Height
	Vaulted Ceiling
Line Types	
	Hedge Lines
	Drainage Runs
	Overhead Electricity Cables
	Overhead Telephone Cables
Symbols	
	Tree/Bush
	Control Station
	Borehole
	Trial Hole
	Glass House
	Osbn
Abbreviations (Topographic Survey):	
AH:	Arch Height
AV:	Air Valve
BB:	Bellish Beacon
BOX:	Electricity Box, Cables Box, Etc.
BO:	Bolard
BT/IC:	British Telecom Inspection Chamber
BS:	Bus Stop
BS/LP:	Bus Stop / Lamp Post
CATV:	CATV Inspection Chamber
CCTV:	Closed Circuit Television
CL:	Cellar Light
C.PIT:	Catch Pit
ER:	Earth Rod
EC:	Electricity Inspection Chamber
EP:	Electricity Pole
FH:	Fire Hydrant
FP:	Flag Pole
GV:	Gas Valve
G:	Gully
IC:	Inspection Chamber
KO:	Kerb Outlet
LP:	Lamp Post
LB:	Letter Box
LC:	Lighting Column
MKR:	Marker
MH:	Manhole
MP:	Moorings Point
MS:	Mile Stone
NYNEX:	Nynex Inspection Chamber
O/H:	Over Hang
P:	Post
PO/IC:	Post Office Inspection Chamber
R/S:	Road Sign
RE:	Rodding Eye
RTW:	Retaining Wall
S/P:	Sign Post
SNP:	Street Name Plate
ST:	Stop Tap
SV:	Stop Valve
T:	Telecom Inspection Chamber
TOB:	Telephone Call Box
TH:	Threshold Level
TL:	Traffic Light
TP:	Telegraph Pole
TROUGH:	Trough
WO:	Water Outlet
WM:	Water Meter
Fence Descriptions:	
B/W:	Barbed Wire
C/B:	Close Boarded
C/BARRIER:	Crash Barrier
C/L:	Chain Link
C/P:	Chestnut Paling
C/I:	Corrugated Iron
I/R:	Iron Railing
MISC:	Miscellaneous
P/R:	Post & Rail
P/W:	Post & Wire
P/C:	Post & Chain
S/PAL:	Steel Palisade
W/M:	Wire Mesh

Survey Notes:
Coordinates and Levels related to Ordnance Survey Datum – GPS 050B36


Revision	Date	Description

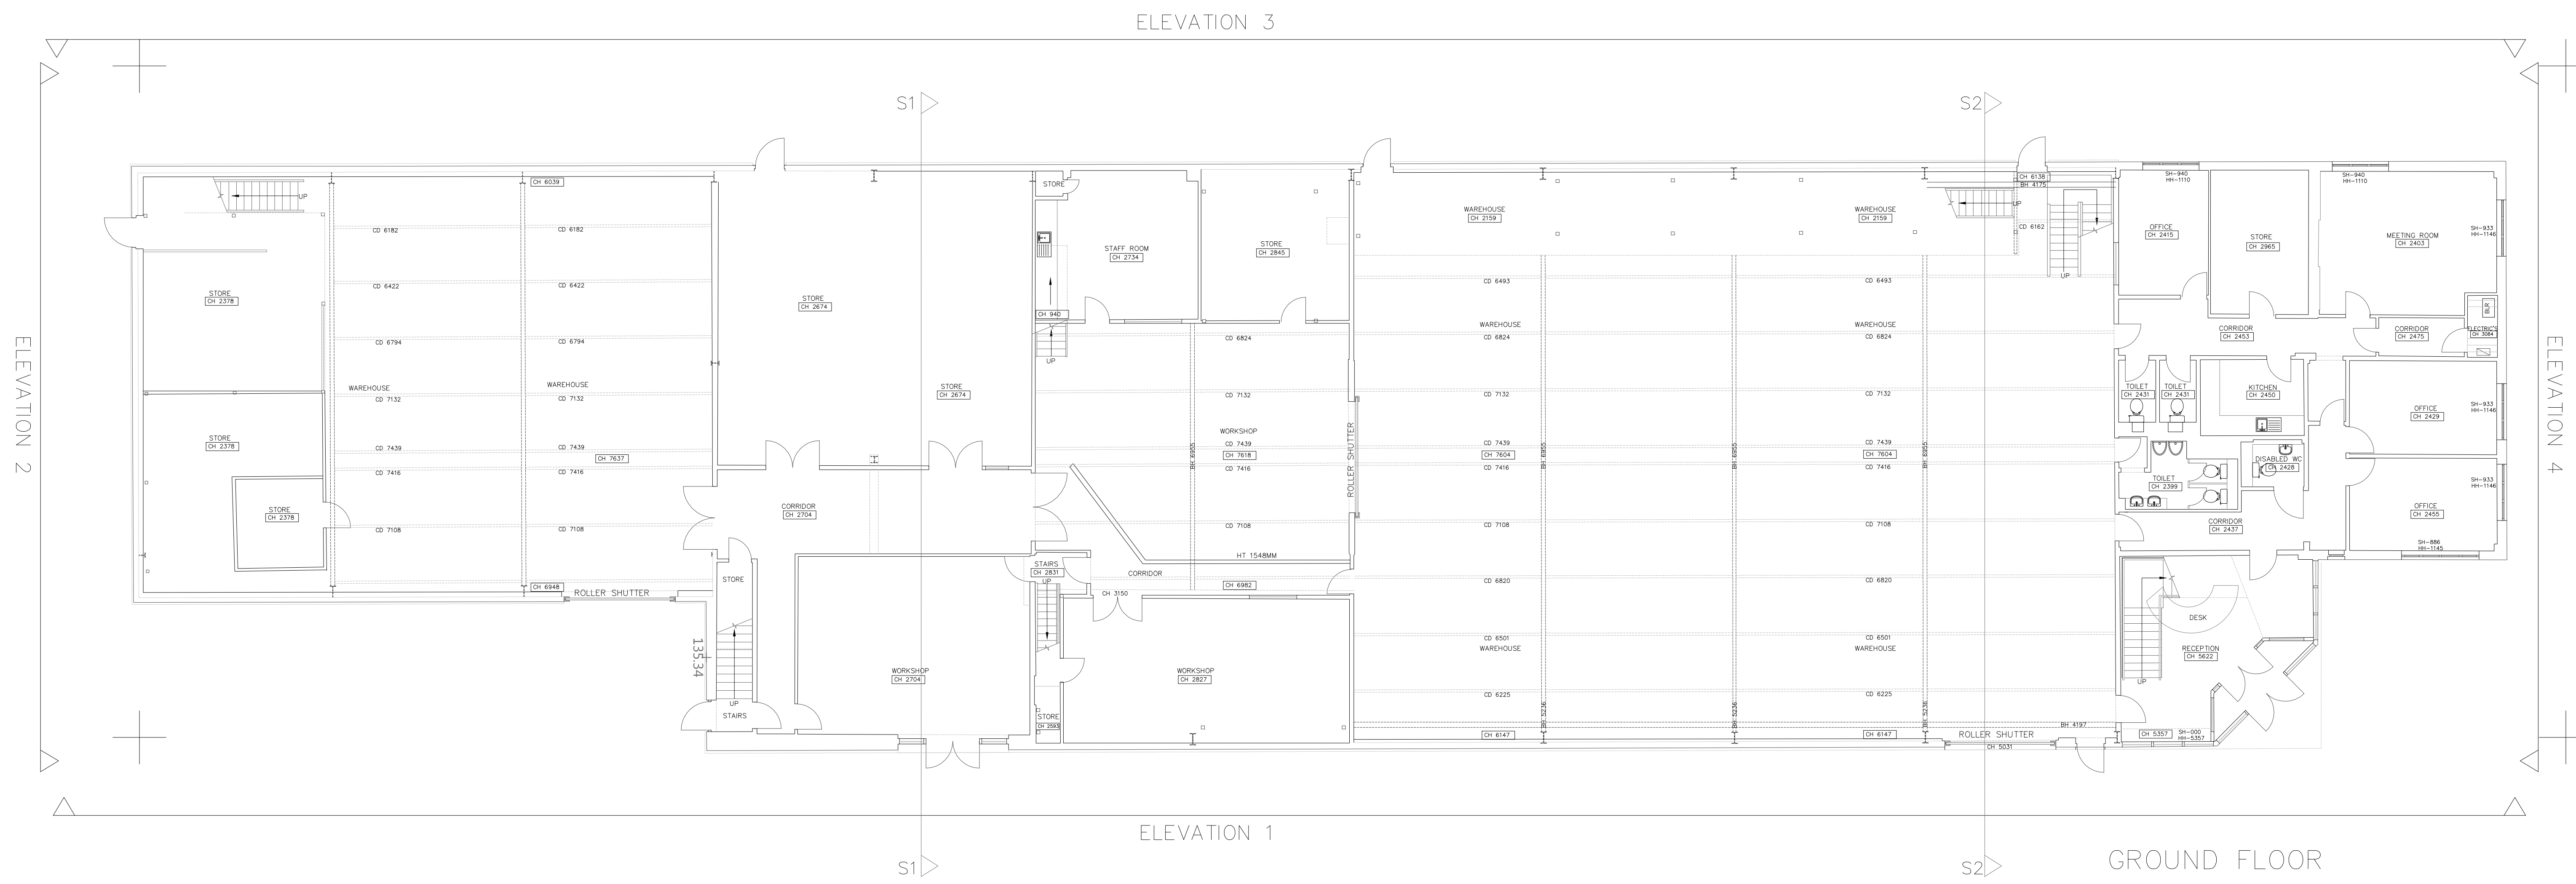

Chris Partington Land Surveyors

44a Green Lane
Sale
Cheshire
M33 5PP
t: 0161 976 1194
www.cpls.co.uk e: survey@cpls.co.uk


Client	
A J Cocker Associates	
Project	
R & B Switchgear, Heywood Floor Plans	
Scale	1:100
Surveyed By	W M
Date	16.08.21
Drawing No.	160821WM-01
Checked By	CPLS
Date	20.08.21
Drawn By	H H
Date	20.08.21

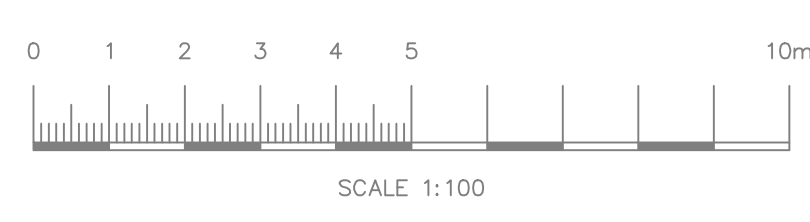




Datum 130M

ELEVATION 1

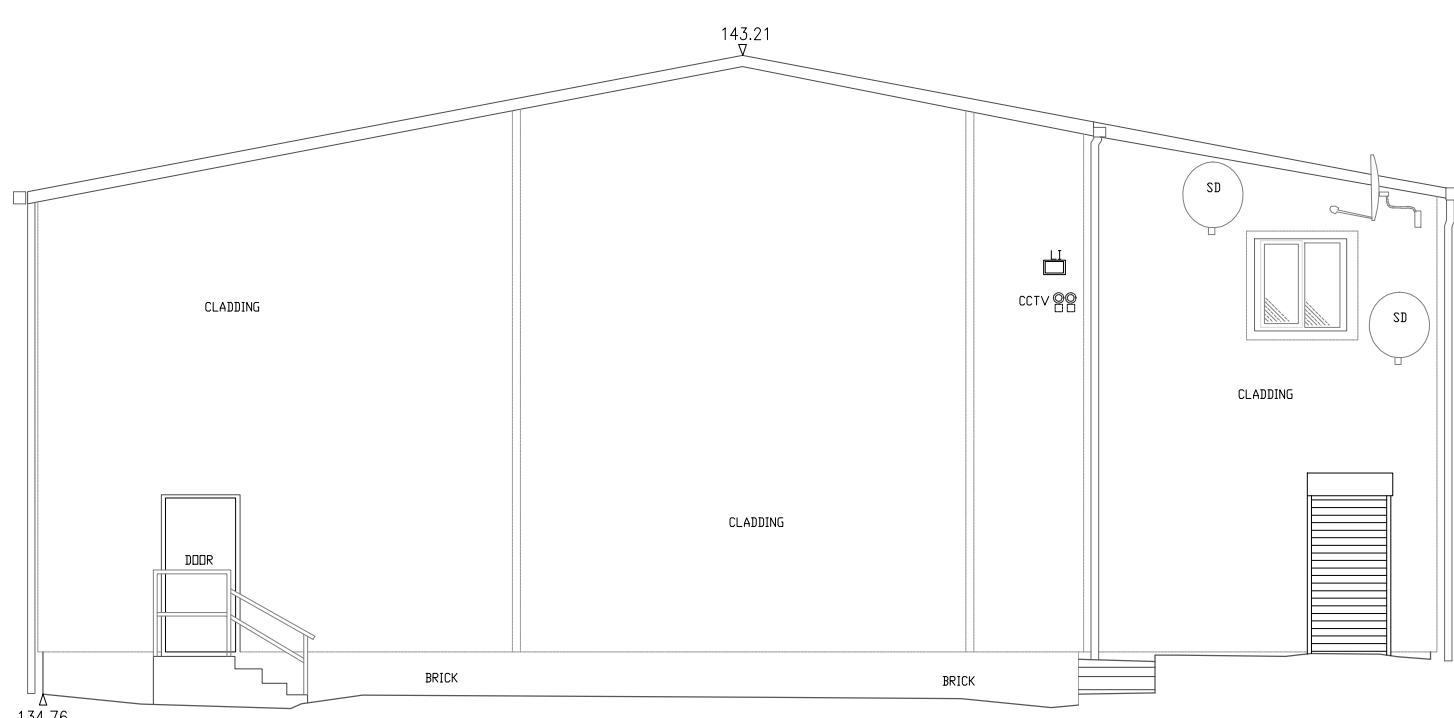

Datum 130M

ELEVATION 2

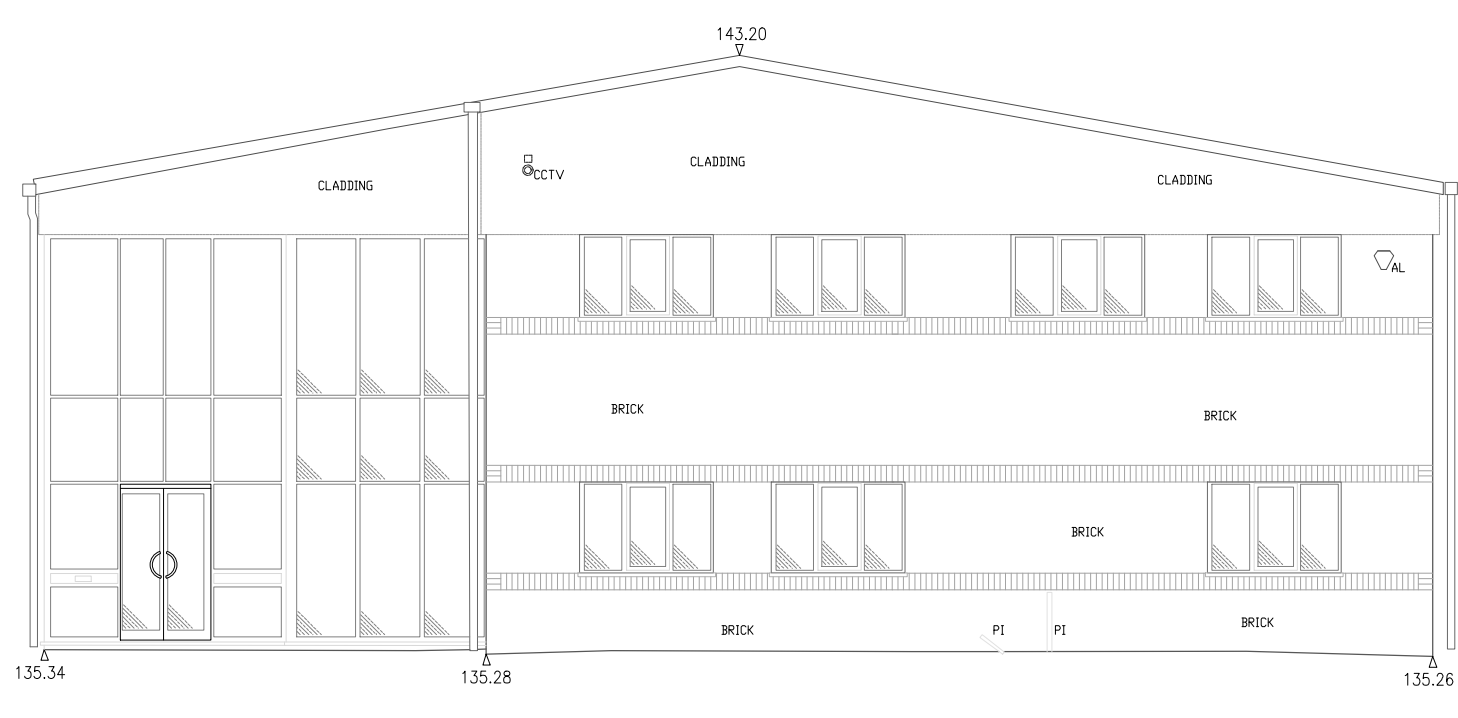

Datum 130M

ELEVATION 4



Datum 130M

ELEVATION 3

Abbreviations/Symbols (Measured Building Surveys):

C:	Window Cill Height
H:	Window Head Height
BH:	Beam Height
DH:	Door Height
COL:	Column
SVP:	Soil Vent Pipe
FL:	Floor Level
TH:	Threshold Level
6.50	Floor to Ceiling Height
(Symbol)	Vaulted Ceiling

Line Types

(Symbol)	Hedge Lines
(Symbol)	Drainage Runs
(Symbol)	Overhead Electricity Cables
(Symbol)	Overhead Telephone Cables

Symbols

(Symbol)	Tree/Bush	(Symbol)	Glass House
(Symbol)	Control Station	(Symbol)	Osbn
(Symbol)	Borehole		
(Symbol)	Trial Hole		

Abbreviations (Topographic Survey):

AH:	Arch Height
AV:	Air Valve
BB:	Belisha Beacon
BOX:	Electricity Box, Cables Box, Etc.
BO:	Bollard
BT/IC:	British Telecom Inspection Chamber
BS:	Bus Stop
BS/LP:	Bus Stop / Lamp Post
CATV:	CATV Inspection Chamber
CCTV:	Closed Circuit Television
CL:	Cellar Light
C.PIT:	Catch Pit
ER:	Earth Rod
EC:	Electricity Inspection Chamber
EP:	Electricity Pole
FH:	Fire Hydrant
FP:	Flag Pole
GV:	Gas Valve
G:	Gully
IC:	Inspection Chamber
KO:	Kerb Outlet
LP:	Lamp Post
LB:	Letter Box
LC:	Lighting Column
MKR:	Marker
MH:	Manhole
MP:	Mooring Point
MS:	Mile Stone
NYNEX:	Nynex Inspection Chamber
O/H:	Over Hanging
P:	Post
PO/IC:	Post Office Inspection Chamber
R/S:	Road Sign
RE:	Rodding Eye
RTW:	Retaining Wall
S/P:	Sign Post
SNP:	Street Name Plate
ST:	Stop Tap
SV:	Stop Valve
T:	Telecom Inspection Chamber
TCB:	Telephone Call Box
TH:	Threshold Level
TL:	Traffic Light
TP:	Telegraph Pole
TROUGH:	Trough
WO:	Water Outlet
WM:	Water Meter

Fence Descriptions:

B/W:	Barbed Wire
C/B:	Close Boarded
C/BARRIER:	Crash Barrier
C/L:	Chain Link
C/P:	Chestnut Paling
C/I:	Corrugated Iron
I/R:	Iron Railing
MISC:	Miscellaneous
P/R:	Post & Rail
P/W:	Post & Wire
P/C:	Post & Chain
S/PAL:	Steel Palisade
W/M:	Wire Mesh

Survey Notes:

Coordinates and Levels related to Ordnance Survey Datum – GPS OSGB36

Revision	Date	Description


CPLS
Chris Partington Land Surveyors
44a Green Lane
Sale
Cheshire
M33 5PP
t: 0161 976 1194
www.cpls.co.uk e: survey@cpls.co.uk






Client
A J Cocker Associates

Project
R & B Switchgear, Heywood Elevations

Scale 1:100	Surveyed By W M	Date 16.08.21
Drawing No. 160821WM-02	Checked By CPLS	Date 20.08.21
	Drawn By H H	Date 20.08.21

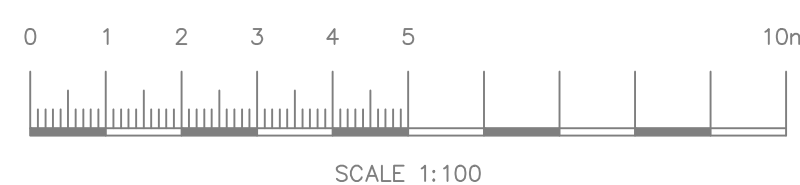

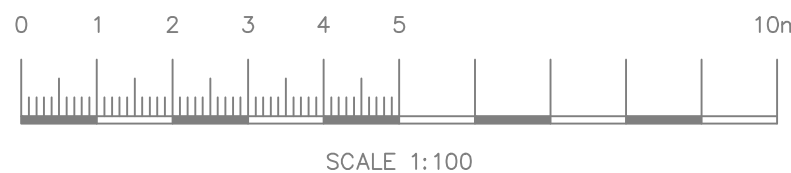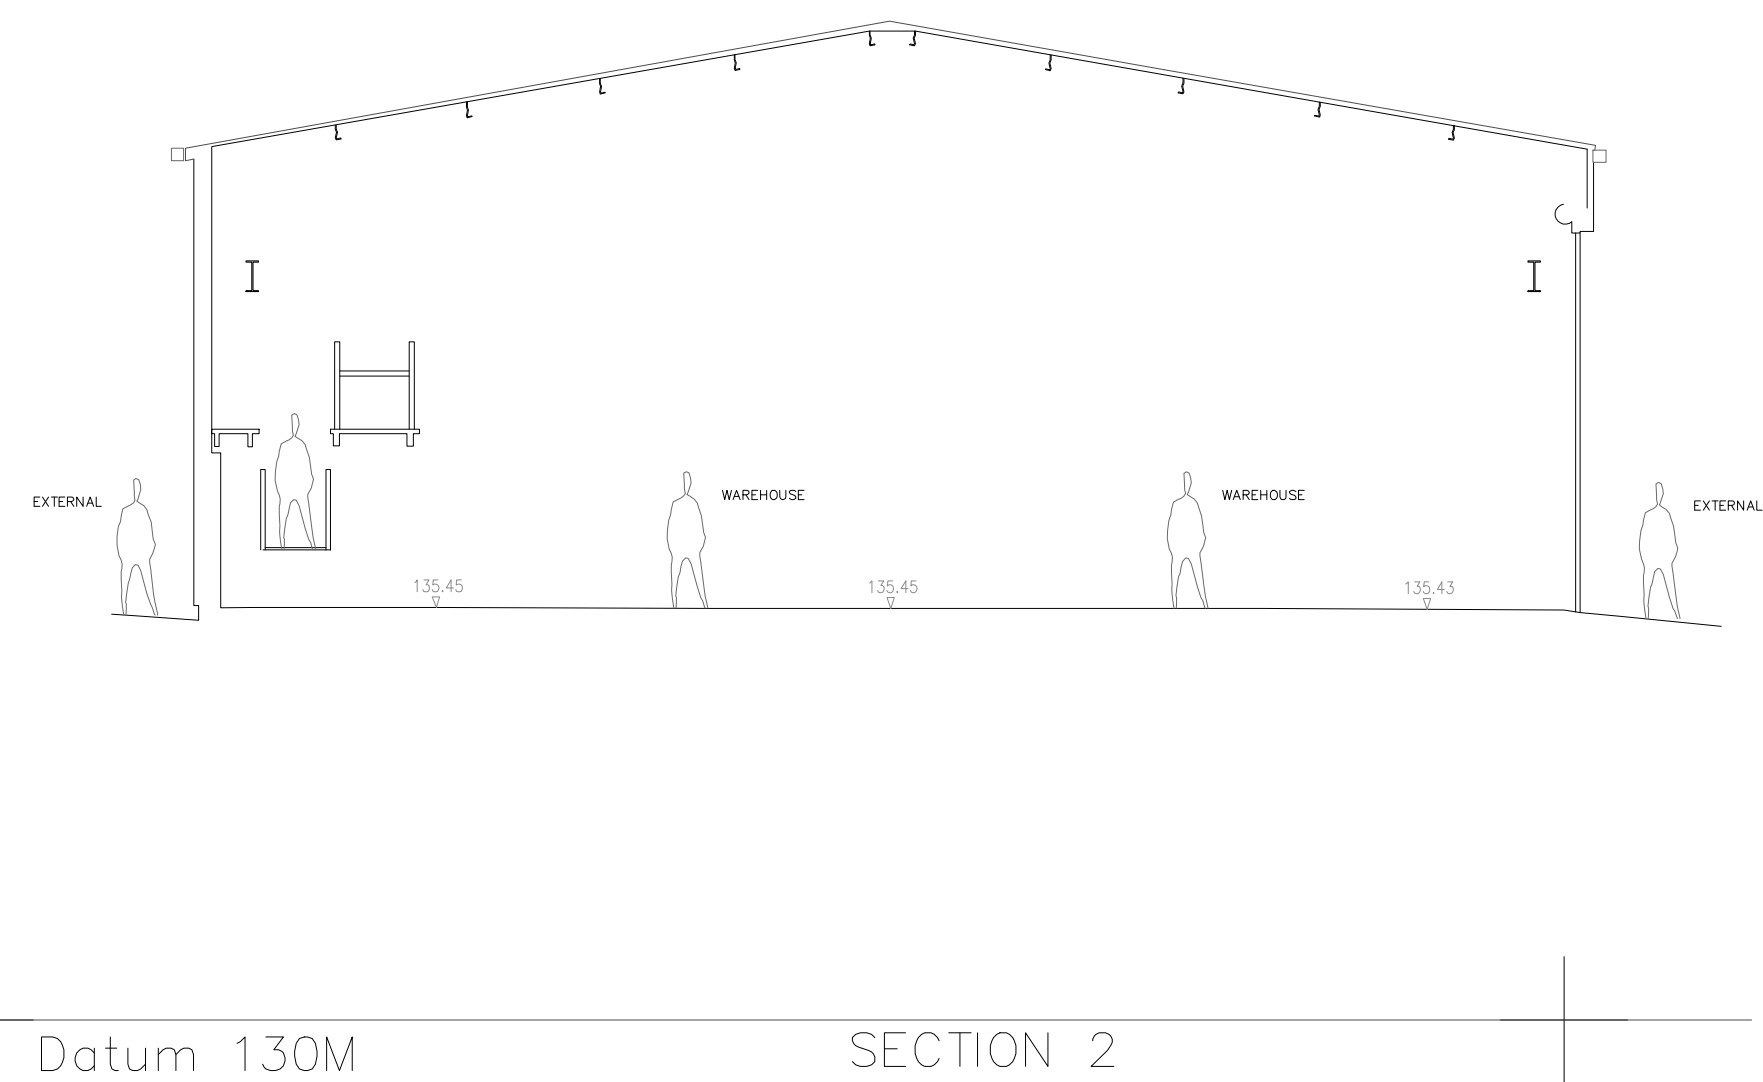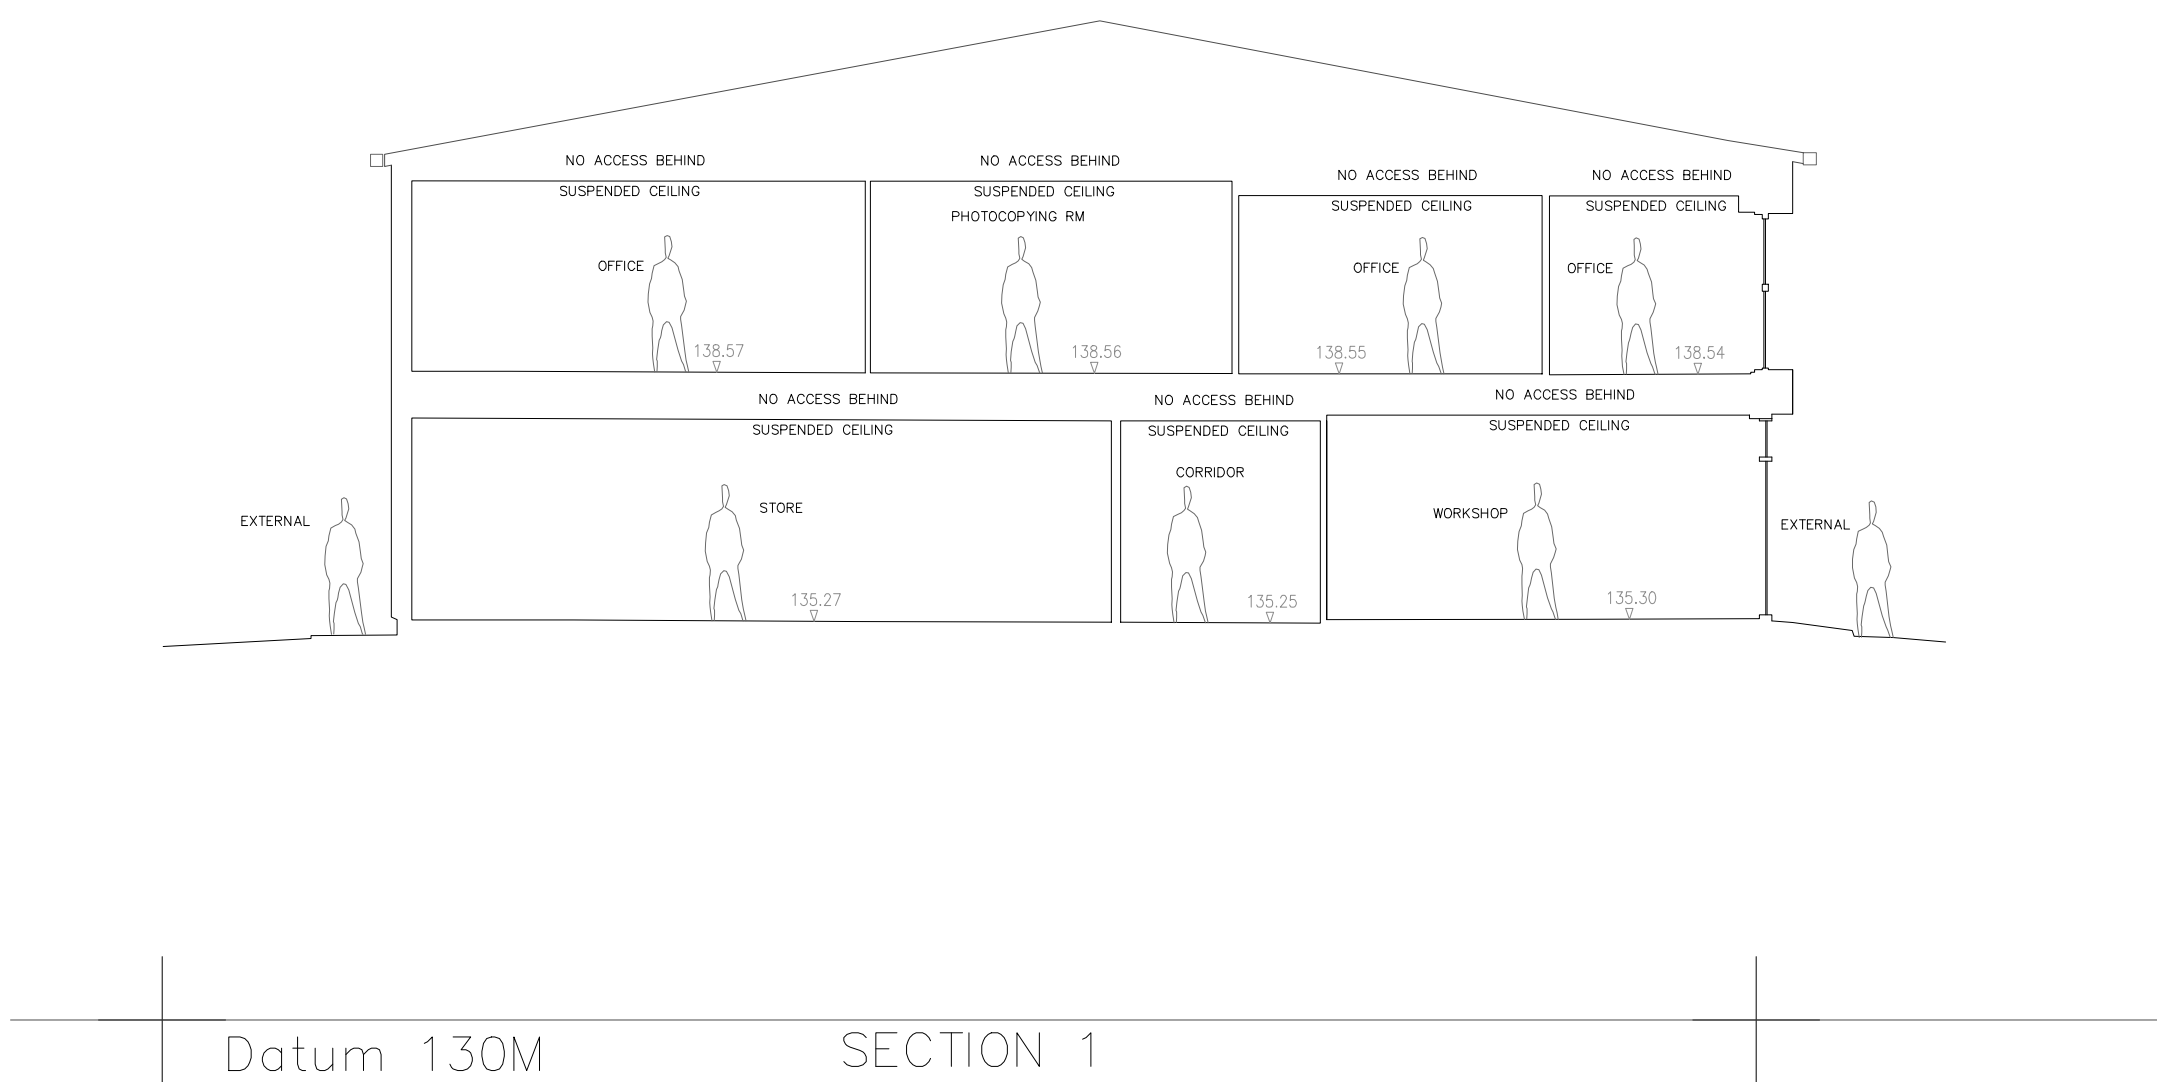

Abbreviations/Symbols (Measured Building Surveys):		
C:	Window Cill Height	
H:	Window Head Height	
BH:	Beam Height	
DH:	Door Height	
COL:	Column	
SVP:	Soil Vent Pipe	
FL:	Floor Level	
TH:	Threshold Level	
6.50	Floor to Ceiling Height	
	Vaulted Ceiling	
Line Types		
	Hedge Lines	
	Drainage Runs	
	Overhead Electricity Cables	
	Overhead Telephone Cables	
Symbols		
	Tree/Bush	Glass House
	Control Station	Osbn
	Borehole	
	Trial Hole	
Abbreviations (Topographic Survey):		
AH:	Arch Height	
AV:	Air Valve	
BB:	Bellish Beacon	
BOX:	Electricity Box, Cables Box, Etc.	
BO:	Bolard	
BT V/C:	British Telecom Inspection Chamber	
BS:	Bus Stop	
BS/LP:	Bus Stop / Lamp Post	
CATV:	CAV Inspection Chamber	
CCTV:	Closed Circuit Television	
CL:	Cellar Light	
C.PIT:	Catch Pit	
ER:	Earth Rod	
EC:	Electricity Inspection Chamber	
EP:	Electricity Pole	
FH:	Fire Hydrant	
FP:	Flag Pole	
GV:	Gas Valve	
G:	Gully	
IC:	Inspection Chamber	
KO:	Kerb Outlet	
LP:	Lamp Post	
LB:	Letter Box	
LC:	Lighting Column	
MKR:	Marker	
MH:	Manhole	
MP:	Mooring Point	
MS:	Mile Stone	
NYNEX:	Nynex Inspection Chamber	
O/H:	Over Hang	
P:	Post	
PO V/C:	Post Office Inspection Chamber	
R/S:	Road Sign	
RE:	Rodding Eye	
RTW:	Retaining Wall	
S/P:	Sign Post	
SNP:	Street Name Plate	
ST:	Stop Tap	
SV:	Stop Valve	
T:	Telecom Inspection Chamber	
TCB:	Telephone Call Box	
TH:	Threshold Level	
TL:	Traffic Light	
TP:	Telegraph Pole	
TROUGH:	Trough	
WO:	Water Outlet	
WM:	Water Meter	
Fence Descriptions:		
B/W:	Barbed Wire	
C/B:	Close Boarded	
C/BARRIER:	Crash Barrier	
C/L:	Chain Link	
C/P:	Chestnut Paling	
C/I:	Corrugated Iron	
I/R:	Iron Railing	
MISC:	Miscellaneous	
P/R:	Post & Rail	
P/W:	Post & Wire	
P/C:	Post & Chain	
S/PAL:	Steel Palisade	
W/M:	Wire Mesh	

Survey Notes:		
Coordinates and Levels related to Ordnance Survey Datum – GPS 05GB36		
Revision	Date	Description



Chris Partington Land Surveyors

44a Green Lane
Sale
Cheshire
M33 5PP
t: 0161 976 1194
www.cpls.co.uk e: survey@cpls.co.uk

Client

A J Cocker Associates

Project

R & B Switchgear, Heywood Sections

Scale	1:100	Surveyed By	W M	Date	16.08.21
Drawing No.	160821WM-03	Checked By	CPLS	Date	20.08.21
		Drawn By	H H	Date	20.08.21