




ABB CHARGE POST FOUNDATION PLAN
SCALE 1:50

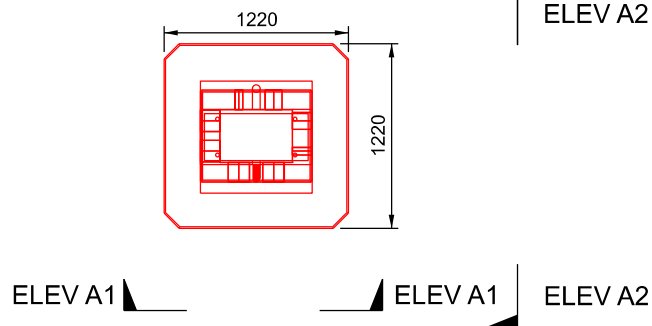


HP CABINET FOUNDATION PLAN
SCALE 1:50

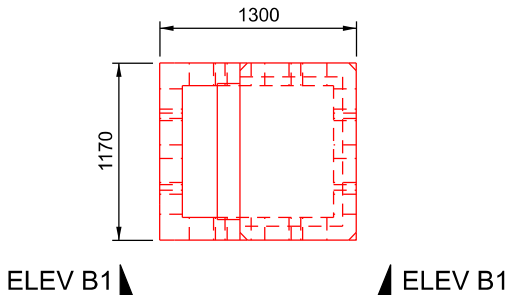


HYC 400 ALPITRONIC CHARGER PLAN
SCALE 1:50

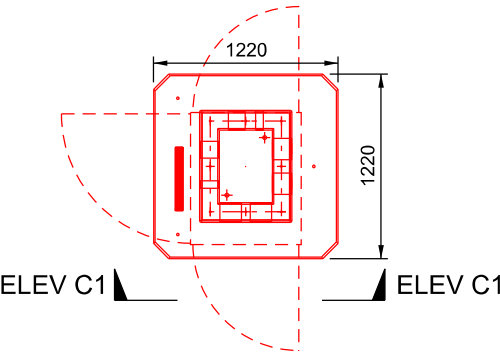


ELEVATION A1
SCALE 1:50

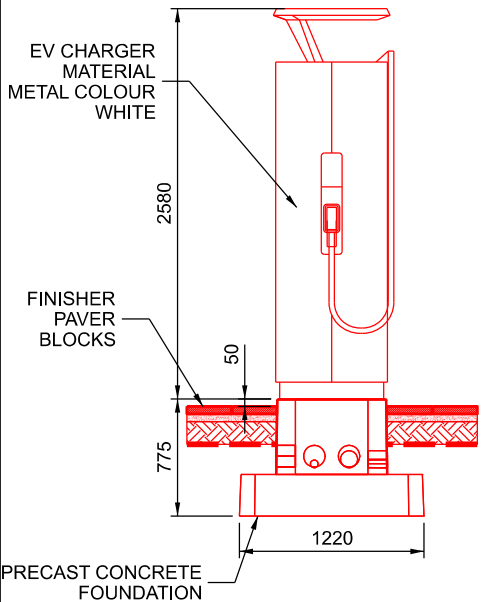


ELEVATION A2
SCALE 1:50

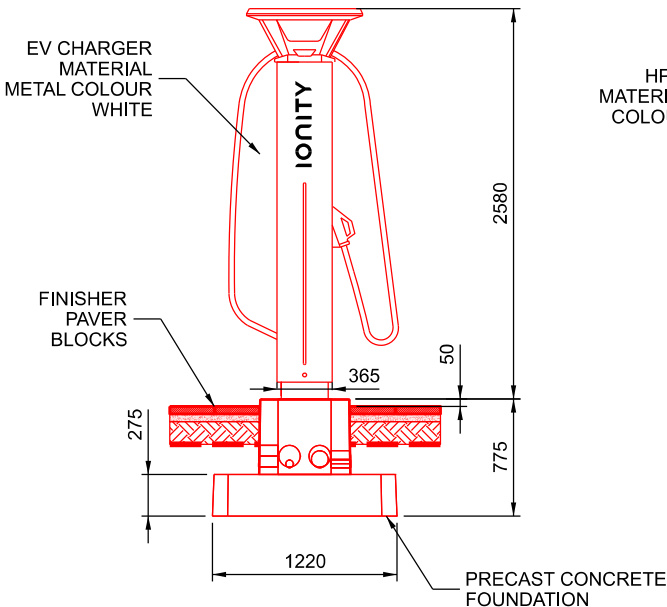


ELEVATION B1
SCALE 1:50

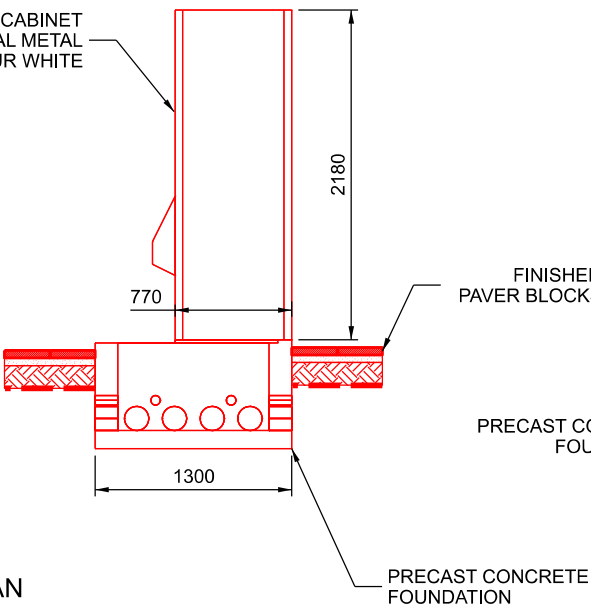


ELEVATION C1
SCALE 1:50

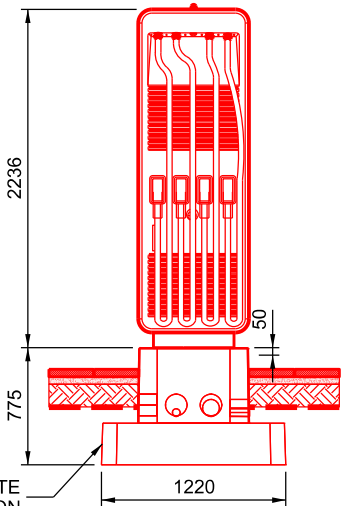

 
HYC 50 ALPITRONIC CHARGER PLAN
SCALE 1:50




ELEVATION E1
SCALE 1:50

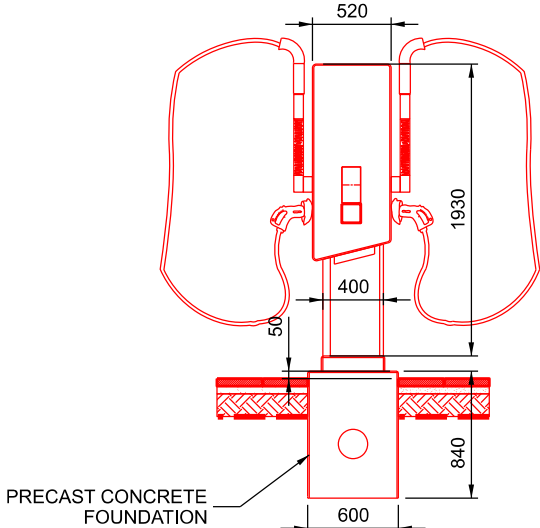


NAL BOLLARD PLAN
SCALE 1:50

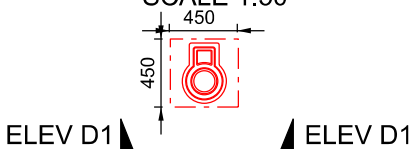

ELEVATION D1
SCALE 1:50

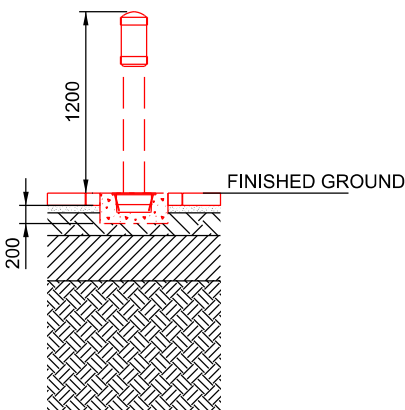

LV PANEL ELEVATION
SCALE 1:50

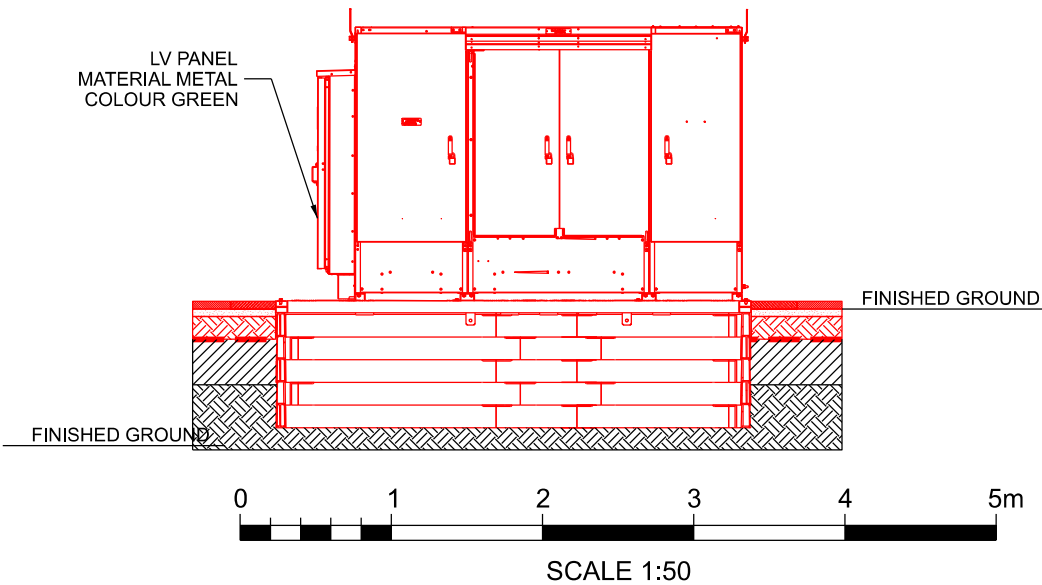

NOTES:

1. ALL DIMENSIONS ARE IN MILLIMETRES (mm) AND LEVELS ARE IN METRES (m) UNLESS STATED OTHERWISE.

COLOUR CONVENTIONS

BLACK - EXISTING OR UNCHANGED
BLUE - MODIFIED OR TO BE MOVED
GREEN - REDUNDANT OR TO BE REMOVED
RED - PROPOSED OR ADDITIONAL
PURPLE - WORKS BY OTHERS/FUTURE WORKS

P04	16/07/24	ISSUED FOR REVIEW	MB	SV	VS
P03	31/05/24	ISSUED FOR REVIEW	ADI	Chk	App
P02	24/01/24	ISSUED FOR REVIEW	ADI	Chk	App
P01	10/11/23	ISSUED FOR REVIEW	ADI	Chk	App
Rev	Date	Description of Revisions	Drawn	Chkd	Appr

Suitability

S0 - WORK IN PROGRESS



Poise Group Ltd
No 5, C - D Bear Lane
London
SE1 0UH

Contractor(s)



Ionity GmbH
Moosacher Strasse 84,
D-80809 Munich
Germany

Project

8312-IONITY
VILLAGE HOTEL
MANCHESTER BURY

Drawing Title

GENERAL TYPICAL DETAILS

Designed	ADITYA	Signed		Date	08/11/24
Drawn	ADITYA	Signed		Date	08/11/23
Checked	S VENKATESHA	Signed		Date	12/07/24
Approved	V K SHAH	Signed		Date	15/07/24

Scale(s)	R.T.D	ELR & Mileage	ELR&Mileage
----------	-------	---------------	-------------

Alternative Reference	-	Sheet	01 of 01
-----------------------	---	-------	----------

Drawing Number	8312-POI-DRG-CIV-200016	Revision	P04
----------------	-------------------------	----------	-----