


- BT — BT TELEPHONE / INTERNET LINE
- GAS — GAS GAS PIPELINE
- HV — HV HIGH VOLTAGE INCOMING LINE
- LV — LV LOW VOLTAGE LINE
- W — W WATER SUPPLY LINE (TO BE CONFIRMED DEPENDING ON EXISTING CONDITION OF SYSTEM)
- CONSTRUCTIONS TO RETAIN

PROPOSED SITE PLAN + EXISTING SERVICES

Do not scale this drawing
ashton smith to be notified of discrepancies in figured dimensions
Contractors must check all dimensions from site
This drawing is copyright and is for use on this site only
This drawing is to be used solely for information as entitled
For other information refer to the latest revision of any cross referenced drawing

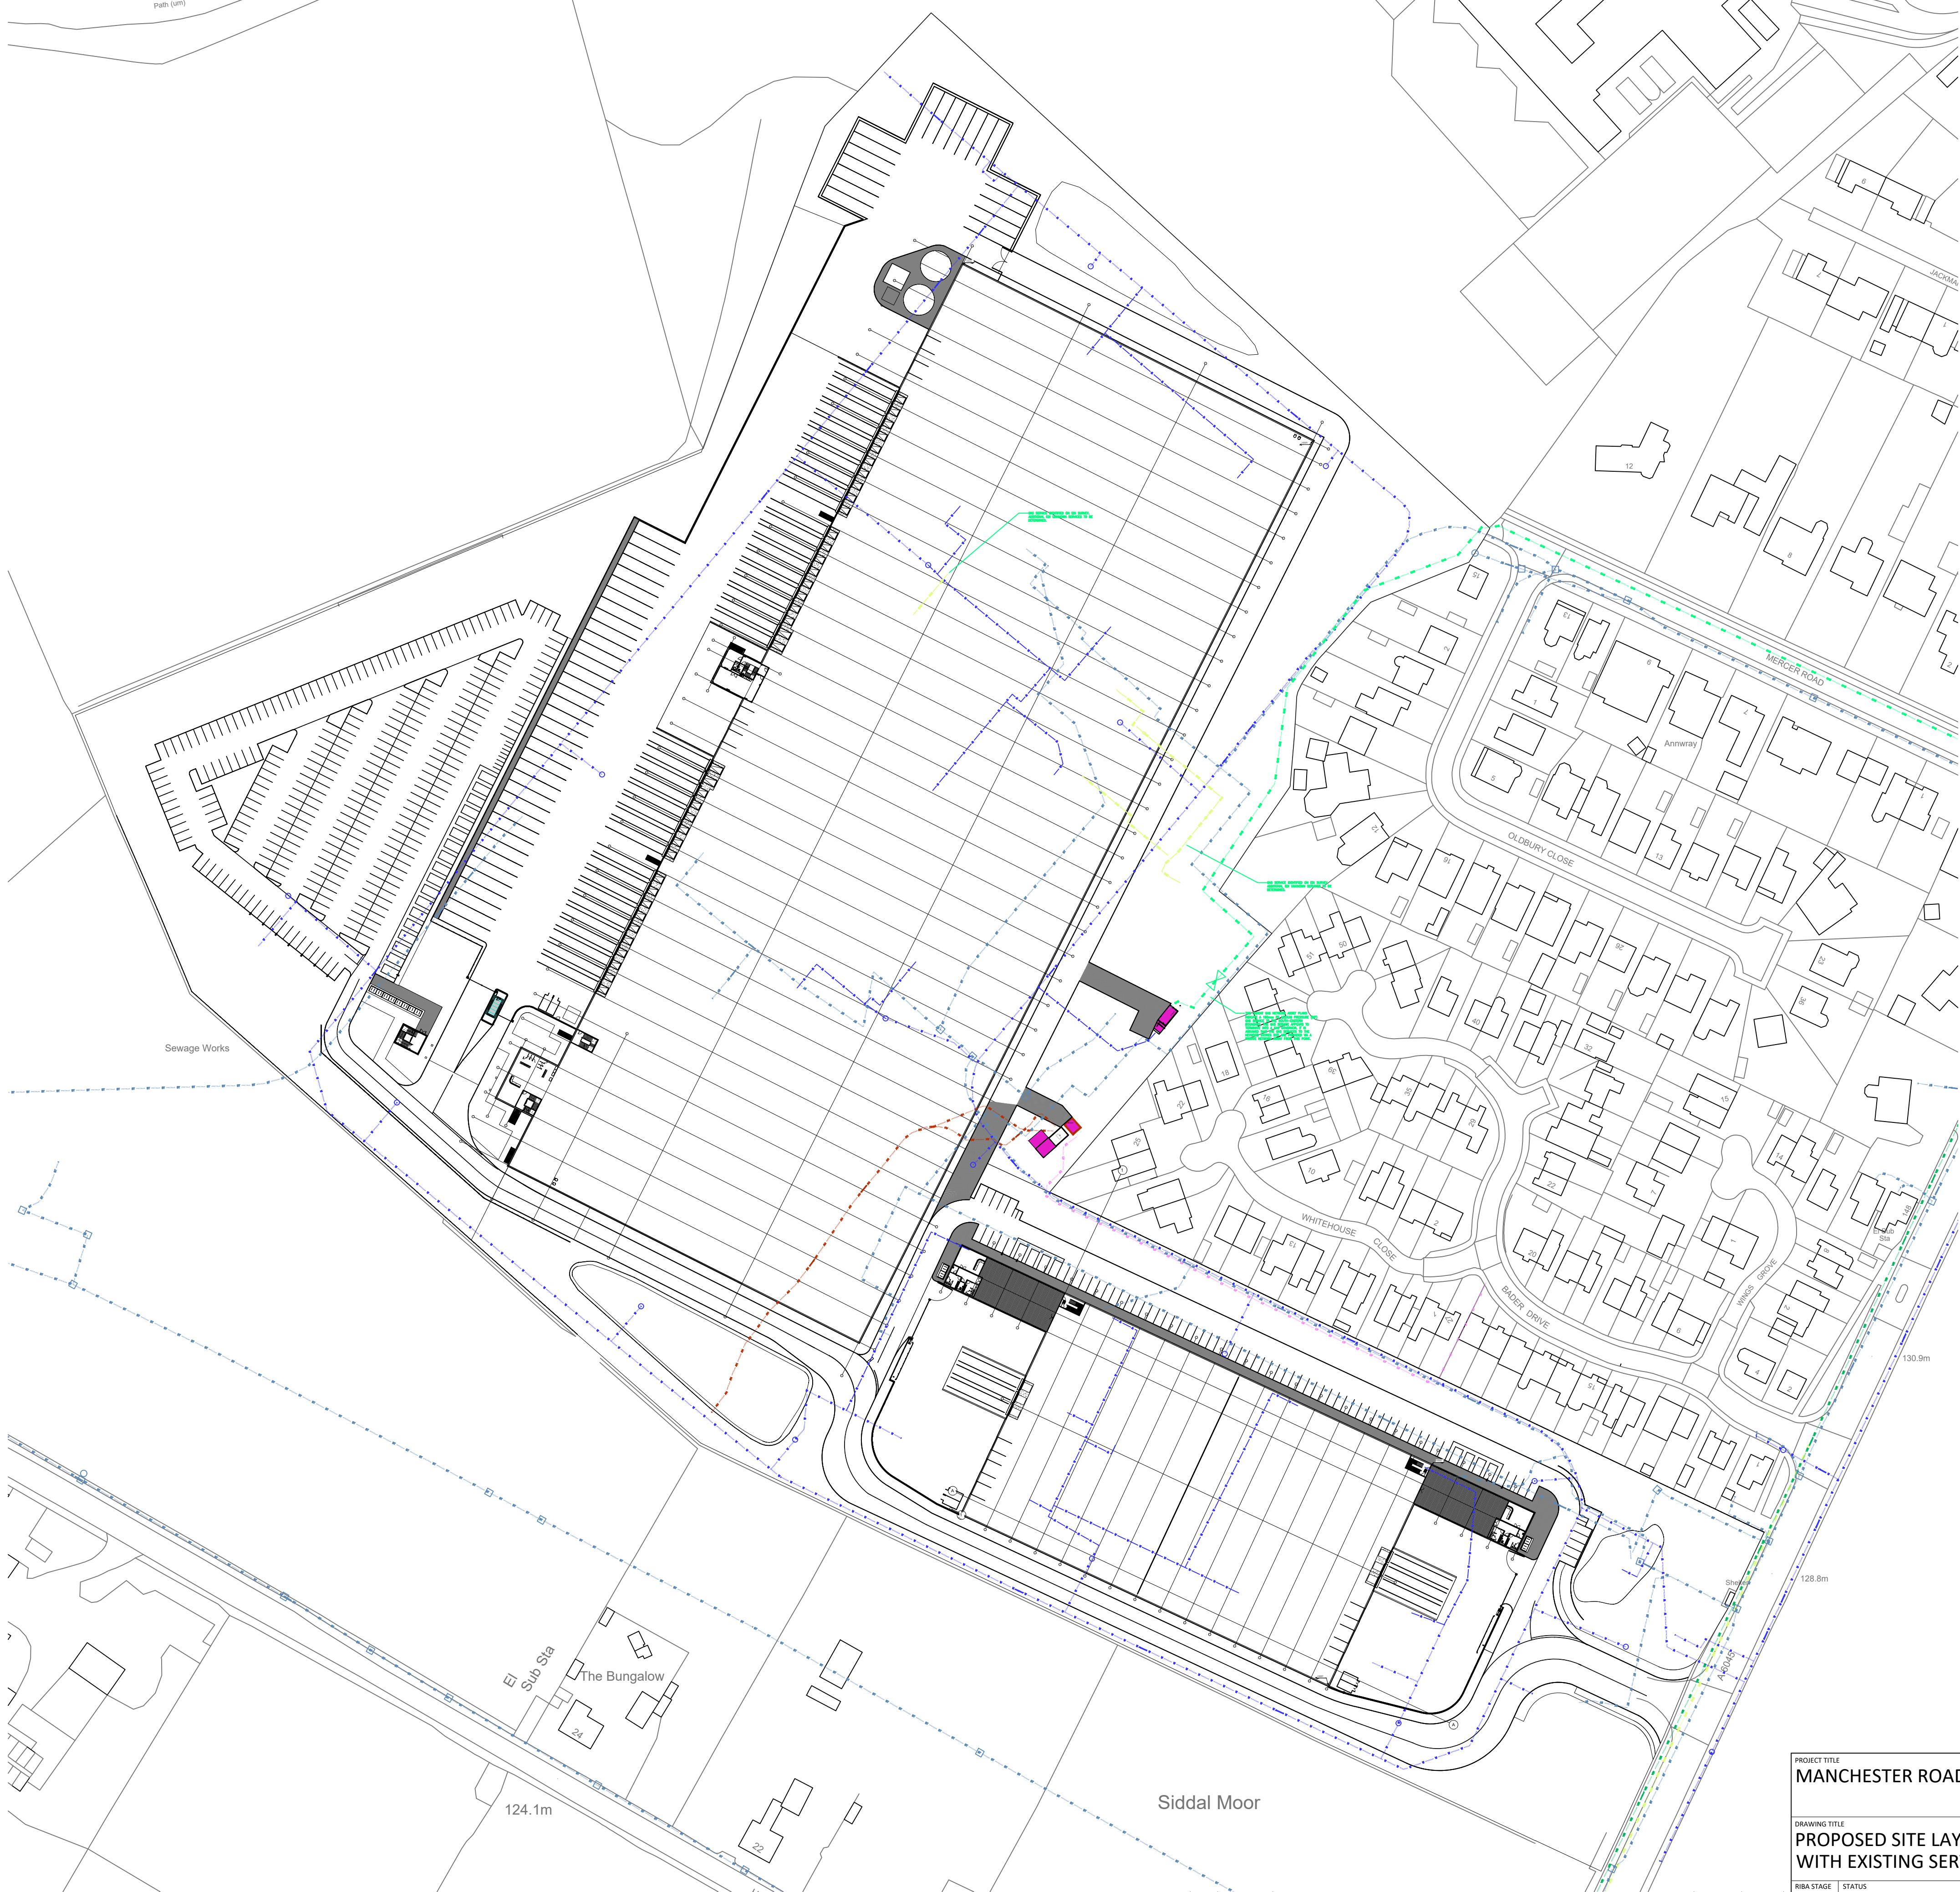

P1	07.02.23	Initial drawing issue	JA	RR
REV	DATE	DESCRIPTION	DRAWN BY	CHECK BY
REVISIONS				

PROJECT TITLE MANCHESTER ROAD, HEYWOOD			
DRAWING TITLE PROPOSED SITE LAYOUT WITH EXISTING SERVICES			
RIBA STAGE N/A	STATUS PLANNING	DRAWN BY JA	CHECKED BY RR
SHEET A1	SCALE 1 : 1000	DATE 19/01/2023	REVISION S3 P1
DRAWING NO. 21157 - ASA - 00 - ZZ.ZZ - D - A - 3022_ (S3 - P1)			

CLIENT
Trammell Crow Company
Ashton Smith Beyond Design
Ashton Smith, Belvedere House, 2 Victoria Avenue, Harrogate, North Yorkshire, HG1 1EL Tel: 01423 522882 Fax: 01423 565104 www.ashtonsmith.co.uk

JOB NO.
21157