


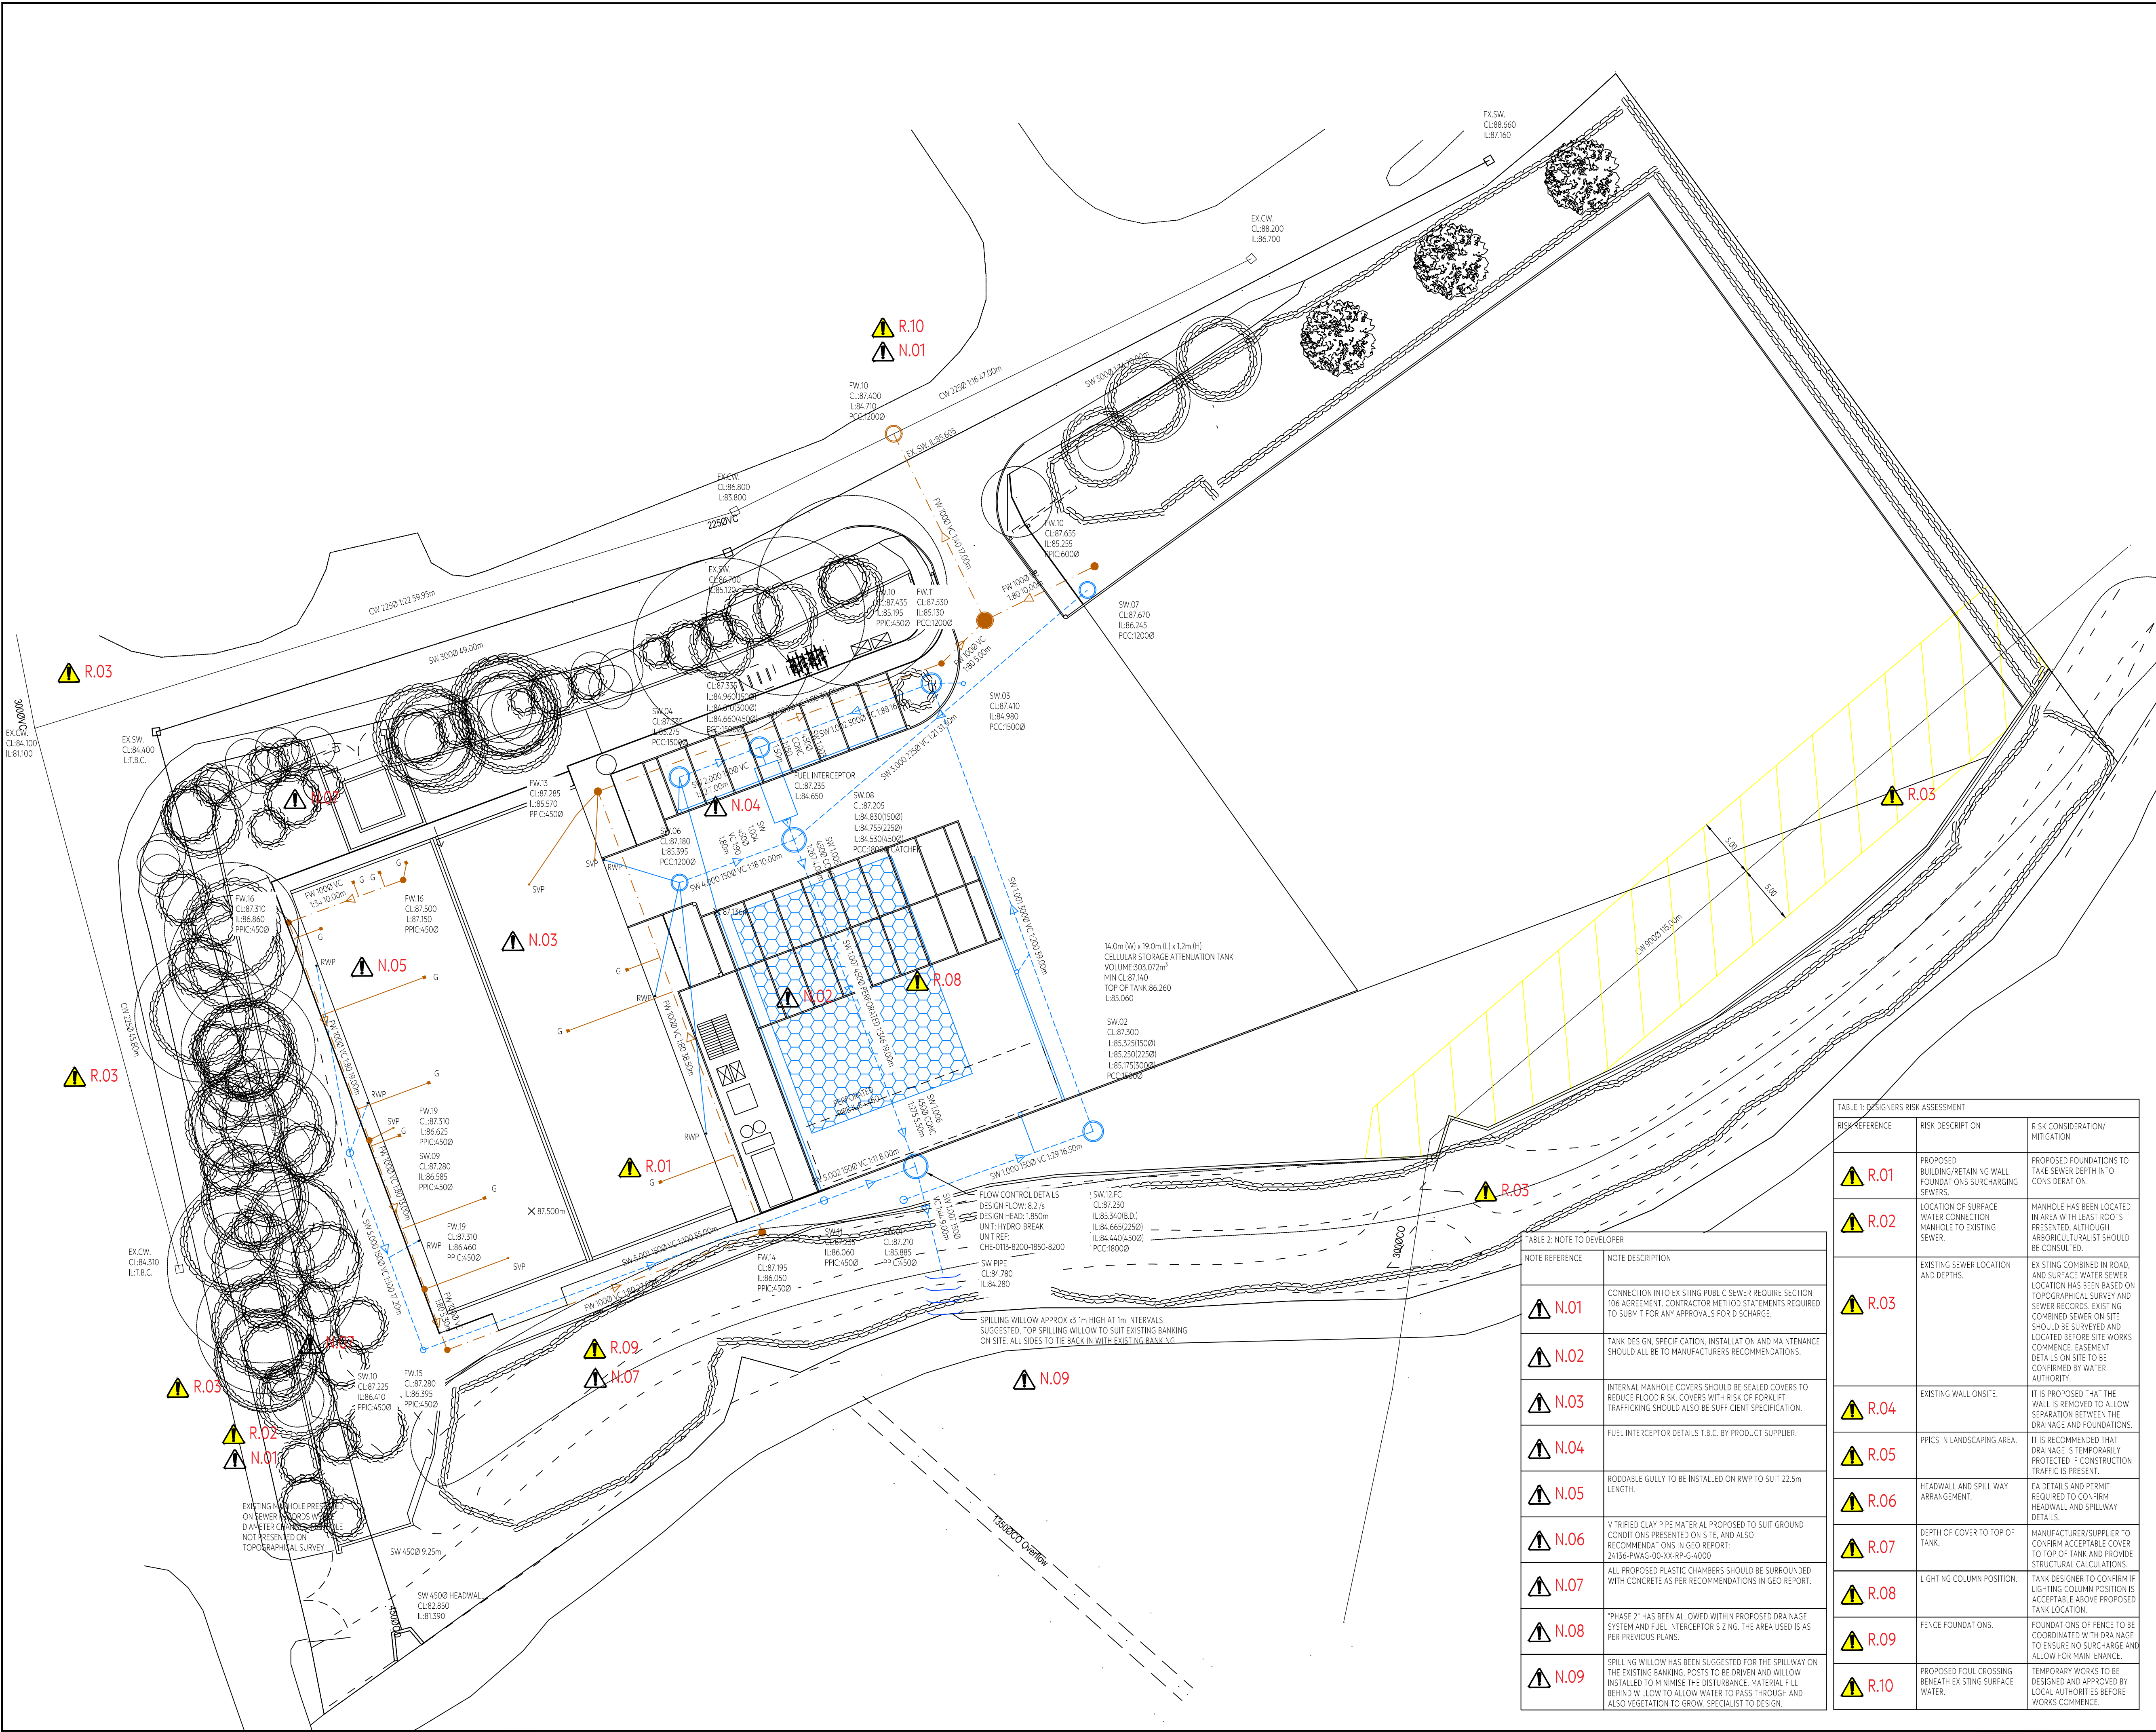

SITE LOCATION
OS X (EASTINGS) 387523
OS Y (NORTHINGS) 406097
NAT GRID SD8752306098
POSTCODE M24 2HD

NOTES:

- COPYRIGHT IN THIS DOCUMENT BELONGS TO PAUL WAITE ASSOCIATES LIMITED & ALL RIGHTS IN IT ARE RESERVED BY THE OWNER.
- NO PART OF THIS DRAWING MAY BE COPIED, TRANSFERRED, OR MADE AVAILABLE TO USERS OTHER THAN THE ORIGINAL RECIPIENT, INCLUDING ELECTRONICALLY, WITHOUT PRIOR PERMISSION FROM PAUL WAITE ASSOCIATES LIMITED.
- THIS DRAWING IS TO BE READ IN CONJUNCTION WITH ALL RELEVANT ARCHITECTS & ENGINEERS DRAWINGS & SPECIFICATIONS.
- ALL DIMENSIONS ARE SHOWN IN MILLIMETRES.
- NO DIMENSIONS TO BE SCALED FROM THIS DRAWING.
- ONLY PDF/HARD COPIES OF DRAWINGS SHOULD BE REFERRED TO FOR CONSTRUCTION. THE USE OF AUTOCAD DRAWINGS/DWG'S IS UNDERTAKEN ENTIRELY AT THE DEVELOPER'S RISK AND ALL DIMENSIONS AND SETTING OUT MUST BE CHECKED IN CONJUNCTION WITH THE ARCHITECT AND ENGINEERS CONSTRUCTION DRAWINGS. ALL DRAWINGS SHOULD BE CONFIRMED AS LATEST ISSUE ON THE DOCUMENT ISSUE SHEET PRIOR TO COMMENCEMENT OF WORKS AND SHOULD BE USED ONLY FOR THEIR DEFINED DRAWING STATUS. ANY DISCREPANCIES BETWEEN THE ARCHITECT AND ENGINEERS DRAWINGS ARE TO BE IMMEDIATELY NOTIFIED TO ALL PARTIES.

KEY

- EXISTING SURFACE WATER SEWER
- EXISTING SURFACE WATER MANHOLE
- EXISTING FOUL WATER SEWER
- EXISTING FOUL WATER MANHOLE
- EXISTING COMBINED WATER SEWER
- EXISTING COMBINED WATER MANHOLE
- PROPOSED SURFACE WATER SEWER
- PROPOSED SURFACE WATER MANHOLE
- PROPOSED SURFACE WATER FLOW CONTROL MANHOLE
- PROPOSED SURFACE WATER INSPECTION CHAMBER
- PROPOSED CELLULAR STORAGE
- PROPOSED CHANNEL
- PROPOSED GULLY
- PROPOSED FOUL WATER SEWER
- PROPOSED FOUL WATER MANHOLE
- PROPOSED FOUL WATER INSPECTION CHAMBER
- SITE BOUNDARY

Rev	Date	Remarks	Drawn	Chk'd
T04	12.09.25	REVISED TO SPILLING WILLOW AT SPILLWAY.	JLE	LS
T03	17.07.25	REVISED TO SUIT NEW SITE PLAN.	JLE	LS
T02	09.04.25	REVISED TO SUIT FENCE LINE.	JLE	LS
T01	14.03.25	STATUS REVISED TO SUIT TENDER.	JLE	LS
R04	05.03.25	FOUL LAYOUT REVISED TO SUIT RETAINING WALL DESIGN.	JLE	LS
R03	12.02.25	REVISED TO SUIT LAYOUT ALTERATIONS.	JLE	LS
R02	02.12.24	REVISED TO SUIT DRAINAGE ALTERATIONS.	JLE	LS
R01	25.11.24	FIRST ISSUE.	JLE	LS

PWA / GROUP
CIVIL
STRUCTURAL
GEO-ENVIRONMENTAL

SUMMIT HOUSE, RIPARIAN WAY,
THE CROSSINGS, CROSSHILLS,
KEIGHLEY, BD20 7BW

01535 633350
info@pwagroup.co.uk
www.pwagroup.co.uk

Client
MSM AERO

Project
PROPOSED INDUSTRIAL DEVELOPMENT
HANSON CLOSE
MIDDLETON

Title
PROPOSED DRAINAGE LAYOUT

Size	Scale	Designed	Checked	Date
A1	1:250	JLE	LS	NOV 24

Drawing Status
TENDER

Job Number	Originator	Zone	Level	Type	Role	Drawing No.	Rev
24:136	PWA	00	XX	DR	C	1001	T04