


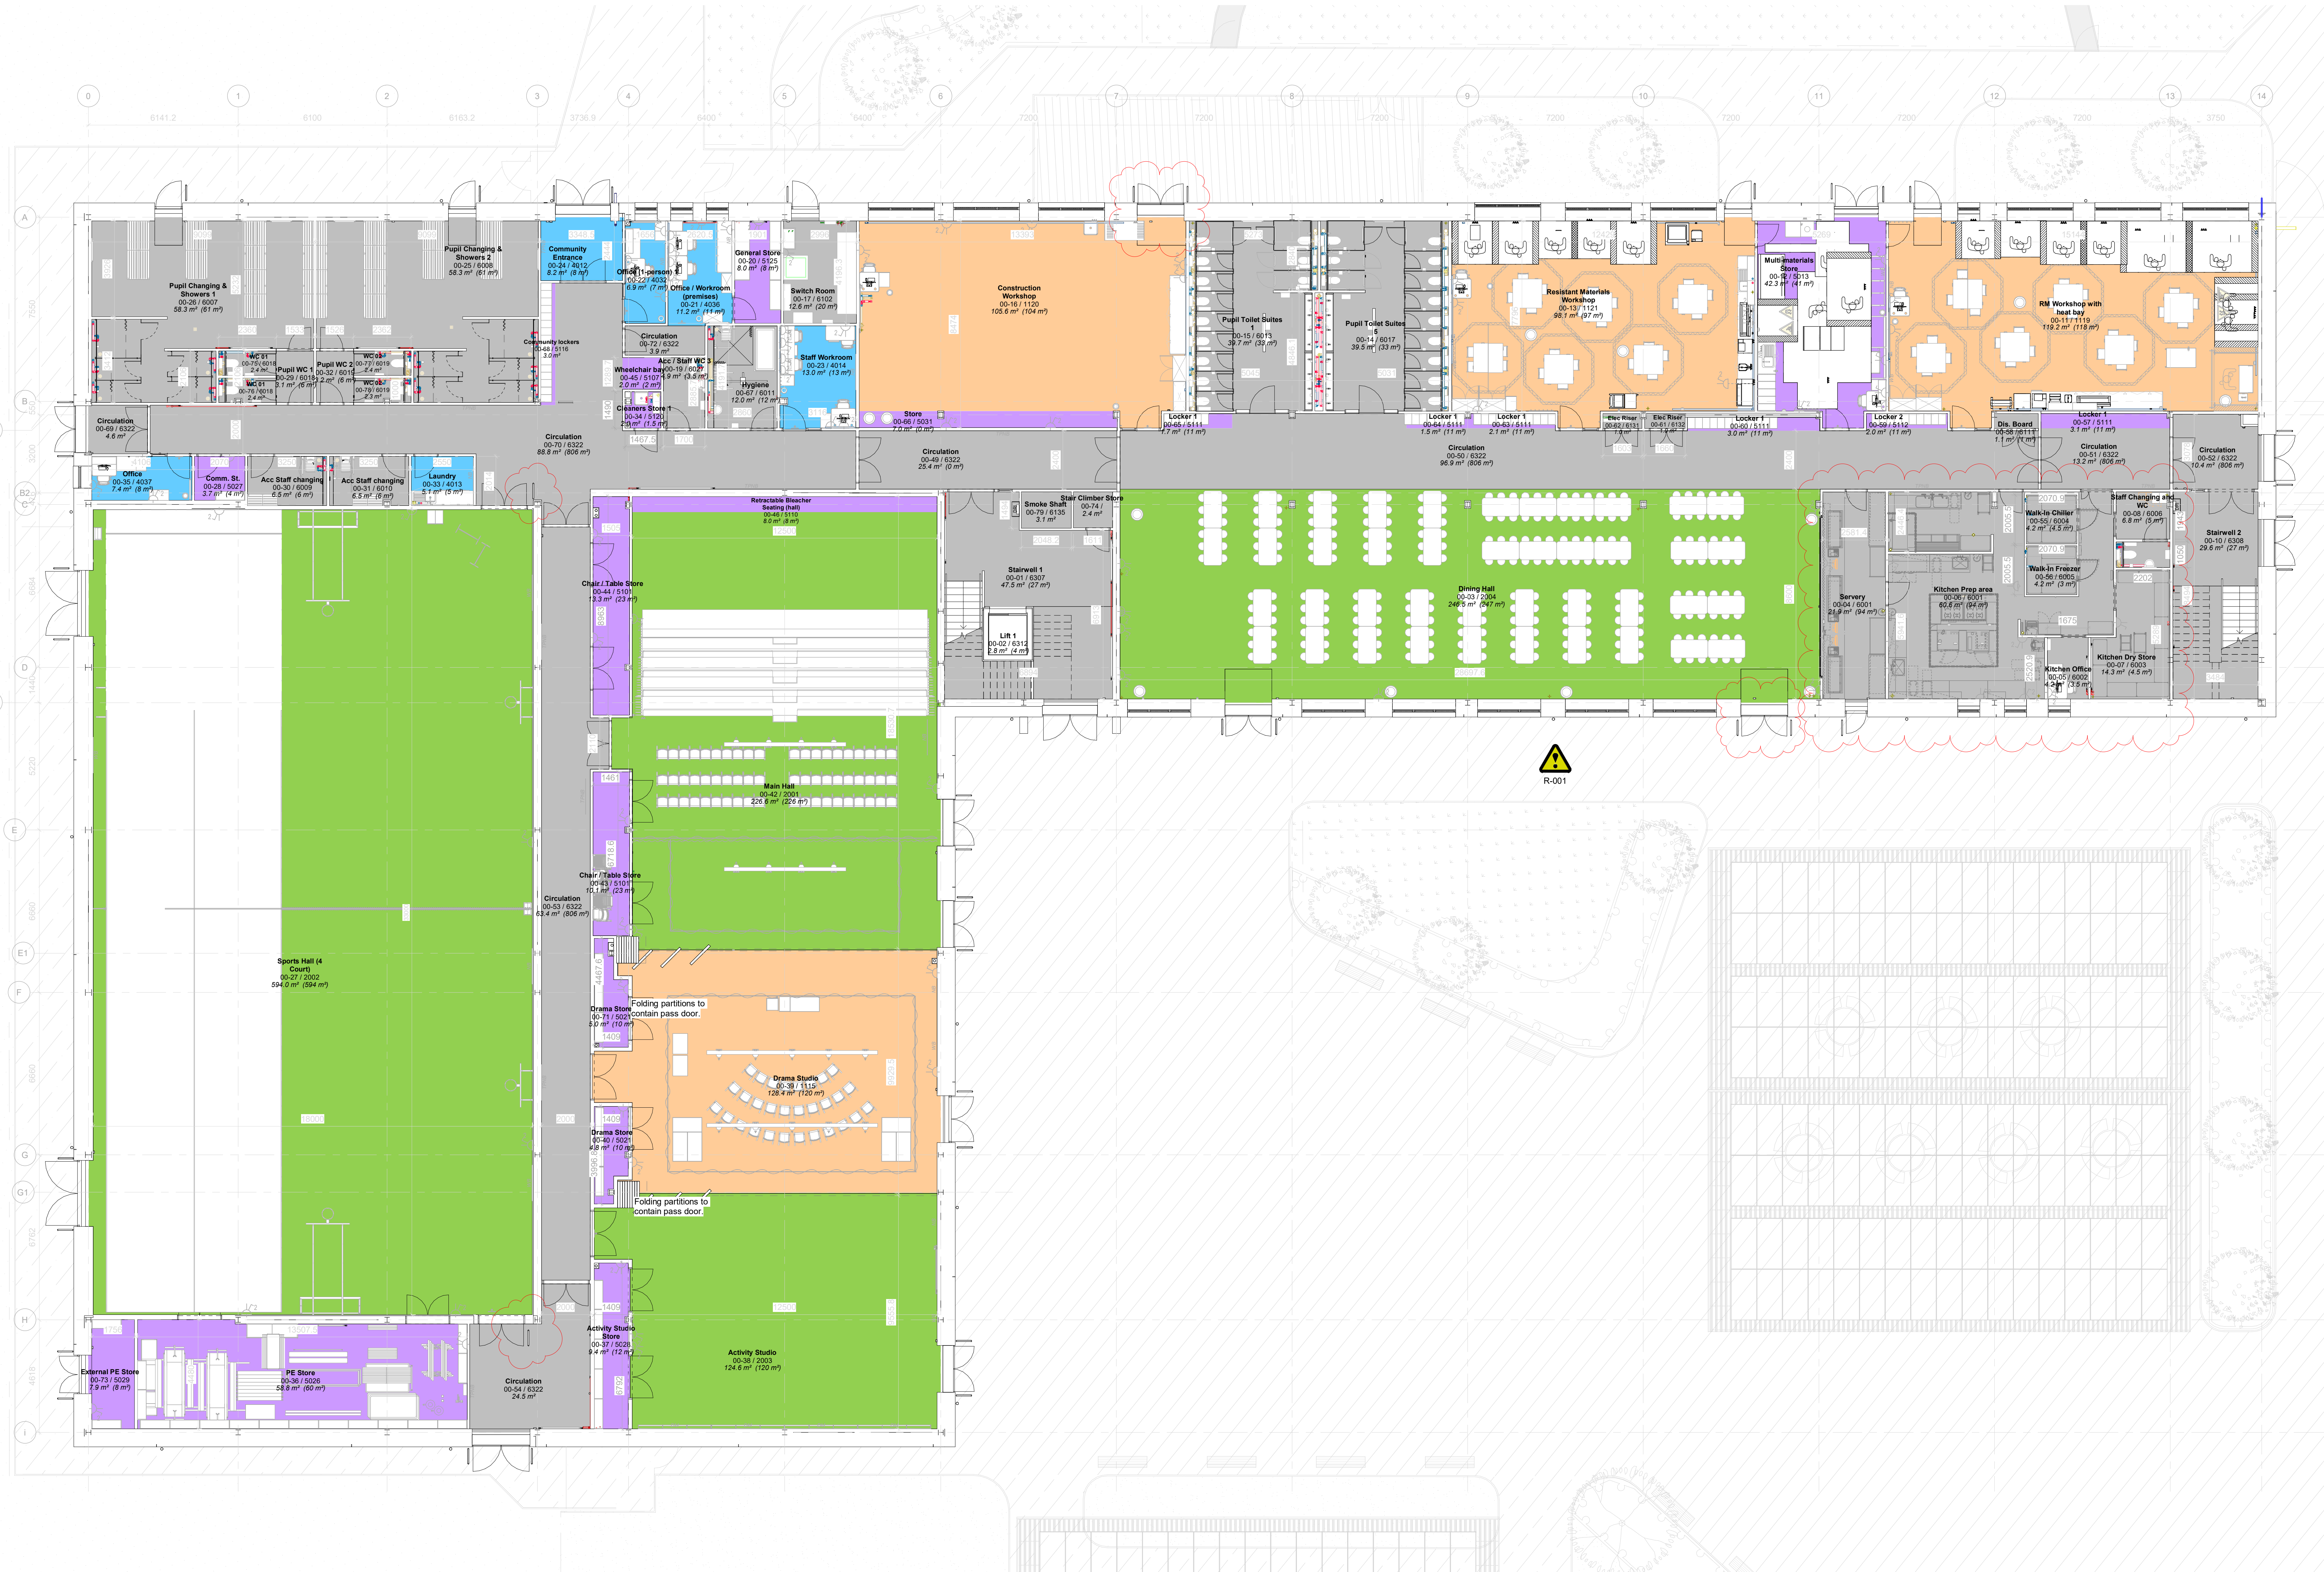

1 00-General Arrangement - Ground Level Plan
1: 100

P22	Construction workshop and dining hall external openings updated as per client's comments.	12.01.2023	GA	PM
P23	Sports Hall clear pedestrian access. Servery's external door with recessed. Site plan layout updated. Kitchen layout updated.			
P21	Site plan updated.	16.12.2022	NAR	PM
P20	Site plan updated from each changing room as per client's request.	14.11.2022	NAR	PM
P19	Issued for Planning.	26.08.2022	NAR	PM
P18	Issued for Contractor Proposals.	19.08.2022	NAR	PM
P17	Revised CP submitted.	09.08.2022	NAR	PM
P16	Client's initial 3D model submitted to Structural 1. Design development.	01.07.2022	NAR	PM
P15	Gridlines removed as requested by GPM.	30.05.2022	NAR	PM
P14	Issue for costing.	20.05.2022	NAR	PM
P13	Final Planning Issue.	20.05.2022	JE	NAR
P12	Updated drawing in line with DRAFT CP Clarifications response.	22.04.2022	JE	PM
P11	Issued for Client Construction Programme Package.	06.04.2022	JE	PM
P10	Drawings issued for CDM Meeting.	21.03.2022	AM	PM
P09	Drawings issued for CDM Meeting.	26.03.2022	AM	PM
P08	Issue for Client Construction Programme Package.	21.03.2022	AM	PM
P07	Issue for Client Construction Programme Package.	16.03.2022	JE	PM
P06	Drawings issued for CDM Meeting.	08.03.2022	JE	PM
P05	Issue for Client Construction Programme Package.	08.03.2022	JE	PM
P04	Issue for Client Construction Programme Package.	01.03.2022	JE	PM
P03	Issue for Client Construction Programme Package.	10.01.2022	JE	PM
P02	Revised layout in line with client's comments.	01.01.2022	VE	PM
P01	Final Information.	22.12.2021	VE	PM
Rev	Description	Date	Drawn By	Check By

Project	Newhouse Academy	3A/54 Princess St Manchester M1 6HS
Title	Proposed Ground Level Plan	T : 0161 200 6300
Client	Morgan Sindall	man@jmarchitects.net www.jmarchitects.net
Contractor's Proposals	Scale: 1: 100@ A0	
Drawing Number	SRP1019-JMA-01-00-DR-A-0001	3A/54 Project Number D2 P22 6945

Note: For risks marked with yellow triangles refer to drawing SRP1019-JMA-01-ZZ-DR-A-0001 & SRP1019-JMA-01-ZZ-DR-A-0002.