


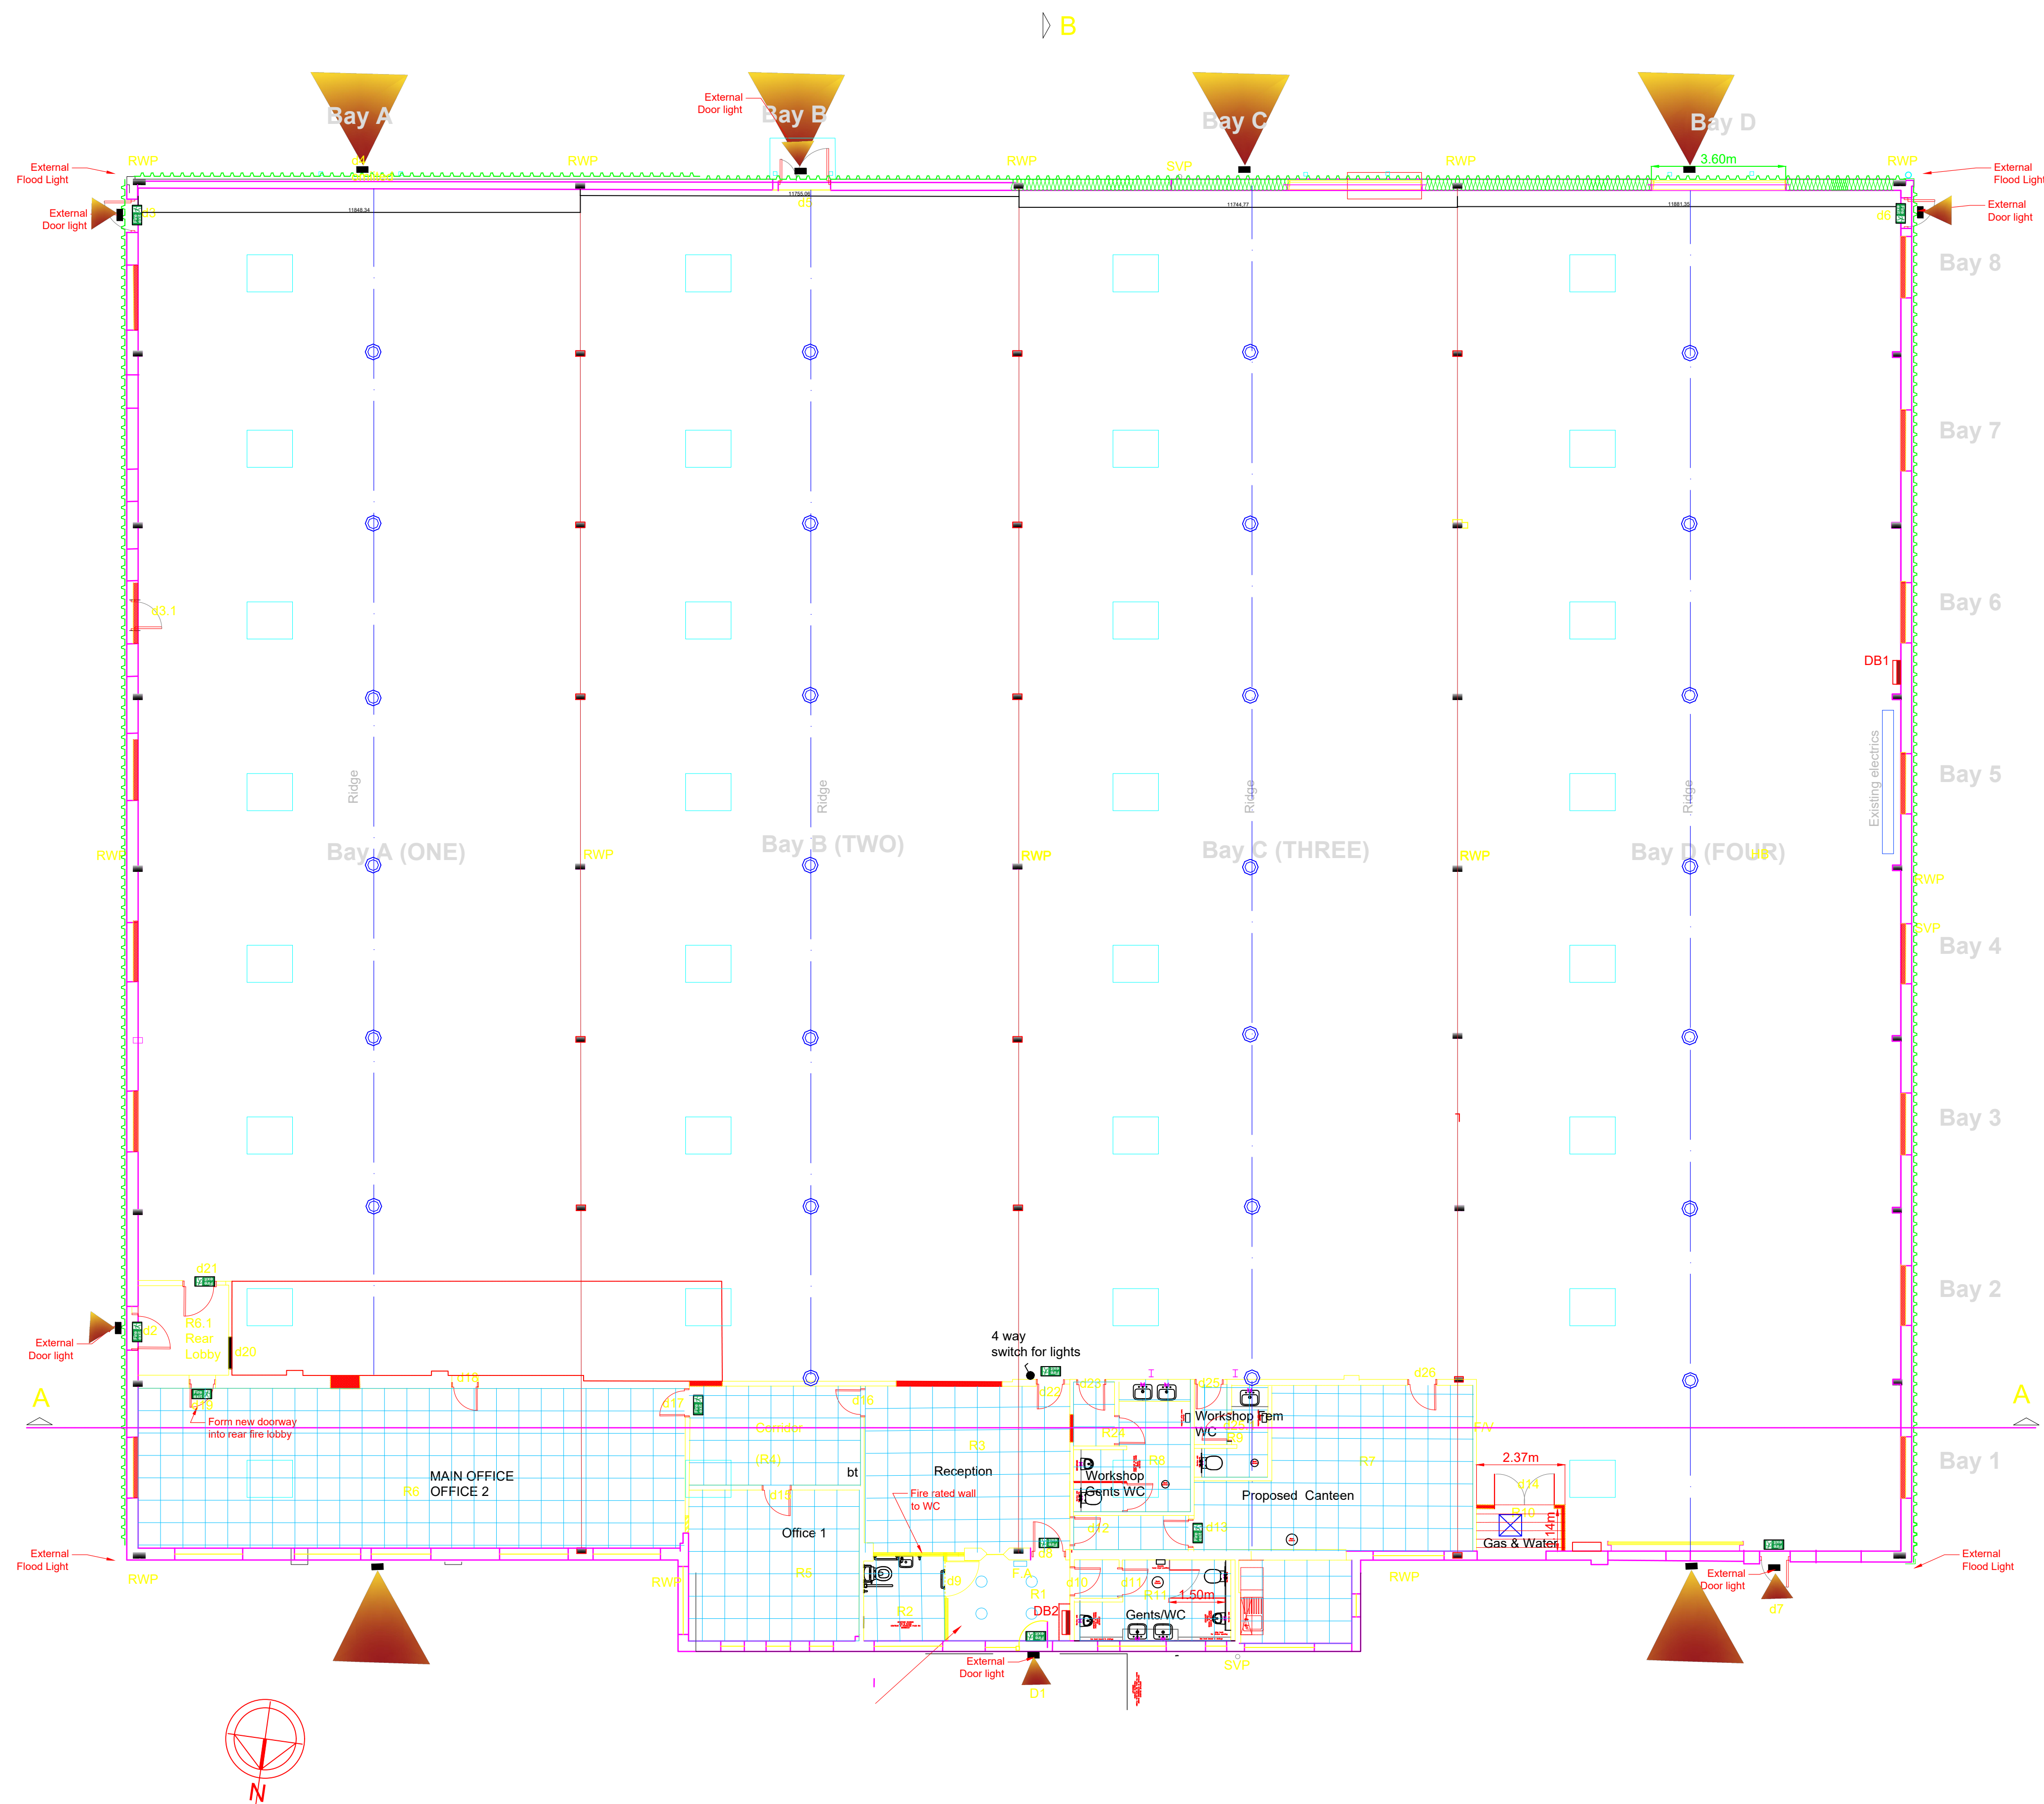

MGRA CONSULTING LTD
346 DEANS GATE
MANCHESTER
M3 4LY
CAD@MGRA.CO.UK
TEL: 0161 835 9936

© MGRA Consulting Ltd
Reproduction is prohibited
in whole or in part
without the express agreement of
MGRA Consulting Ltd.

Client: Homida.am Ltd
234 Leicester Park Road
Leicester
LE5 5PD

Property Address
Bentley Avenue
Stakehill Industrial Estate
Middletown
M24 2RW

Project Title Refurbishment	DWG Ref: 284- DWG
DWG Title: PROPOSED Lighting Layout	DWG No. 014

Scale various 1/100	Date 10/11/2021	Job No 264
Surveyed PWM/LPM	Drawn LPM	Checked PWM