


A Proposed Site Plan

101 SCALE 1:500

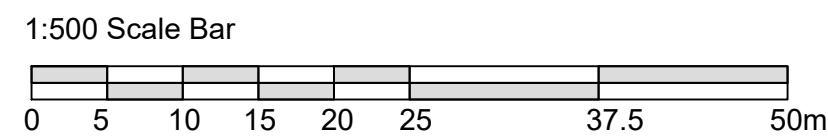

Location of Bio-Fuel Tank. 8m long x 2.6m wide x 2.7m High.

Location of 1No Bio-Fuel Generators and 1No Container to house the electrical panels LV Room.




E Image of the BioFuel Generator

101 SCALE NTS




B Proposed Plan and Elevations of the Bio Fuel Tank

101 SCALE 1:100

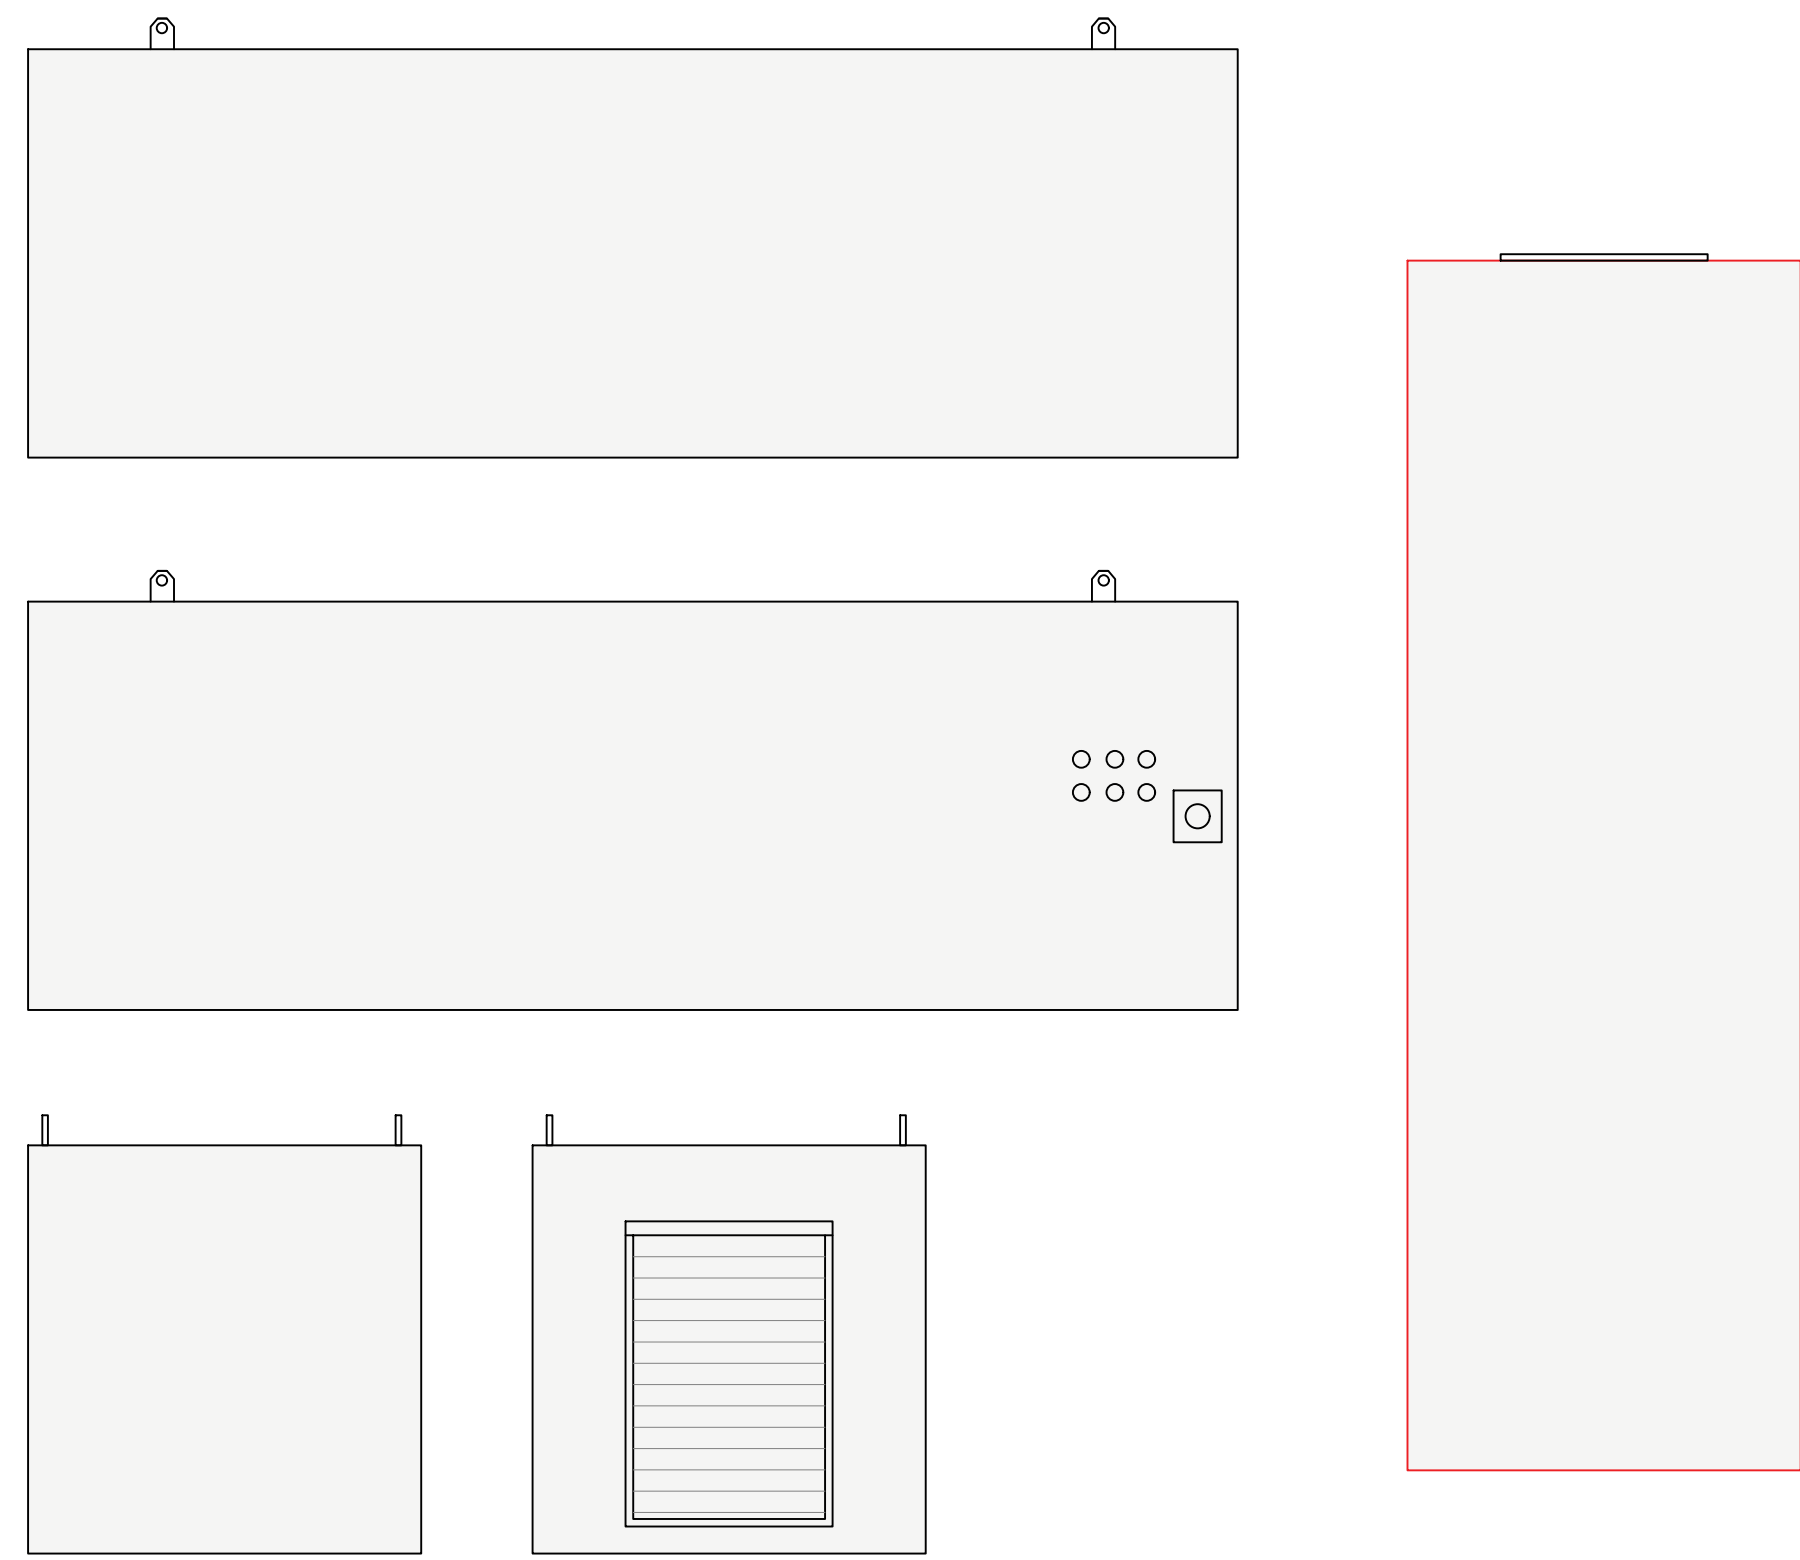



C Proposed Plan and Elevations of the Bio Fuel Generator

101 SCALE 1:100

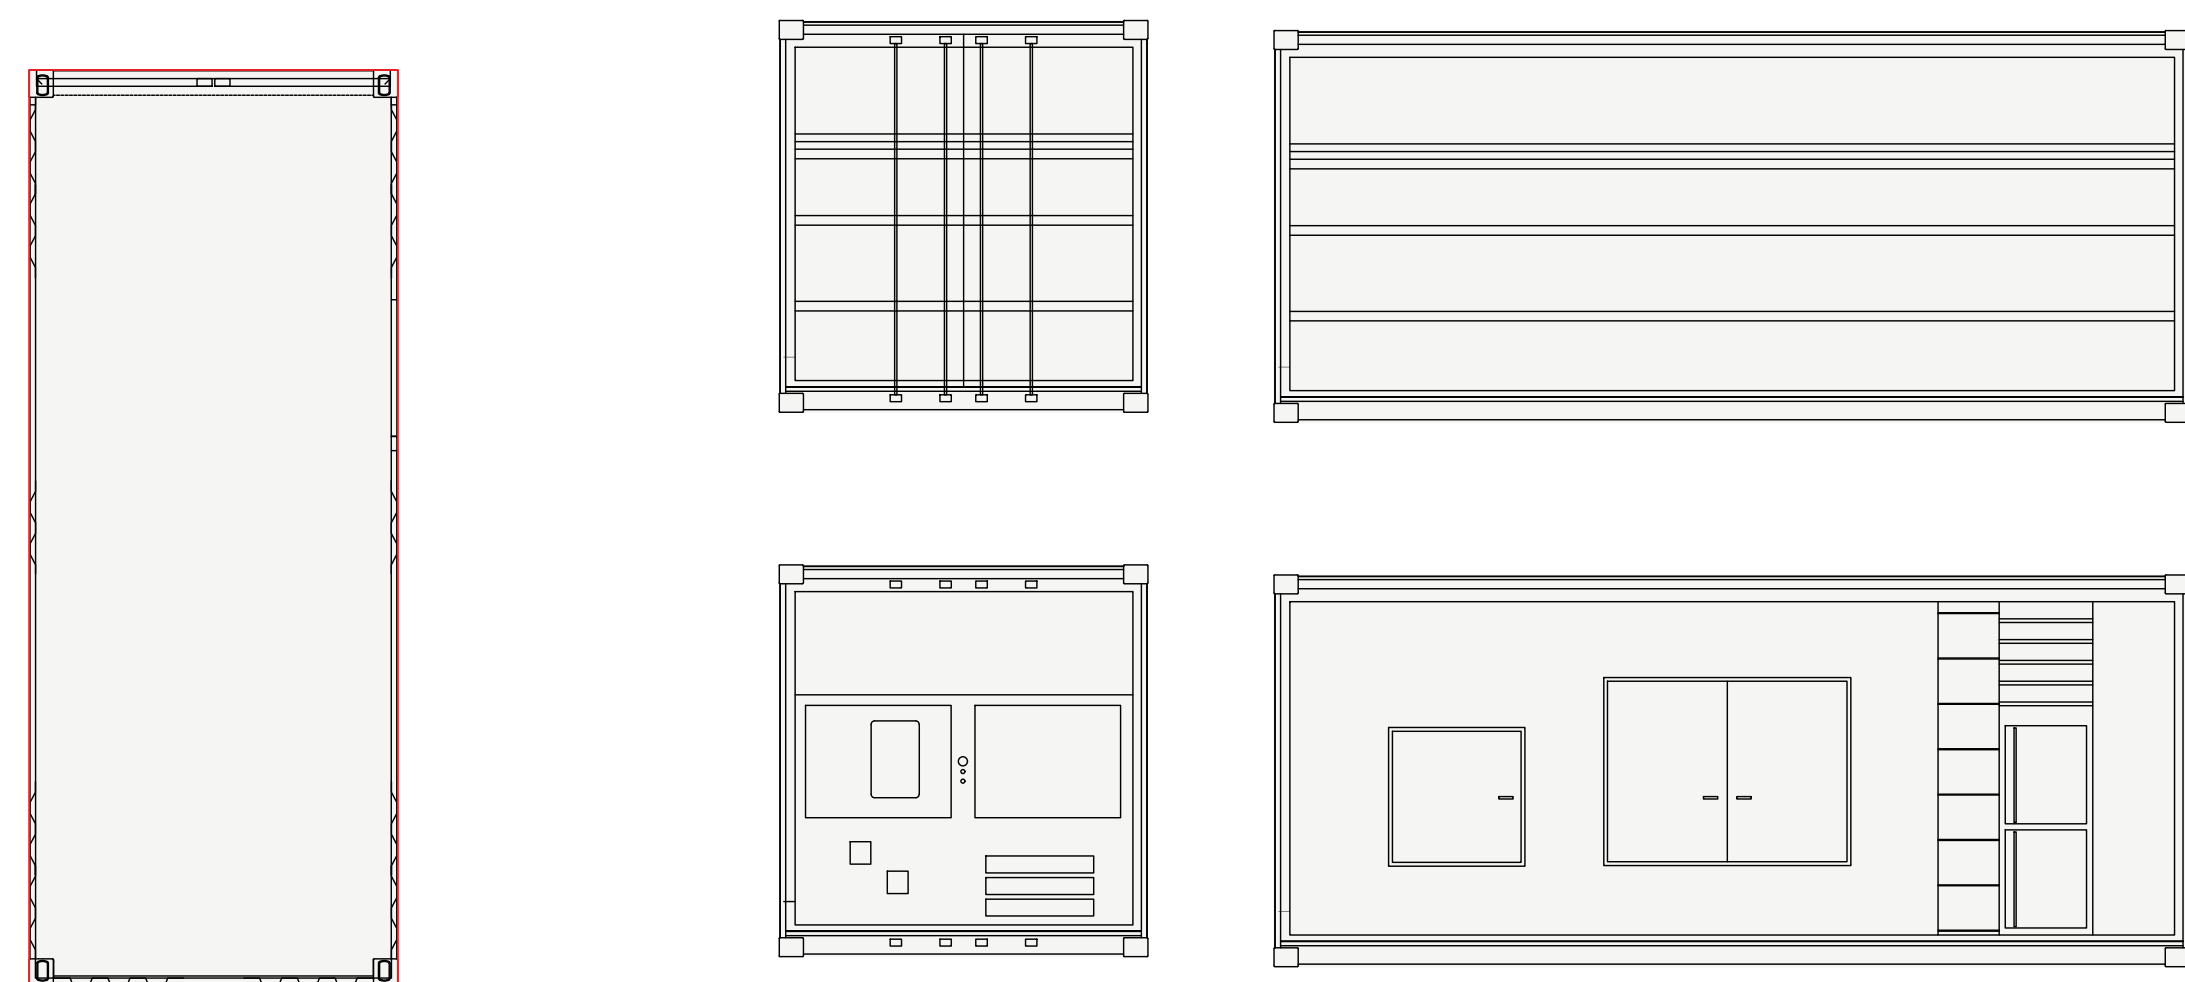

D Proposed Plan and Elevations of the LV Room

101 SCALE 1:100

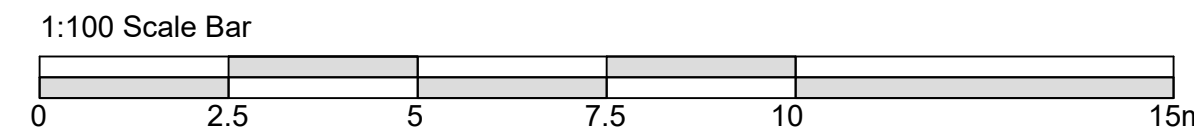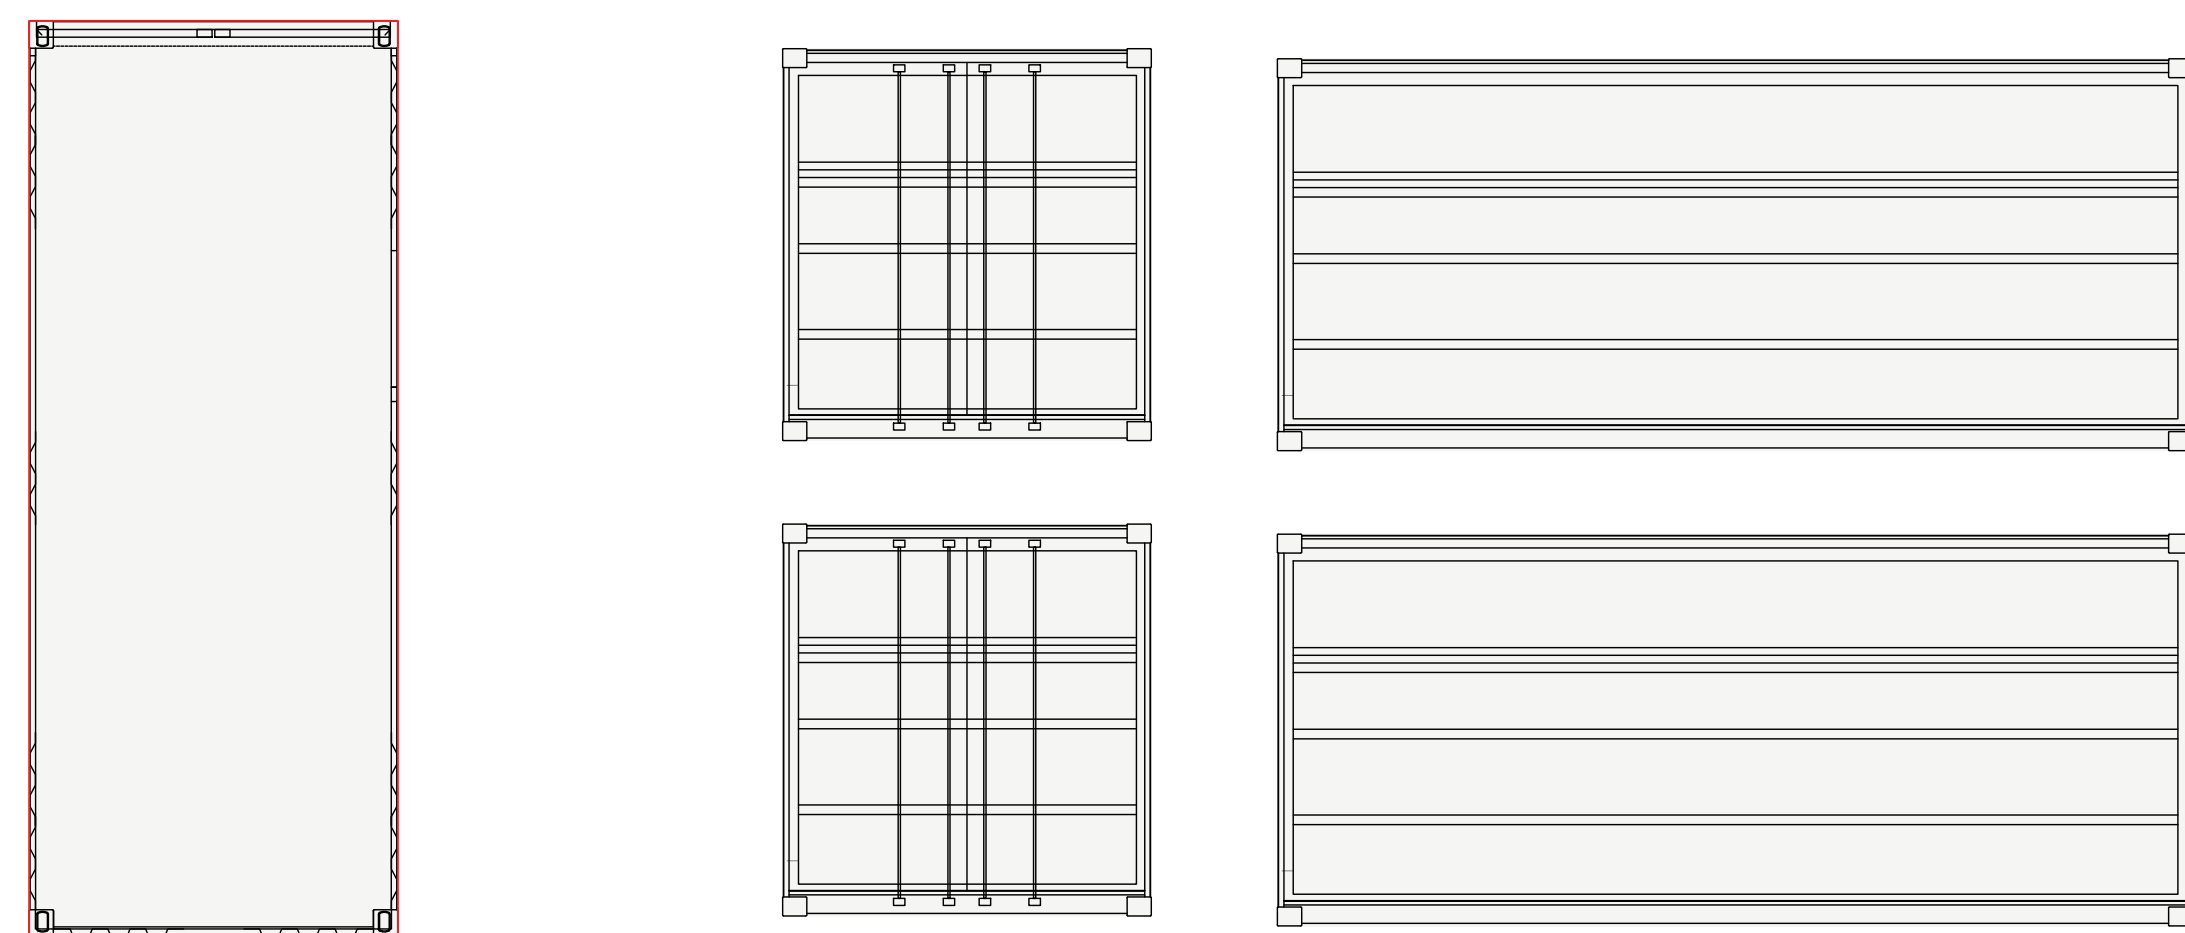

F Image of the Charging unit and Stand

101 SCALE 1:500

Denotes charging unit 50 number.



1.1	Additional information requested from Planners.	22.07.24
1.0	First Issue	10.06.24
rev	notes	date



This drawing and its contents, on paper and as the originating data file, remain the copyright of Meller & Co Meller 2024

Client	Martin Brower	Version	May 2024
Project	HGV Charging Points	Drawn by	+
Title	Proposed Plans and Elevations	Scale	1:100 1:500

240503	P 101	1.1	Planning
--------	-------	-----	----------