



NOTES:
All dimensions must be checked on site and not scaled from this drawing.

REV	DESCRIPTION	DATE	BY
AF	AS FITTED	12.05.23	MC

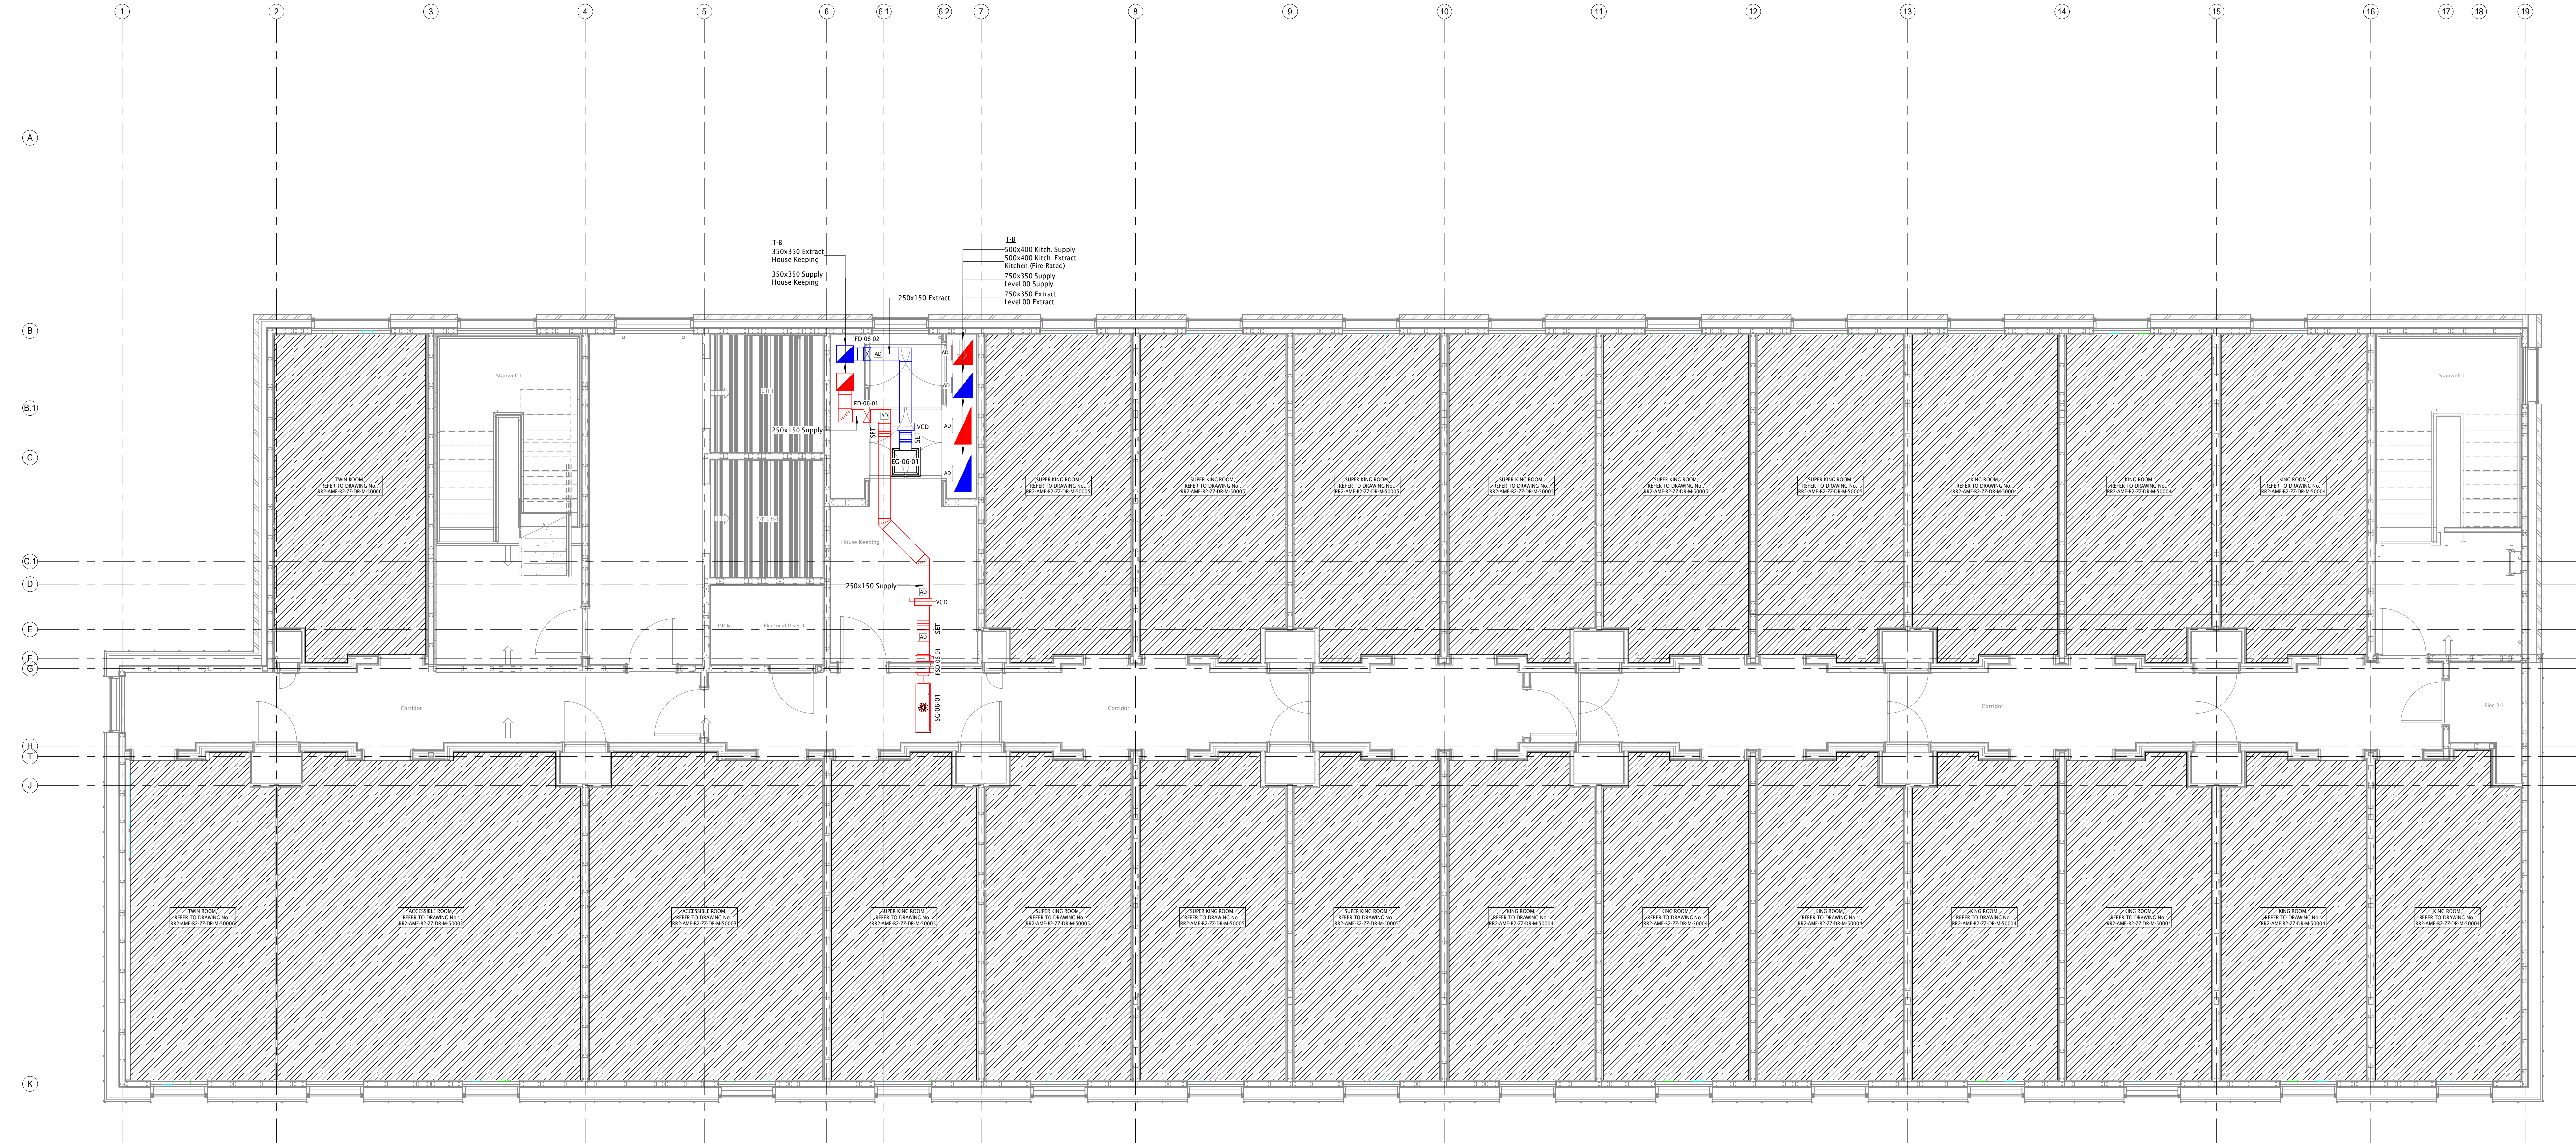

- GENERAL NOTES:
- ALL DIMENSIONS ARE IN MILLIMETRES UNLESS OTHERWISE STATED.
 - INSULATION INSTALLED ON ALL F.A.I AND EXHAUST DUCTWORK.
 - W.C. DOORS ARE UNDERCUT TO PROVIDE VENTILATION PATH ROUTES (10mm).
 - ACCESS PANELS INSTALLED AS PER SECTION 20 & TABLE 25 OF DW/144 DOCUMENT.
 - TO BE READ IN CONJUNCTION WITH 50 SERIES GUEST ROOM LAYOUTS
 - PLEASE REFER TO GUEST ROOM LAYOUTS FOR ACCESS HATCH, FIRE DAMPERS & ATTENUATOR SPECIFICS.
 - ALL OFFSETS TAKEN FROM STRUCTURAL SLAB LEVEL

VENTILATION LEGEND:

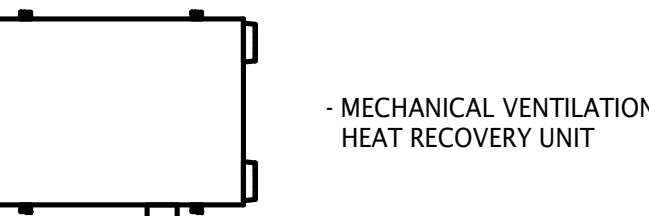

- INLINE EXTRACT FAN

- SUPPLY AIR GRILLE

- EXTRACT AIR GRILLE

- SUPPLY AIR VALVE

- EXTRACT AIR VALVE

- CEILING ACCESS HATCH

VCD - VOLUME CONTROL DAMPER

FD - FIRE DAMPER

AD - ACCESS DOOR

DUCTWORK ACCESS PANELS INSTALLED AS BELOW:

- VOLUME CONTROL DAMPERS:- BOTH SIDES
- ATTENUATORS:- BOTH SIDES
- INLINE FAN:- ONE SIDE
- CHANGE OF DIRECTION:- ONE SIDE
- INLET / EXHAUST LOUVRE:- ONE SIDE
- FIRE DAMPERS:- BOTH SIDES

DUCTWORK KEY:

- SUPPLY DUCT
- EXTRACT DUCT
- FRESH AIR INTAKE DUCT
- EXHAUST DUCT

Level 06 - Ventilation Layout
1 : 50

57 - Level 06 Extract Air Grille Schedule							
Ref	Location	Manufacturer	Model	Flow	Duct Diameter	Duct Height	Duct Width
EG-06-01	House Keeping	RCM Air Products	SQD/M/4/R300/F0/5	0.0 L/s	0	250	150

57 - Level 06 Supply Air Grille Schedule							
Ref	Location	Manufacturer	Model	Flow	Duct Diameter	Duct Height	Duct Width
SG-06-01	Corridor	RCM Air Products	LCD/32/2/RC/0/F0/3	95.0 L/s	0	150	9010

AS FITTED

Client	Job Title	Drawing Title	Date	Drawn by	Check by
WILLMOTT DIXON	Rochdale Riverside Ph2, Hampton by Hilton	Level 06 - Ventilation & AC Layout	17.05.22	MC	MD
			Scale of AD	Status	Revision
			1 : 50	CR	AF
			Drawing Number		
			RR2-AME-82-06-DR-M-57004		

ameon
Building Services Engineering
Unit 9-10 Olympic Court, Boardmans Way,
Whitehills Business Park, Blackpool, FY4 5GU
Tel: 01253 780160
E-mail: info@ameon.co.uk

0m 2m 4m 6m 8m 10m
VISUAL SCALE 1:100 @ A0