

1. ALL DIMENSIONS ARE IN mm UNLESS NOTED OTHERWISE
2. DRAWING TO SCALE WHEN PRINTED AT A3

N.G.R. E: 387305 N: 404482

DIRECTIONS TO SITE:

LEAVE THE M60 AT JUNCTION 20, THEN KEEP LEFT AT JUNCTION 20 AND TURN LEFT ONTO A644 ROCHDALE ROAD. TRAVEL FOR 0.3 MILES AND THEN TURN RIGHT ONTO MAINWAY. AFTER 0.4 MILES TURN RIGHT INTO KIRKWAY AND TRAVEL 0.1 MILES. THE SITE IS LOCATED ON THE LEFT HAND SIDE OF KIRKWAY. PARKING IS AVAILABLE ON SITE AT KIRKWAY SERVICE STATION.

NOTES:

B	Site Demise Amended	AF	IDP	01.10.24
A	Issued for Construction	AF	DP	27.06.24
REV	MODIFICATION	BY	CH	DATE



WHP Telecoms Ltd
Faraday Court
401 Faraday Street
Birchwood Park
Warrington WA3 6GA
Tel: 01925 424100 Fax: 01925 424101
e-mail: info@whptelecoms.com



 


vodafone
CTIL - LONDON

Cell Name		Opt.
KIRKWAY SERVICE STATION		
Cell ID No		
CTIL	TEF	VF
132123	044916	74812

Site Address / Contact Details		
KIRKWAY	ALKRINGTON	
MIDDLETON	M24 1LW	

Drawing Title: SITE LOCATION MAPS				
Purpose of Issue: CONSTRUCTION				Dwg Rev:
Drawing Number: 100				B
Surveyed By: AH		Original Sheet Size: A3		Pack Issue:
Drawn: AF	Date: 27.06.24	Checked: DP	Date: 27.06.24	B


SITE LOCATION

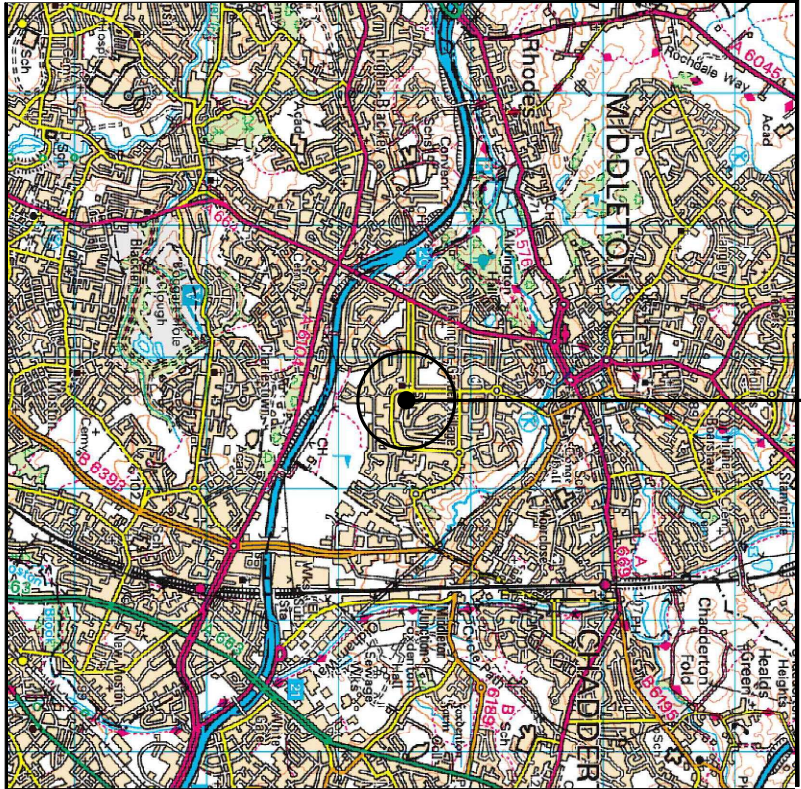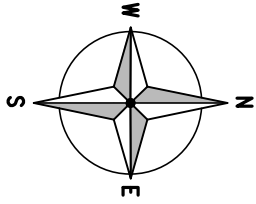

SITE LOCATION
(Scale 1:50000)

SITE LOCATION

-  = Site Access
-  = Access Route

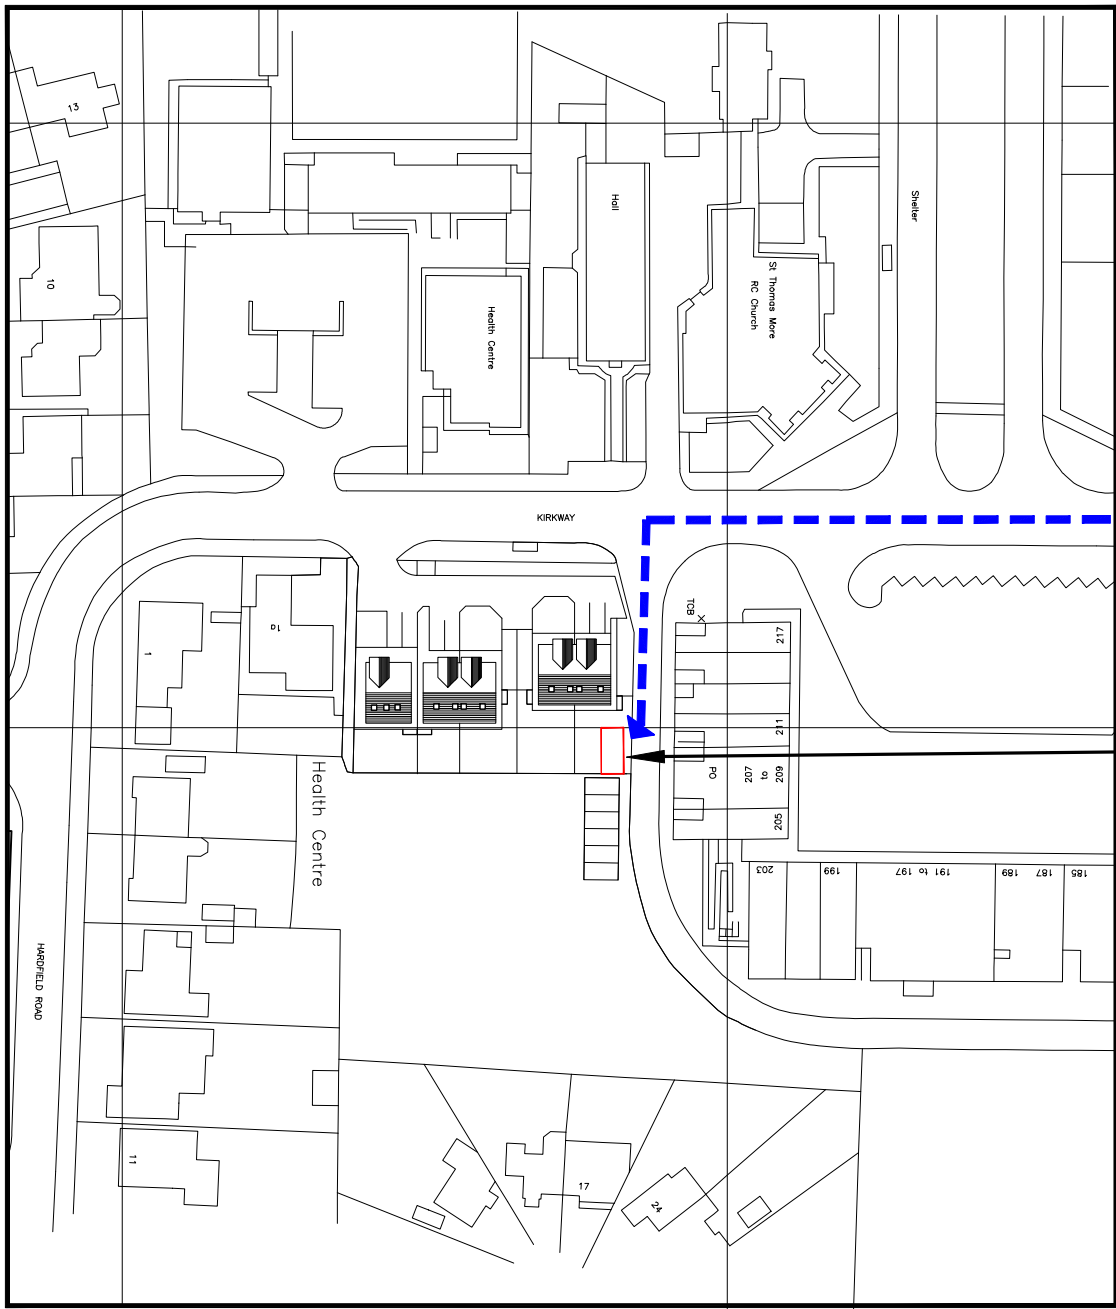



4044.00

4045.00


3872.00

3873.00

 DETAILED SITE LOCATION
(Scale 1:1250)

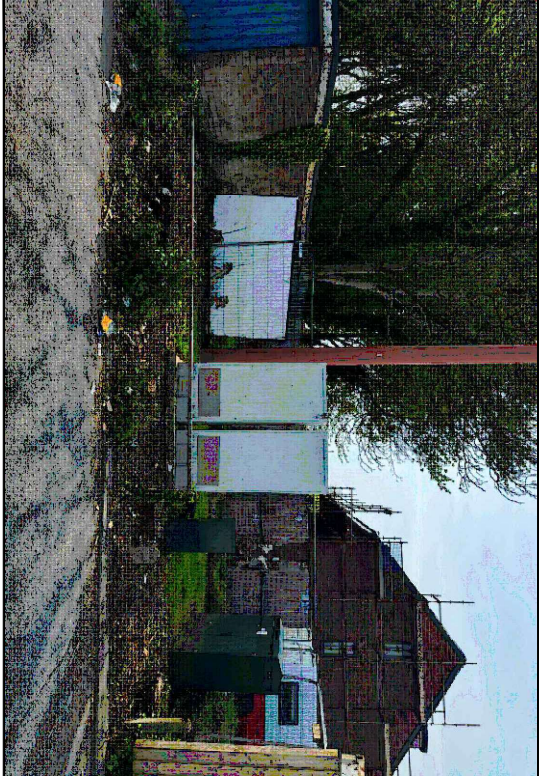

SITE PHOTOGRAPH

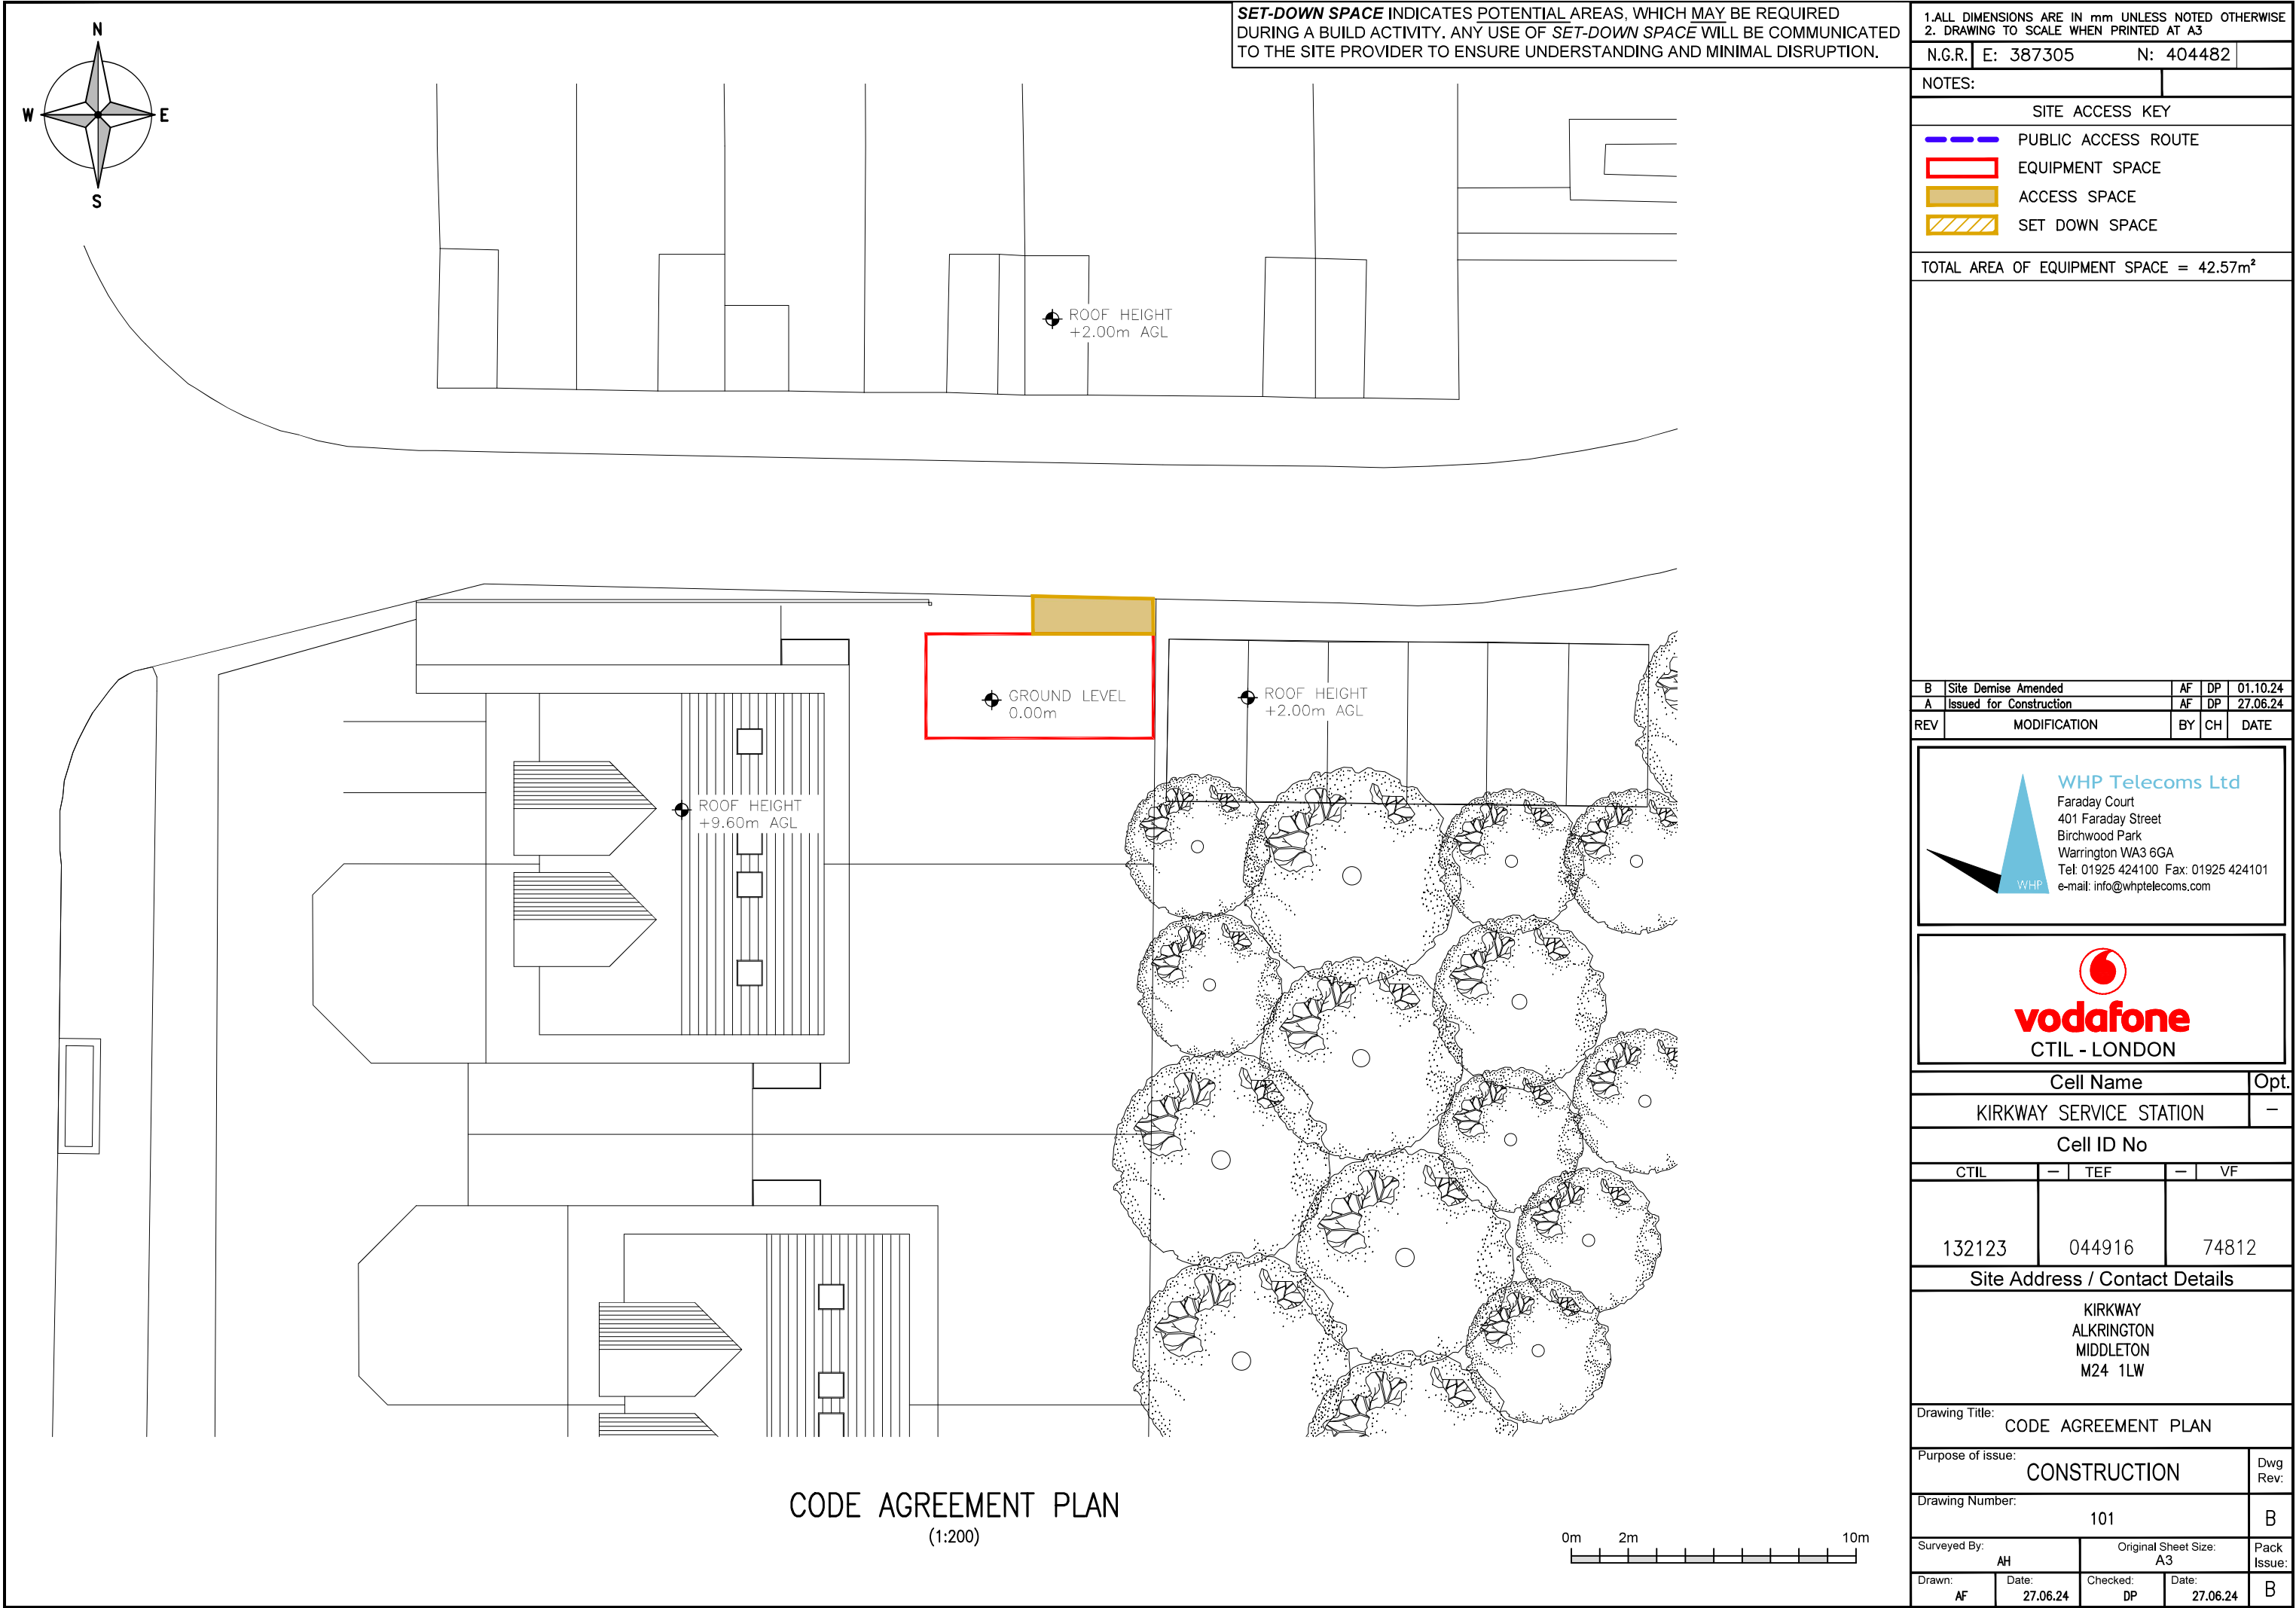

SET-DOWN SPACE INDICATES POTENTIAL AREAS, WHICH MAY BE REQUIRED DURING A BUILD ACTIVITY. ANY USE OF SET-DOWN SPACE WILL BE COMMUNICATED TO THE SITE PROVIDER TO ENSURE UNDERSTANDING AND MINIMAL DISRUPTION.

1.ALL DIMENSIONS ARE IN mm UNLESS NOTED OTHERWISE
2. DRAWING TO SCALE WHEN PRINTED AT A3

N.G.R. E: 387305 N: 404482

NOTES:

SITE ACCESS KEY	
---	PUBLIC ACCESS ROUTE
	EQUIPMENT SPACE
	ACCESS SPACE
	SET DOWN SPACE

TOTAL AREA OF EQUIPMENT SPACE = 42.57m²

B	Site Demise Amended	AF	DP	01.10.24
A	Issued for Construction	AF	DP	27.06.24
REV	MODIFICATION	BY	CH	DATE



WHP Telecoms Ltd
Faraday Court
401 Faraday Street
Birchwood Park
Warrington WA3 6GA
Tel: 01925 424100 Fax: 01925 424101
e-mail: info@whptelecoms.com





vodafone
CTIL - LONDON

Cell Name				Opt.
KIRKWAY SERVICE STATION				—
Cell ID No				
CTIL	—	TEF	—	VF
132123	044916	74812		

Site Address / Contact Details

KIRKWAY
ALKRINGTON
MIDDLETON
M24 1LW

Drawing Title: CODE AGREEMENT PLAN				
Purpose of issue: CONSTRUCTION				Dwg Rev:
Drawing Number: 101				B
Surveyed By: AH	Original Sheet Size: A3		Pack Issue:	
Drawn: AF	Date: 27.06.24	Checked: DP	Date: 27.06.24	B

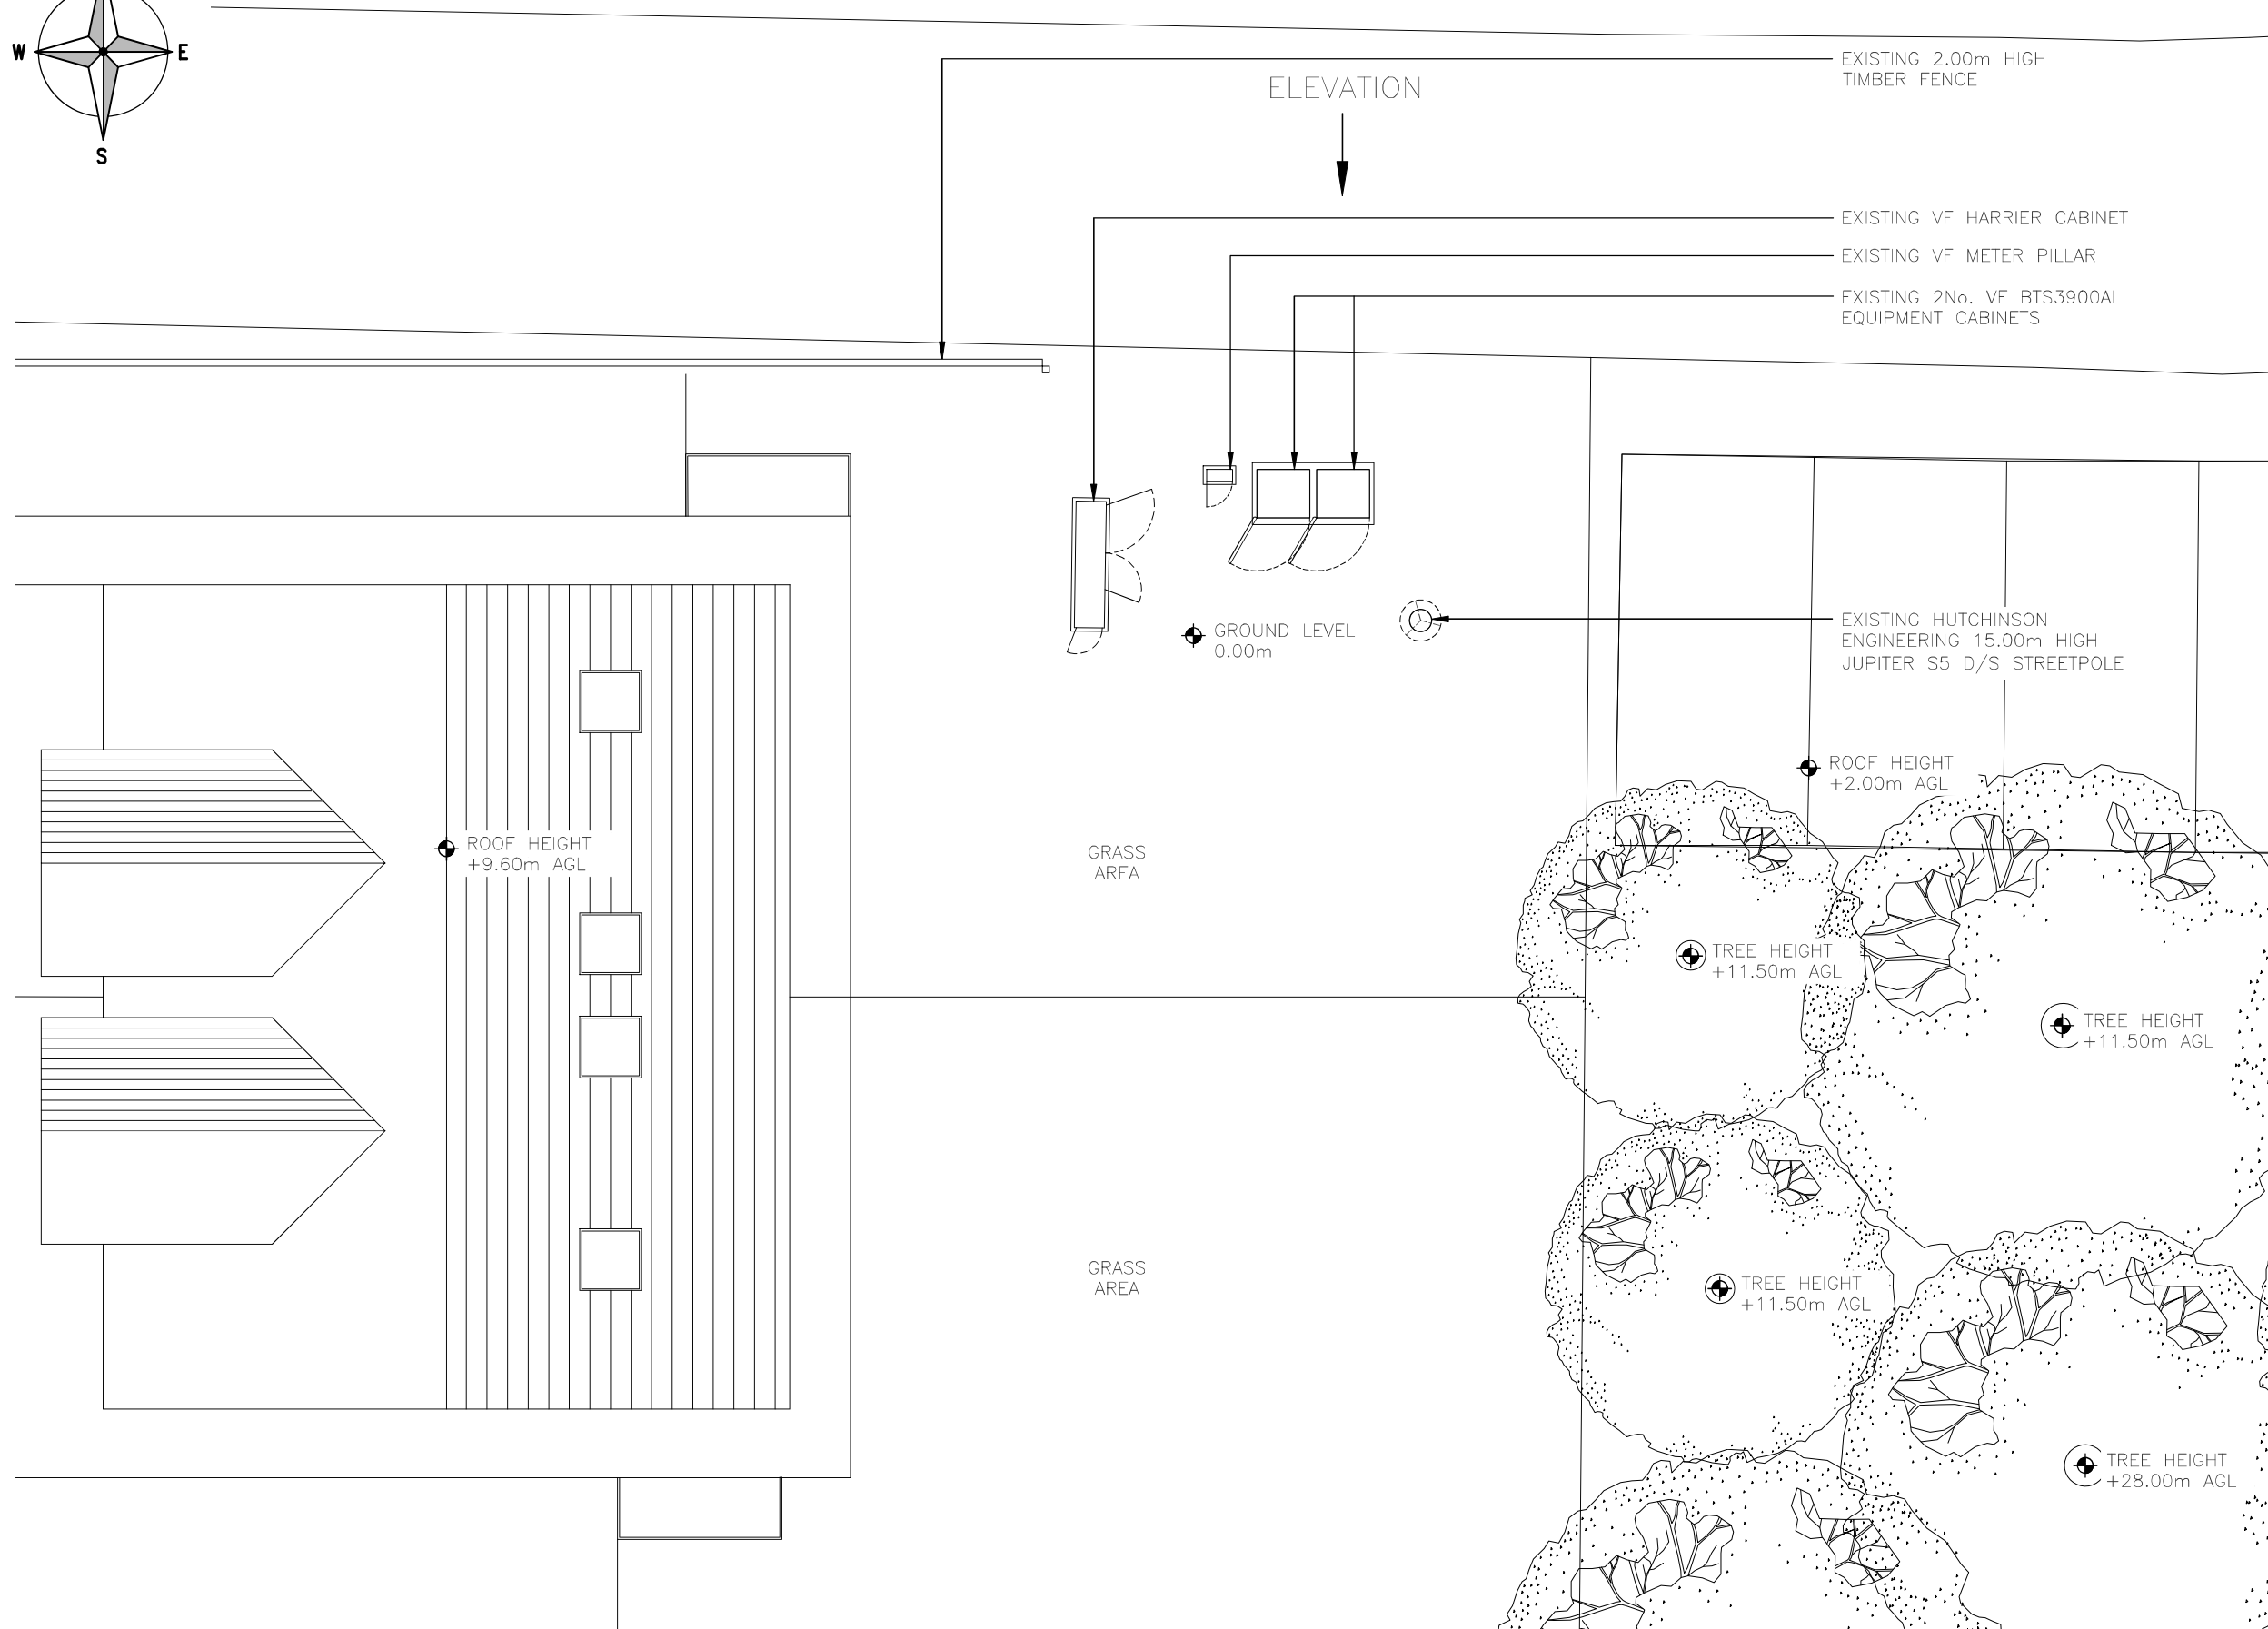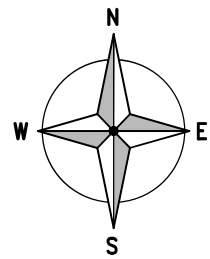

EXISTING SITE PLAN
(1:100)



1. ALL DIMENSIONS ARE IN mm UNLESS NOTED OTHERWISE
2. DRAWING TO SCALE WHEN PRINTED AT A3

N.G.R. E: 387305 N: 404482

NOTES:

A	Issued for Construction	AF	DP	27.06.24
REV	MODIFICATION	BY	CH	DATE



WHP Telecoms Ltd
Faraday Court
401 Faraday Street
Birchwood Park
Warrington WA3 6GA
Tel: 01925 424100 Fax: 01925 424101
e-mail: info@whptelecoms.com



vodafone
CTIL - LONDON

Cell Name Opt.

KIRKWAY SERVICE STATION

Cell ID No

CTIL	TEF	VF
------	-----	----

132123	044916	74812
--------	--------	-------

Site Address / Contact Details

KIRKWAY
ALKRINGTON
MIDDLETON
M24 1LW


Drawing Title: EXISTING SITE PLAN

Purpose of issue:	CONSTRUCTION	Dwg Rev:
-------------------	--------------	----------

Drawing Number:	200	A
-----------------	-----	---

Surveyed By:	AH	Original Sheet Size:	A3	Pack Issue:
--------------	----	----------------------	----	-------------

Drawn:	JP	Date:	03.06.24	Checked:	DP	Date:	03.06.24	B
--------	----	-------	----------	----------	----	-------	----------	---

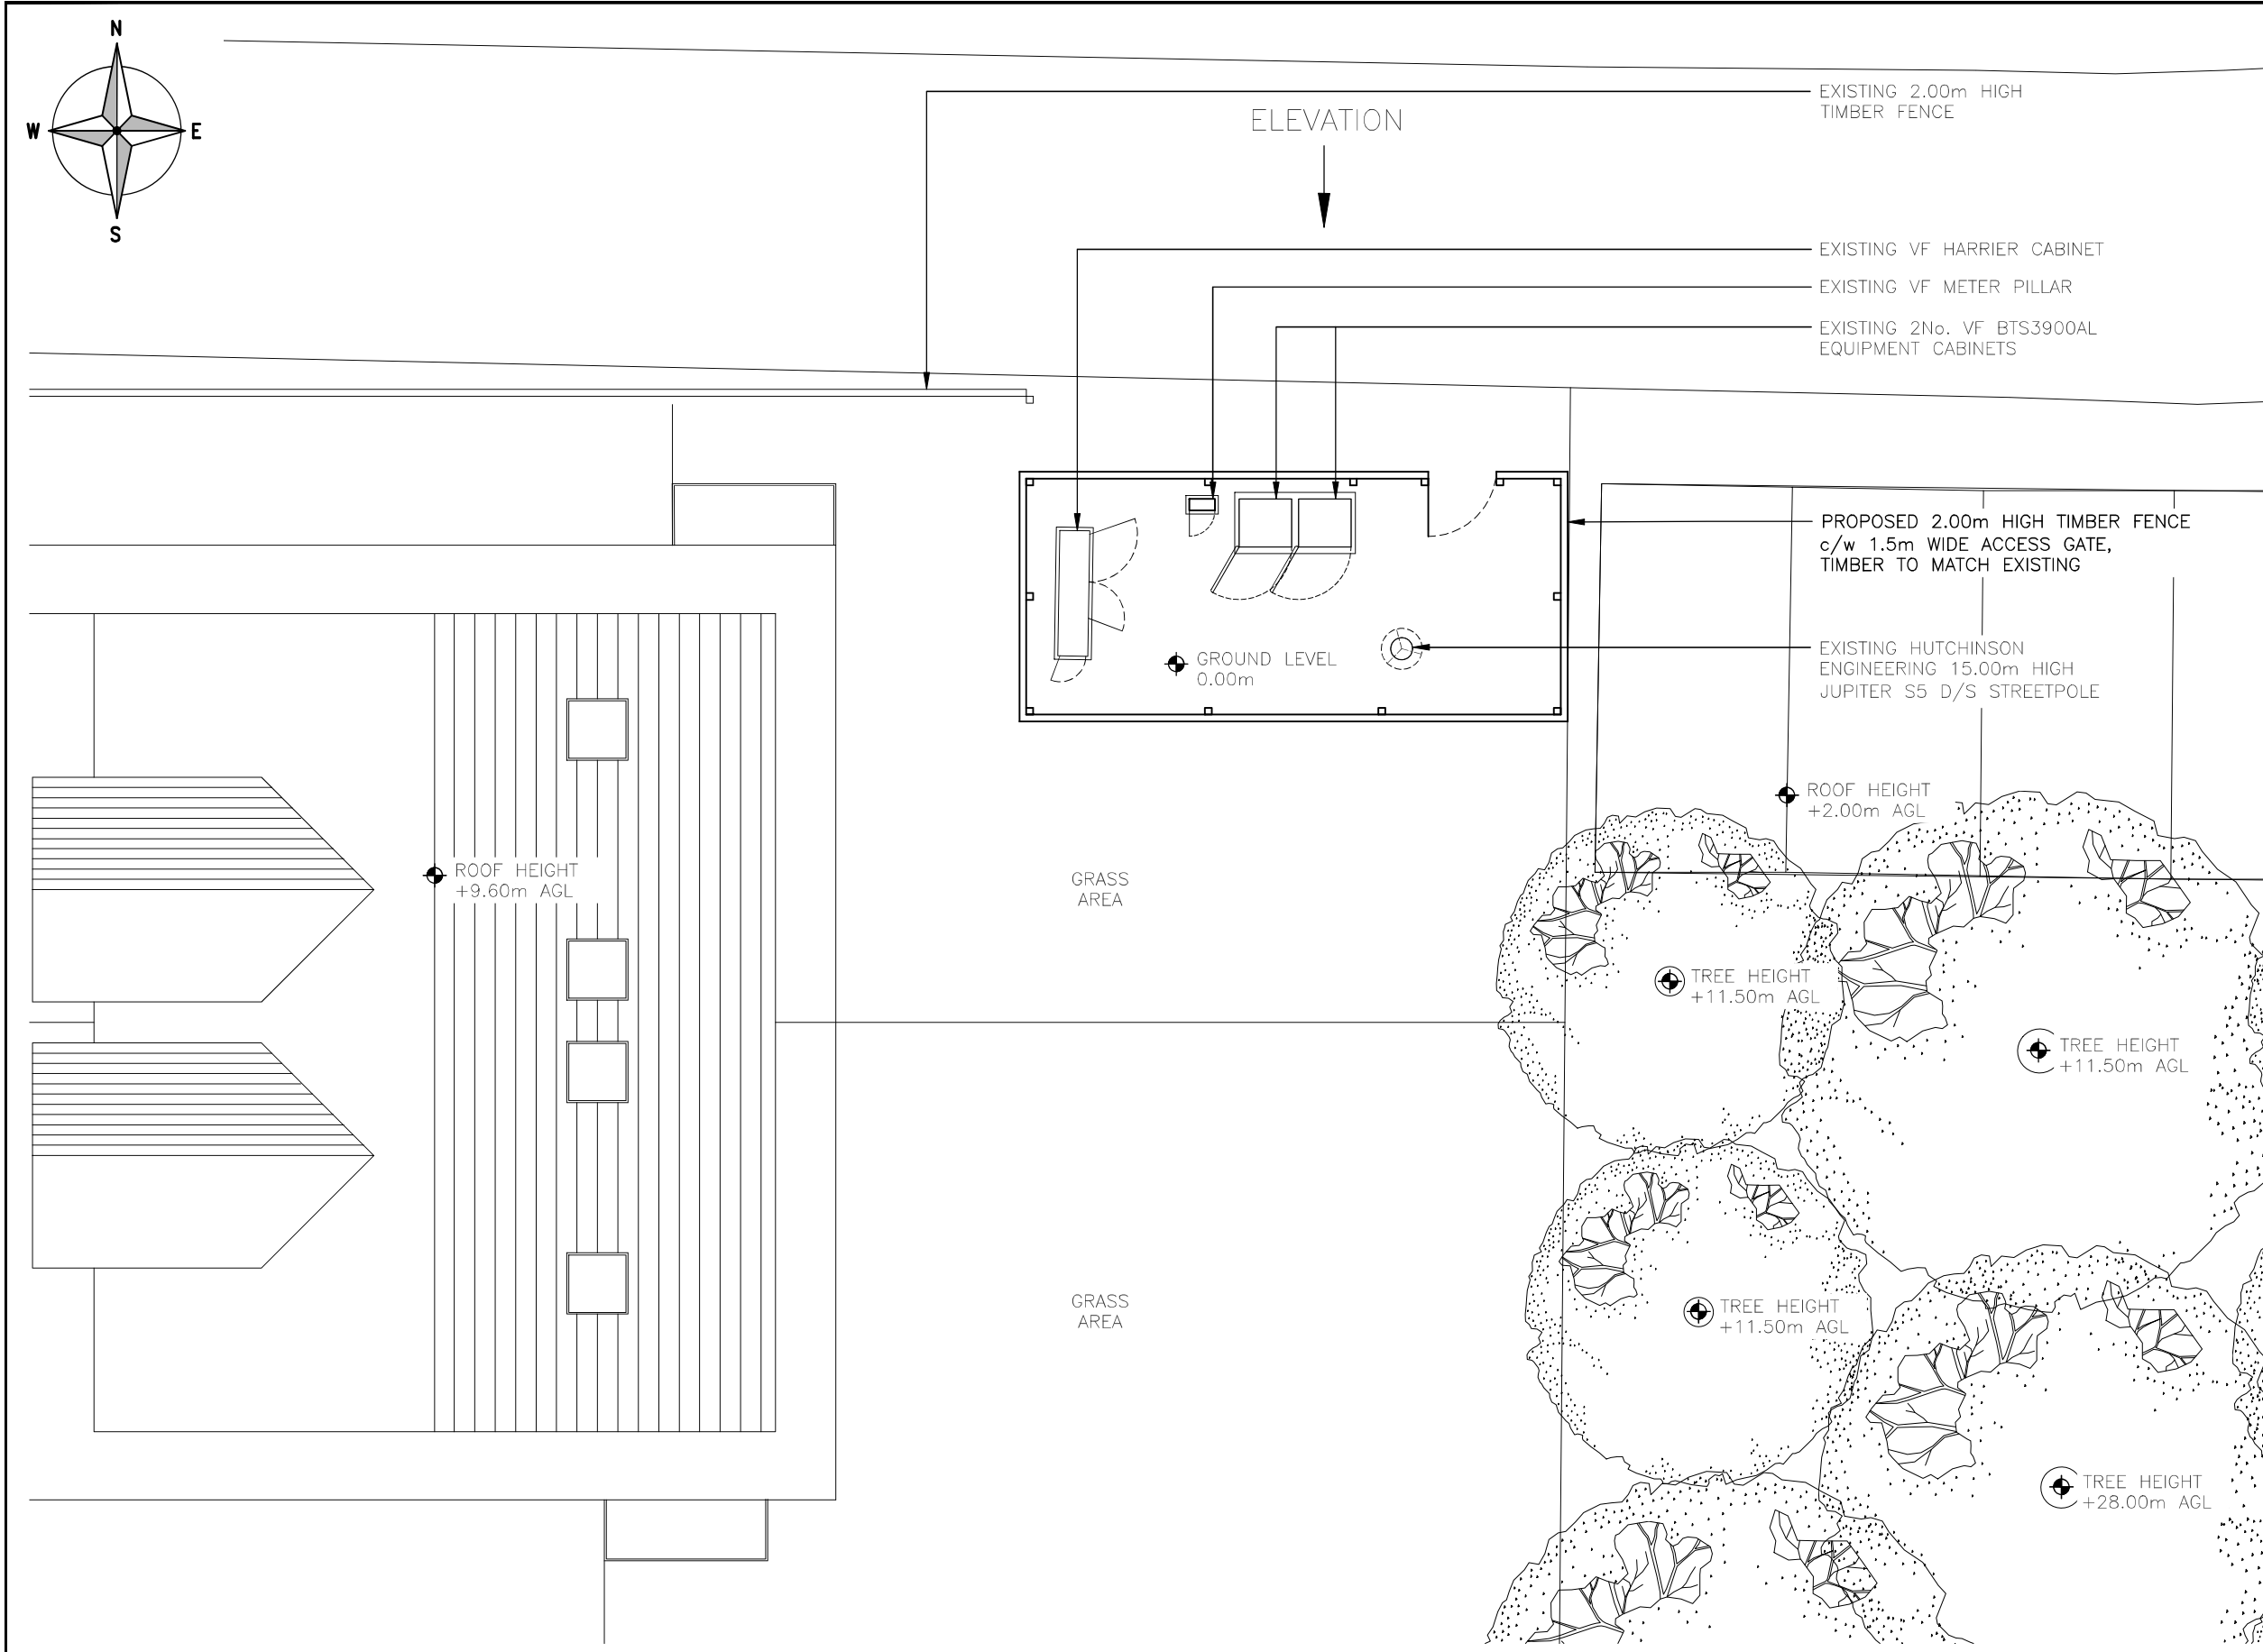

PROPOSED SITE PLAN
(1:100)

1. ALL DIMENSIONS ARE IN mm UNLESS NOTED OTHERWISE
2. DRAWING TO SCALE WHEN PRINTED AT A3

N.G.R. E: 387305 N: 404482

NOTES:

B	Site Demise Amended	AF	DP	01.10.24
A	Issued for Construction	AF	DP	27.06.24
REV	MODIFICATION	BY	CH	DATE



WHP Telecoms Ltd
Faraday Court
401 Faraday Street
Birchwood Park
Warrington WA3 6GA
Tel: 01925 424100 Fax: 01925 424101
e-mail: info@whptelecoms.com



vodafone
CTIL - LONDON

Cell Name

KIRKWAY SERVICE STATION

Cell ID No

CTIL TEF VF

132123 044916 74812

Site Address / Contact Details

KIRKWAY
ALKRINGTON
MIDDLETON
M24 1LW


Drawing Title: PROPOSED SITE PLAN

Purpose of issue: CONSTRUCTION

Drawing Number: 201

Surveyed By: AH Original Sheet Size: A3

Drawn: AF Date: 27.06.24 Checked: DP Date: 27.06.24

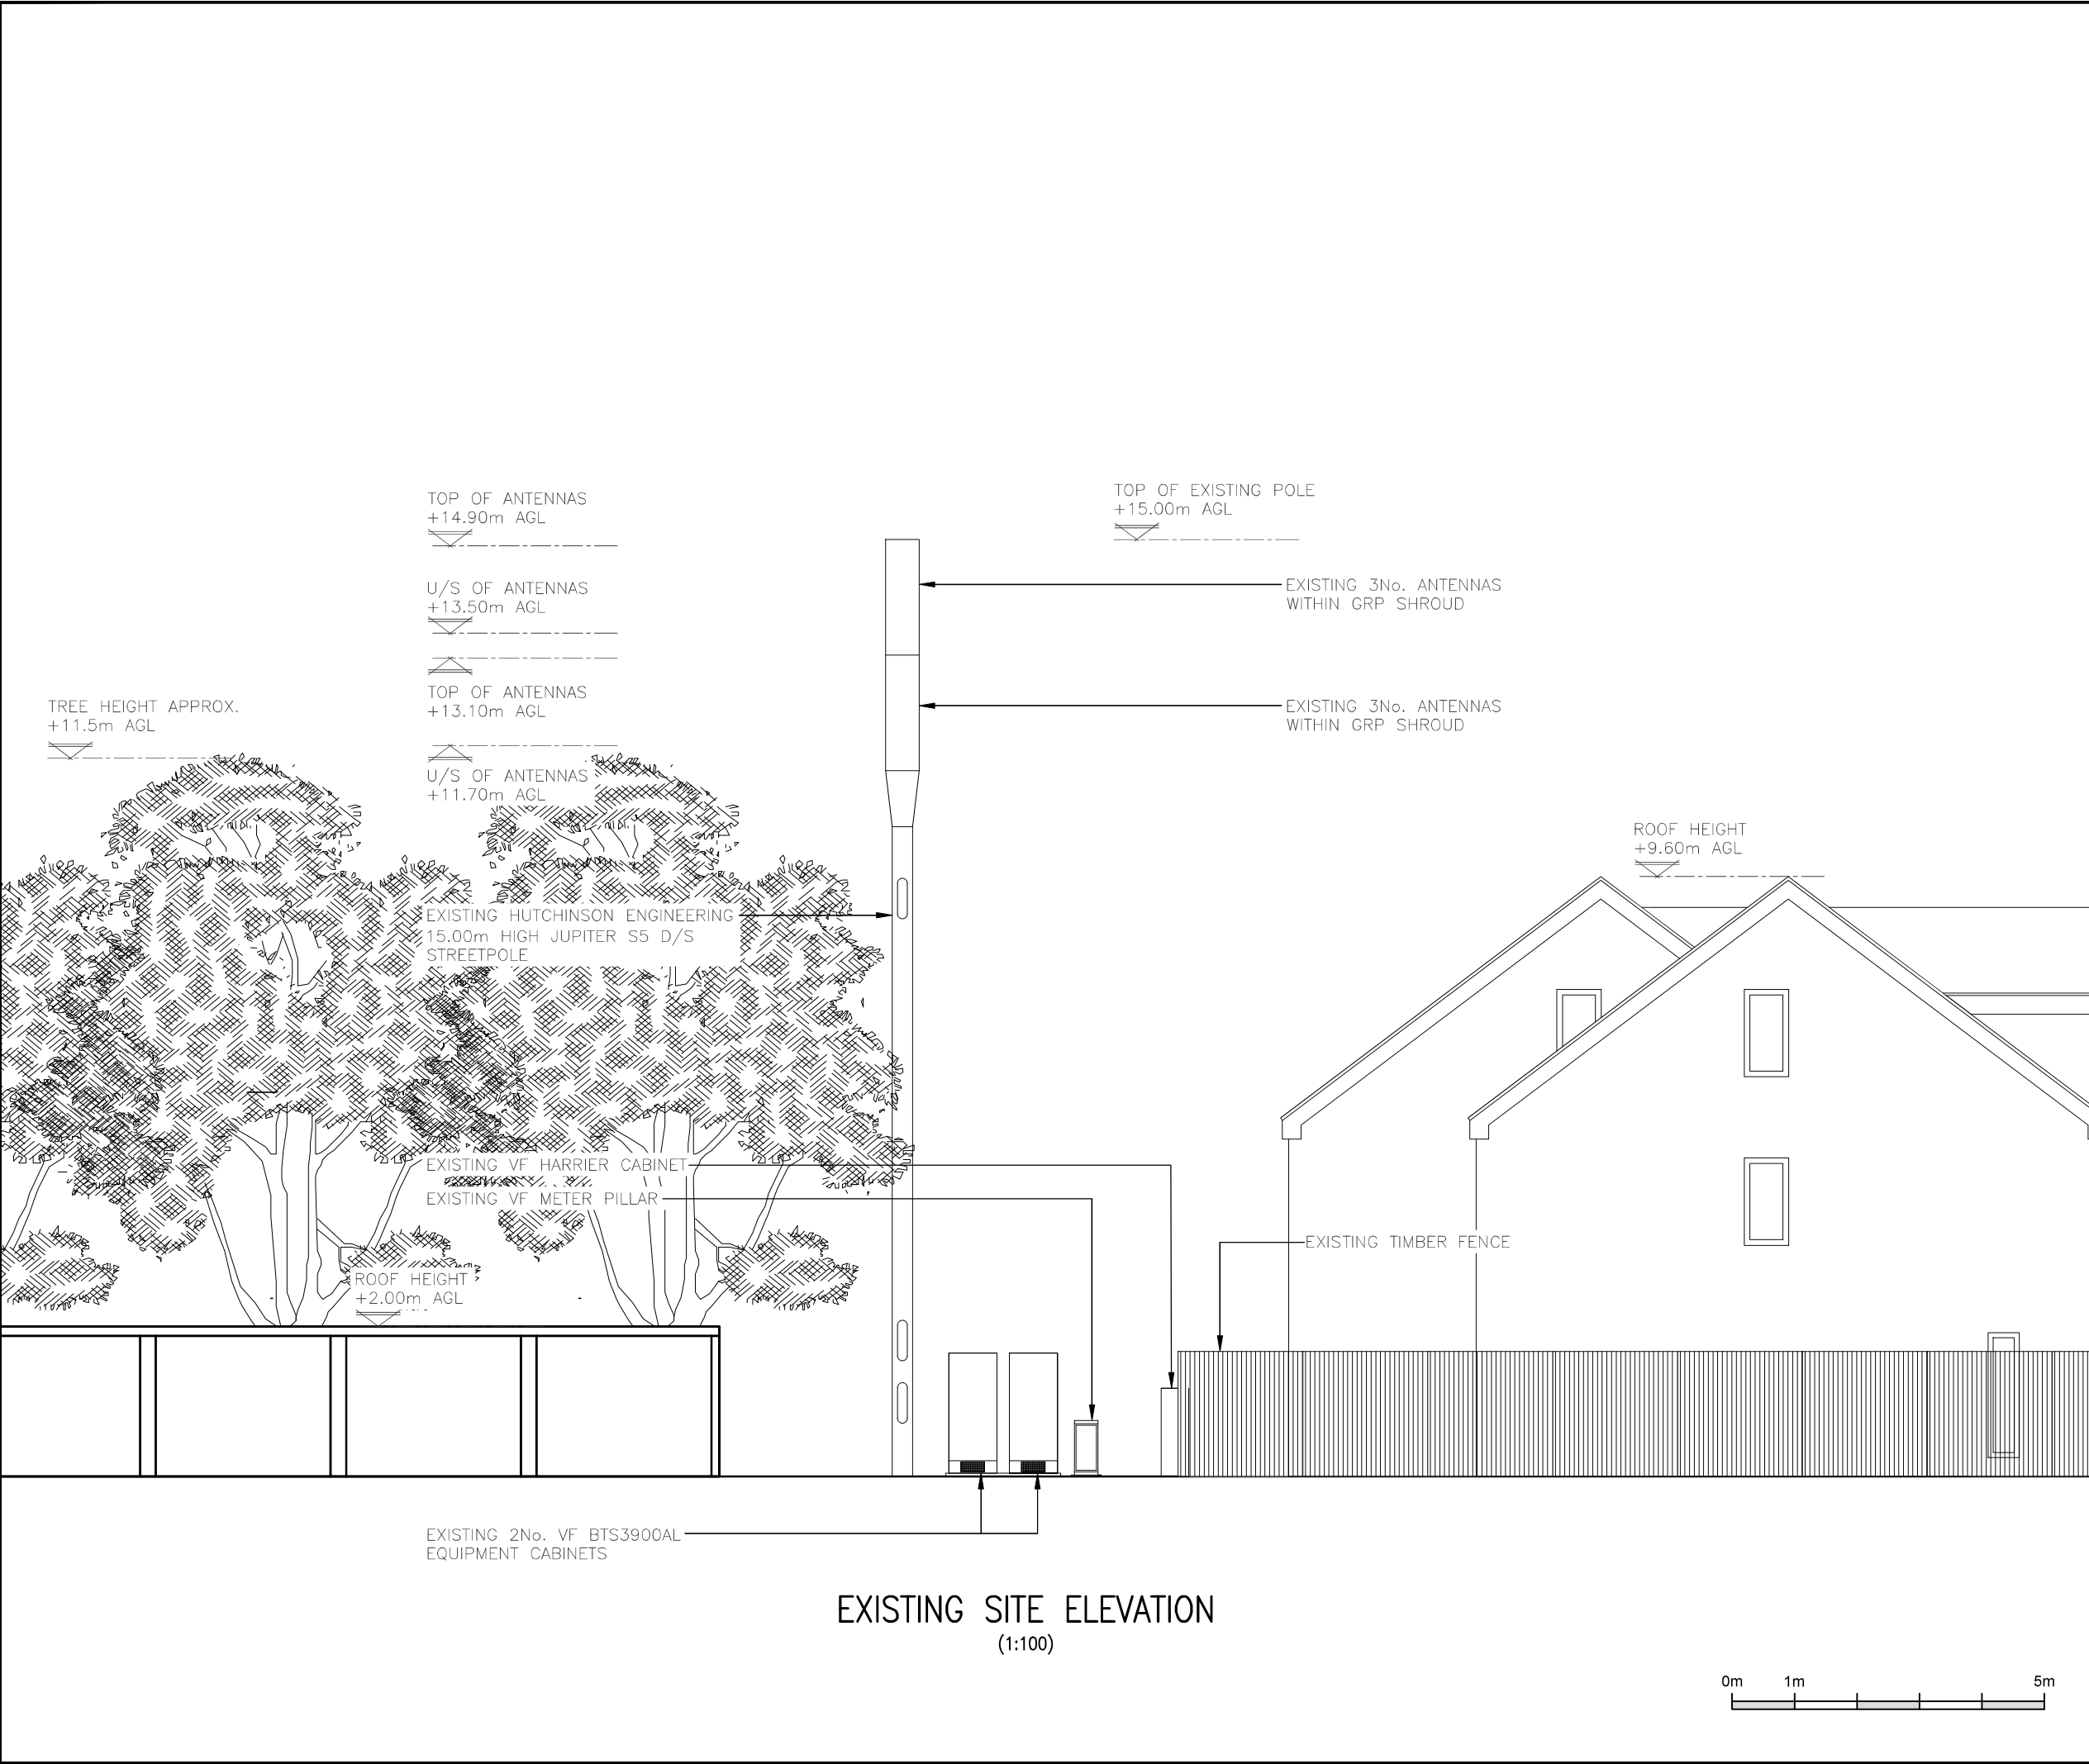

1.ALL DIMENSIONS ARE IN mm UNLESS NOTED OTHERWISE
2. DRAWING TO SCALE WHEN PRINTED AT A3

N.G.R. E: 387305

N: 404482

NOTES:

A	Issued for Construction	AF	DP	27.06.24
REV	MODIFICATION	BY	CH	DATE



WHP Telecoms Ltd
Faraday Court
401 Faraday Street
Birchwood Park
Warrington WA3 6GA
Tel: 01925 424100 Fax: 01925 424101
e-mail: info@whptelecoms.com



vodafone
CTIL - LONDON

Cell Name			Opt.
KIRKWAY SERVICE STATION			
Cell ID No			
CTIL	TEF	VF	
132123	044916	74812	
Site Address / Contact Details			
KIRKWAY ALKRINGTON MIDDLETON M24 1LW			

Drawing Title:
EXISTING SITE ELEVATION

Purpose of issue:
CONSTRUCTION

Dwg Rev:

Drawing Number:
300

A

Surveyed By:
AH

Original Sheet Size:
A3

Pack Issue:

Drawn:
AF


Date:
27.06.24

Checked:
DP

Date:
27.06.24

B



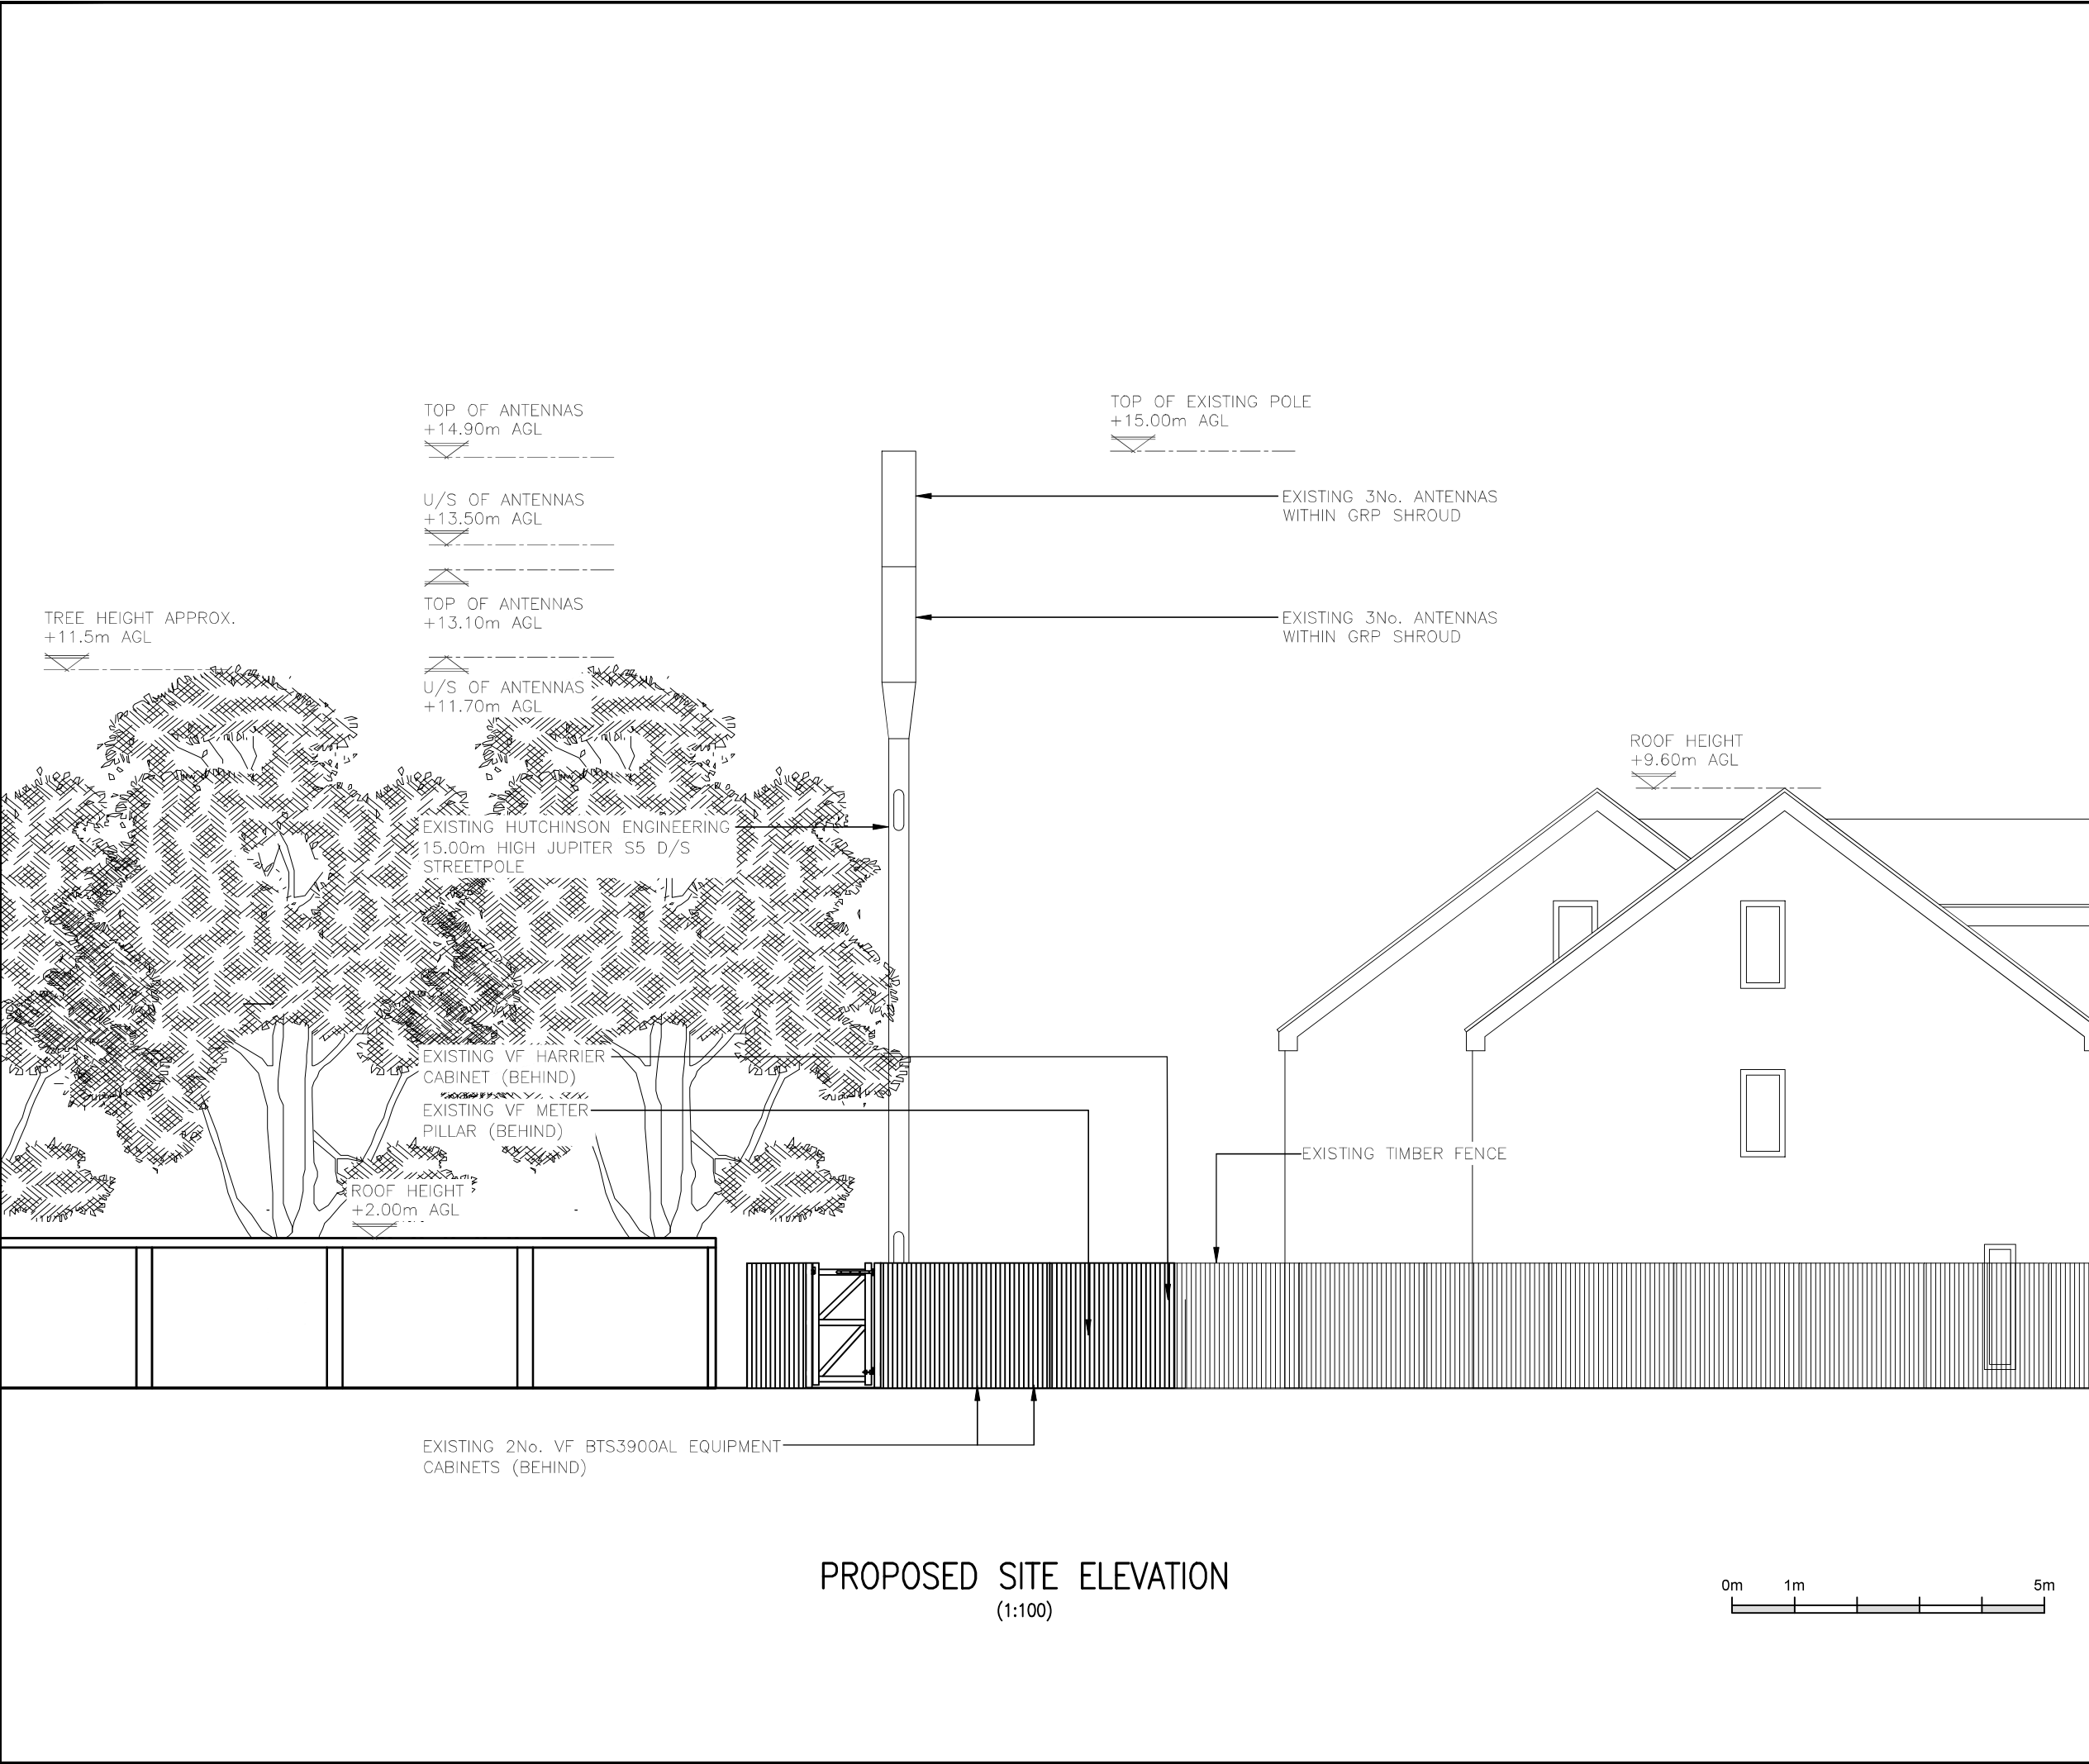

1.ALL DIMENSIONS ARE IN mm UNLESS NOTED OTHERWISE
2. DRAWING TO SCALE WHEN PRINTED AT A3

N.G.R. E: 387305

N: 404482

NOTES:

A	Issued for Construction	AF	DP	27.06.24
REV	MODIFICATION	BY	CH	DATE



WHP Telecoms Ltd
Faraday Court
401 Faraday Street
Birchwood Park
Warrington WA3 6GA
Tel: 01925 424100 Fax: 01925 424101
e-mail: info@whptelecoms.com

**vodafone**
CTIL - LONDON

Cell Name			Opt.
KIRKWAY SERVICE STATION			
Cell ID No			
CTIL	TEF	VF	
132123	044916	74812	
Site Address / Contact Details			
KIRKWAY ALKRINGTON MIDDLETON M24 1LW			

Drawing Title:
PROPOSED SITE ELEVATION

Purpose of issue: CONSTRUCTION		Dwg Rev:
Drawing Number: 301		A
Surveyed By: AH	Original Sheet Size: A3	Pack Issue:
Drawn: AF	Date: 27.06.24	Checked: DP
	Date: 27.06.24	B