


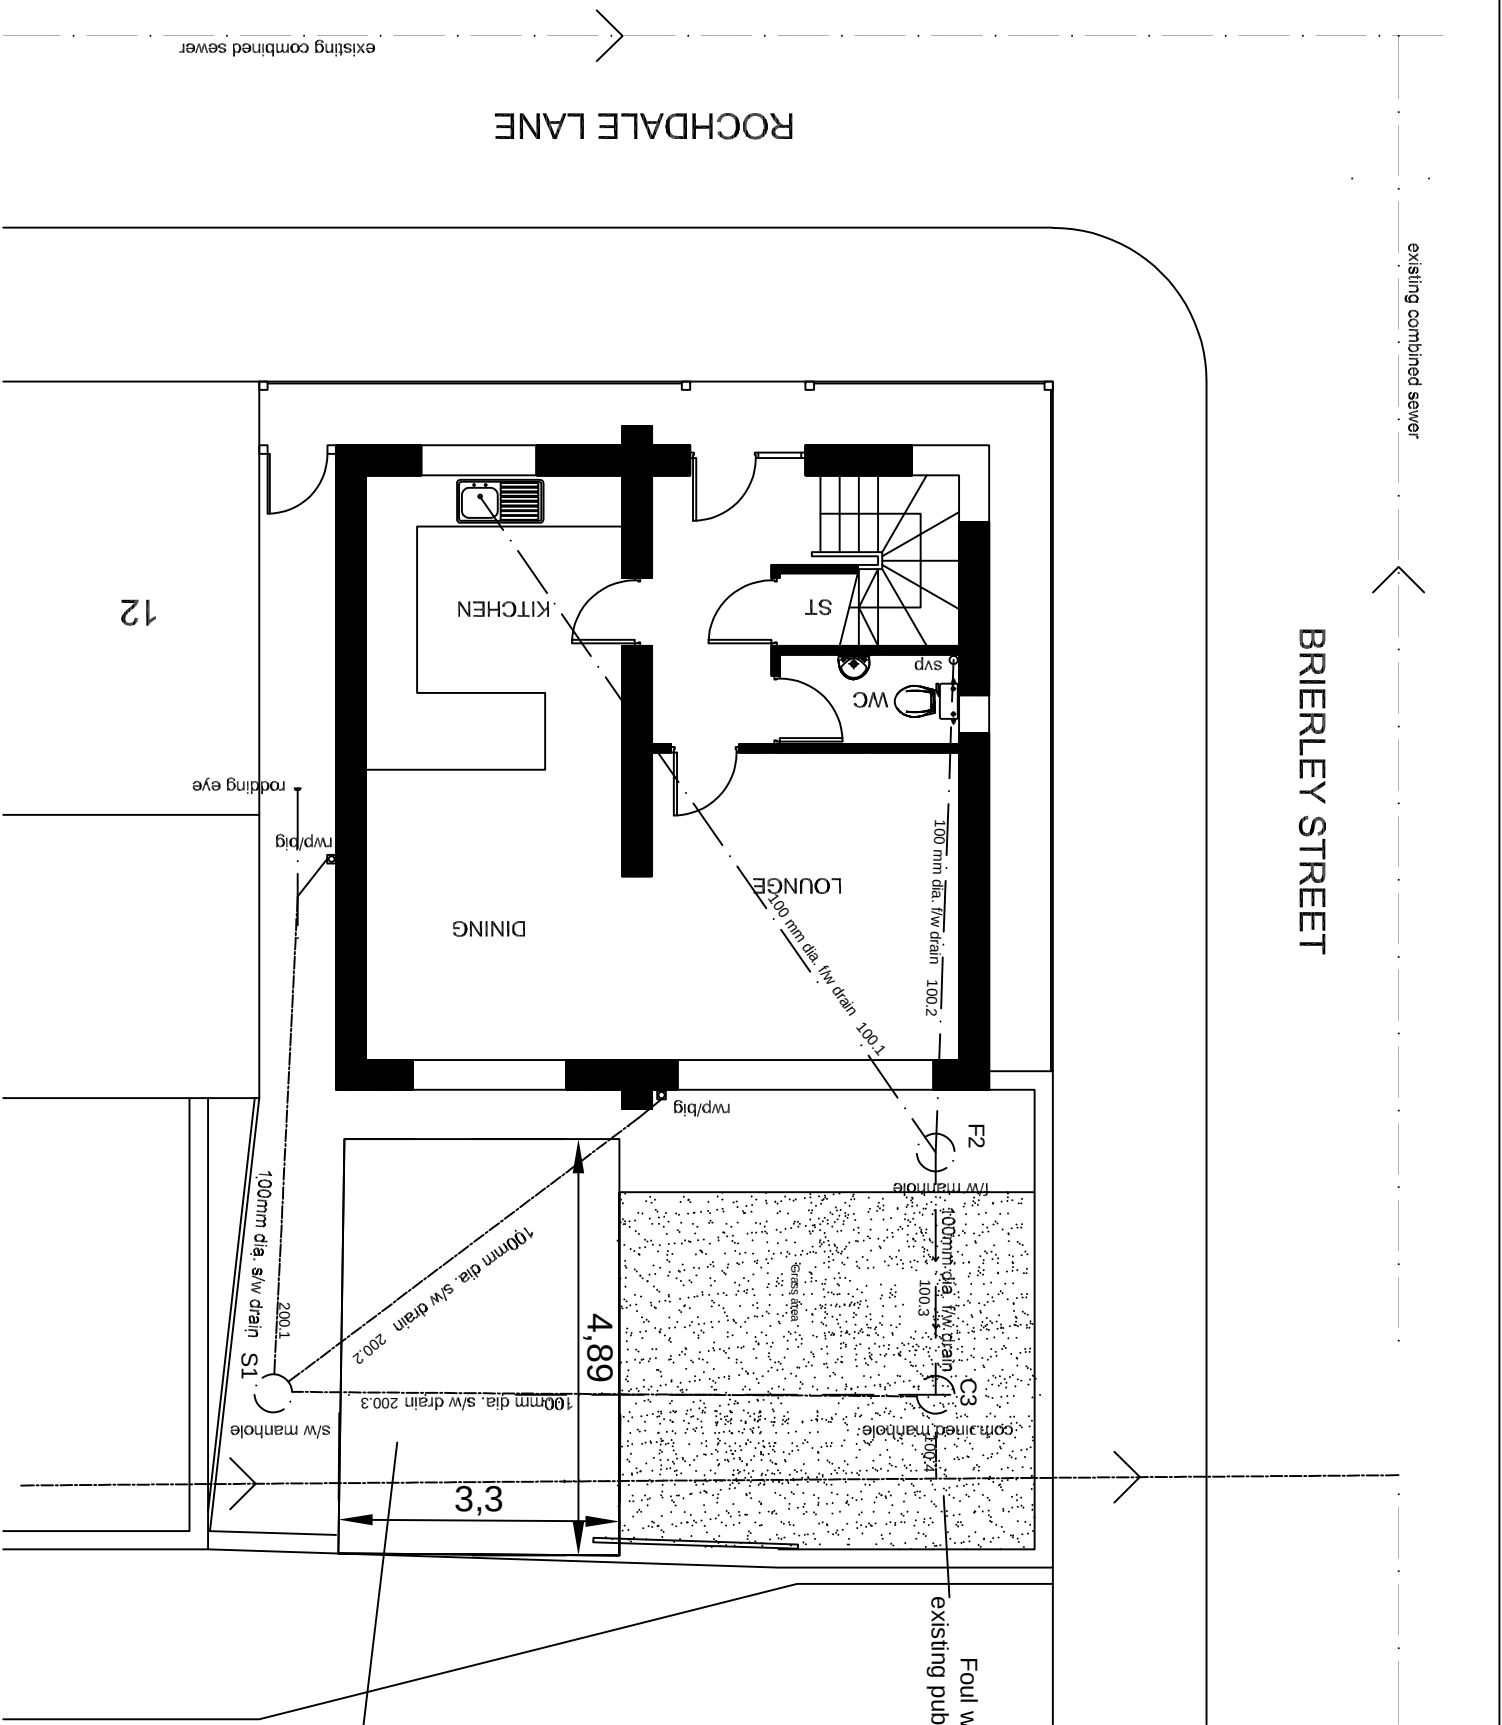

Foul Water Network 1									
Pipe Code	Diameter (mm)	Gradient (1:)	Pipe Type	Pipe Length	Number	Upstream Manhole		Downstream Manhole	
						Invert	Cover	Number	Invert
100.1	100	40	Circular	9.5	0	NA	123.4	F2	123.50
100.2	100	40	Circular	7.5	0	NA	123.4	F2	123.50
100.3	100	40	Circular	6.2	F2	123.50	123.4	C3	122.83
100.4	100-TBC	40	Circular	1.7	C3	122.83	123.4		

Surface Water Network 1									
Pipe Code	Diameter (mm)	Gradient (1:)	Pipe Type	Pipe Length	Number	Upstream Manhole		Downstream Manhole	
						Invert	Cover	Number	Invert
200.1	100	40	Circular	7.5	NA			S1	122.82
200.2	100	40	Circular	6.5	NA			S1	122.82
200.3	100	40	Circular	8.0	S1	122.82	123.4	C3	122.83

Manhole Number	Cover		Connections	Manhole dia. Size	Types	
	Level	Depth To Soffit			Manhole	Cover
S1	123.400	Mxk 0.575		320	1	A15
F2	123.400	Mxk 0.575		320	1	A15
C3	123.400	Mxk 0.575		320	1	A15

Manhole Schedule

P01	12.02.23	P01 Issue	MG	AW
Rev	Date	Detail	Drawn	Chkd
Client: CAPNEZ LTD				
Project: Land adjacent to 12 Rochdale Lane				
Drawing Title: Proposed Drainage Layout				
Suite 9-11, 1st Floor, Old Bank Buildings, Belstone, Shrewsbury, SY1 1HU				
Drawn by: MG		Checked by: MG		Date: Feb 2023
Scale: 1:200				Status:
Drawing No: 1234.02 100				Issue: P01