

NOTES:
1. ALL DIMENSIONS ARE IN MILLIMETRES (mm) AND LEVELS ARE IN METRES (m) UNLESS STATED OTHERWISE.

COLOUR CONVENTIONS
BLACK - EXISTING OR UNCHANGED
BLUE - MODIFIED OR TO BE MOVED
GREEN - REDUNDANT OR TO BE REMOVED
RED - PROPOSED OR ADDITIONAL
PURPLE - WORKS BY OTHERS/FUTURE WORKS

P05	05/12/24	ISSUED FOR REVIEW	MB	SV	VS
P04	16/07/24	ISSUED FOR REVIEW	MB	SV	VS
P03	31/05/24	ISSUED FOR REVIEW	ADI	Chk	App
P02	24/01/24	ISSUED FOR REVIEW	ADI	Chk	App
P01	10/11/23	ISSUED FOR REVIEW	ADI	Chk	App
Rev	Date	Description of Revisions	Drawn	Chkd	Appr

Suitability S0 - WORK IN PROGRESS



Poise Group Ltd
No 5, C - D Bear Lane
London
SE1 0UH

Contractor(s)
IONITY

Ionity GmbH
Moosacher Strasse 84,
D-80809 Munich
Germany


Project
8312 - IONITY
VILLAGE HOTEL
MANCHESTER BURY

Drawing Title
GENERAL TYPICAL DETAILS


Designed	ADITYA	Signed		Date	11/06/24
Drawn	ADITYA	Signed		Date	08/11/23
Checked	S VENKATESHA	Signed		Date	03/12/24
Approved	V K SHAH	Signed		Date	04/12/24

Scale(s)	R.T.D	ELR & Mileage	ELR&Mileage
Alternative Reference	Alternative Reference	Sheet	01 of 01
Drawing Number	8312-POI-DRG-CIV-200016	Revision	P05


ABB CHARGE POST FOUNDATION PLAN
SCALE 1:50

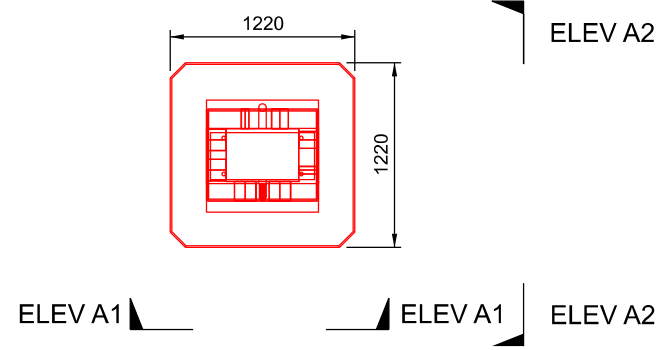


ELEVATION A1
SCALE 1:50

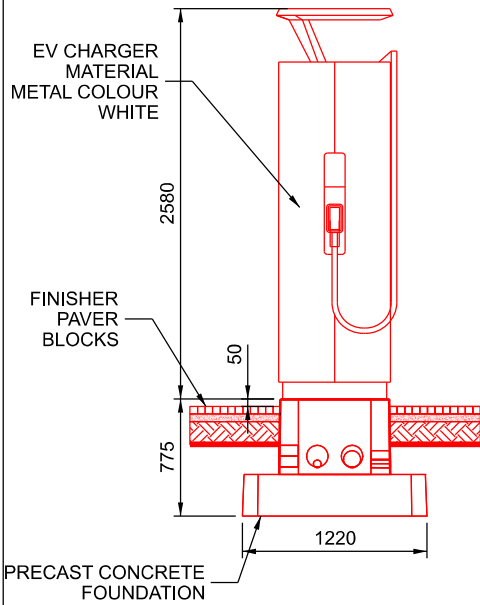


ELEVATION A2
SCALE 1:50

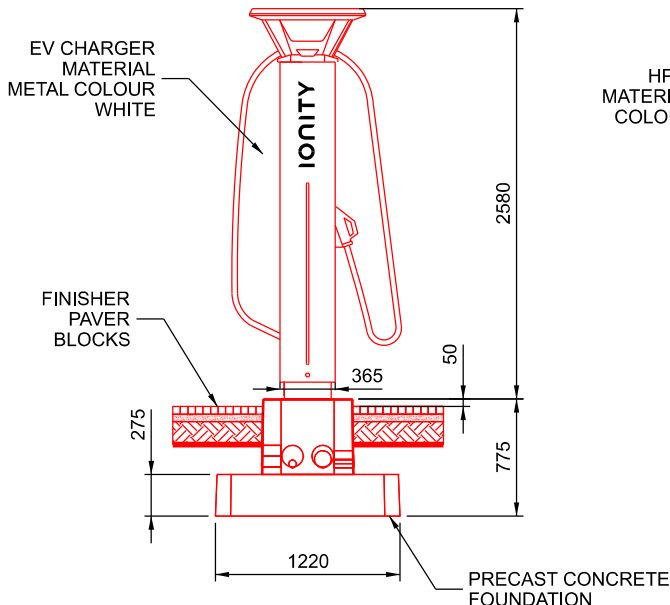


HP CABINET FOUNDATION PLAN
SCALE 1:50

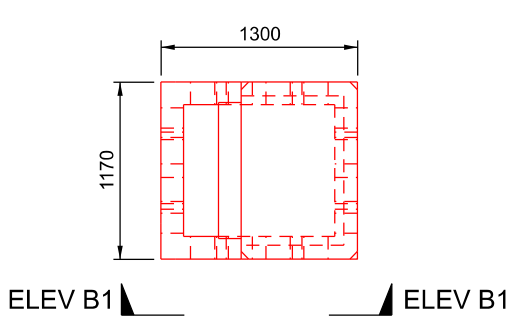


ELEVATION B1
SCALE 1:50

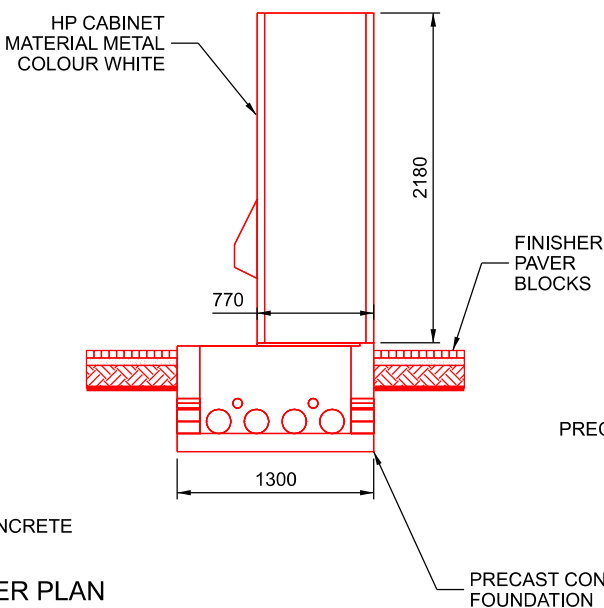


HYC 400 ALPITRONIC CHARGER PLAN
SCALE 1:50

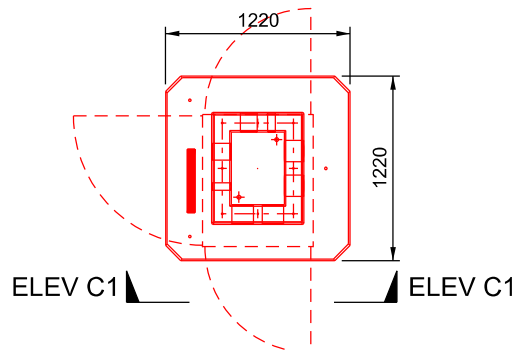


ELEVATION C1
SCALE 1:50

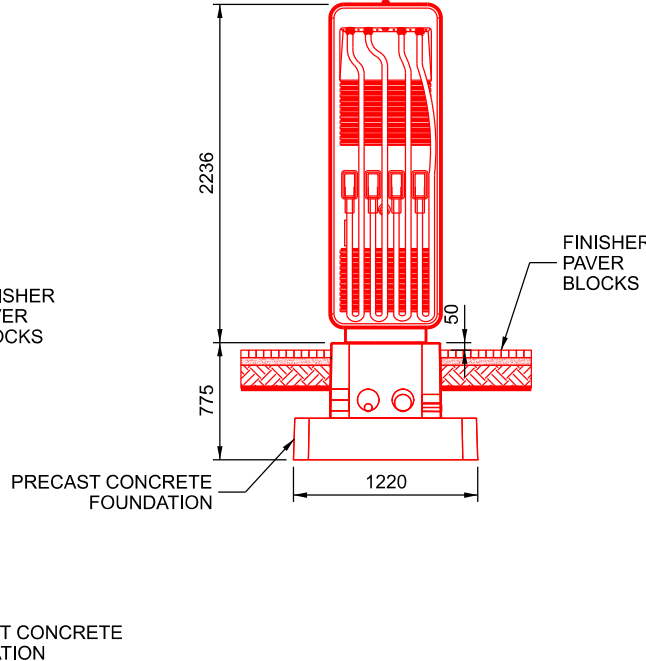


NAL BOLLARD PLAN
SCALE 1:50

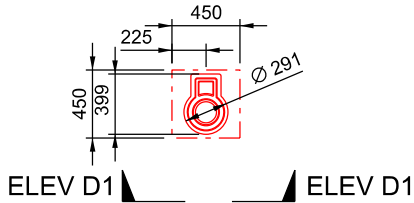


ELEVATION D1
SCALE 1:50

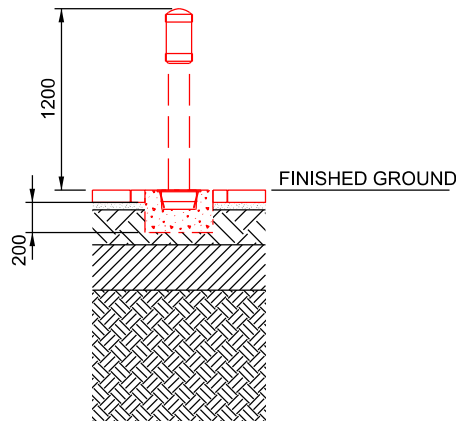

 HYC 50 ALPITRONIC CHARGER PLAN
SCALE 1:50



ELEVATION E1
SCALE 1:50

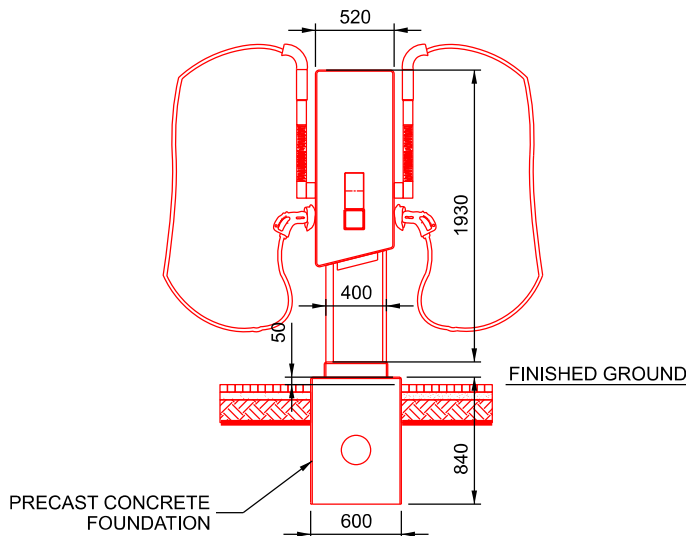

LV PANEL ELEVATION
SCALE 1:50

