



Radiator Schedule									
Reference	Room	Temp	Manufacturer	Product	Type	Height (mm)	Length (mm)	Required input >20% (kW)	Radiator output (kW)
R65	R1.01 Lobby/Stairs	55/45	Jaga	Linea Plus Twin	21	500	1800	2041	2160
R66	R1.03 Lift Lobby	55/45	Jaga	Linea Plus Twin	11	500	500	272	311

VENTILATION & HEATING WALL SECTION

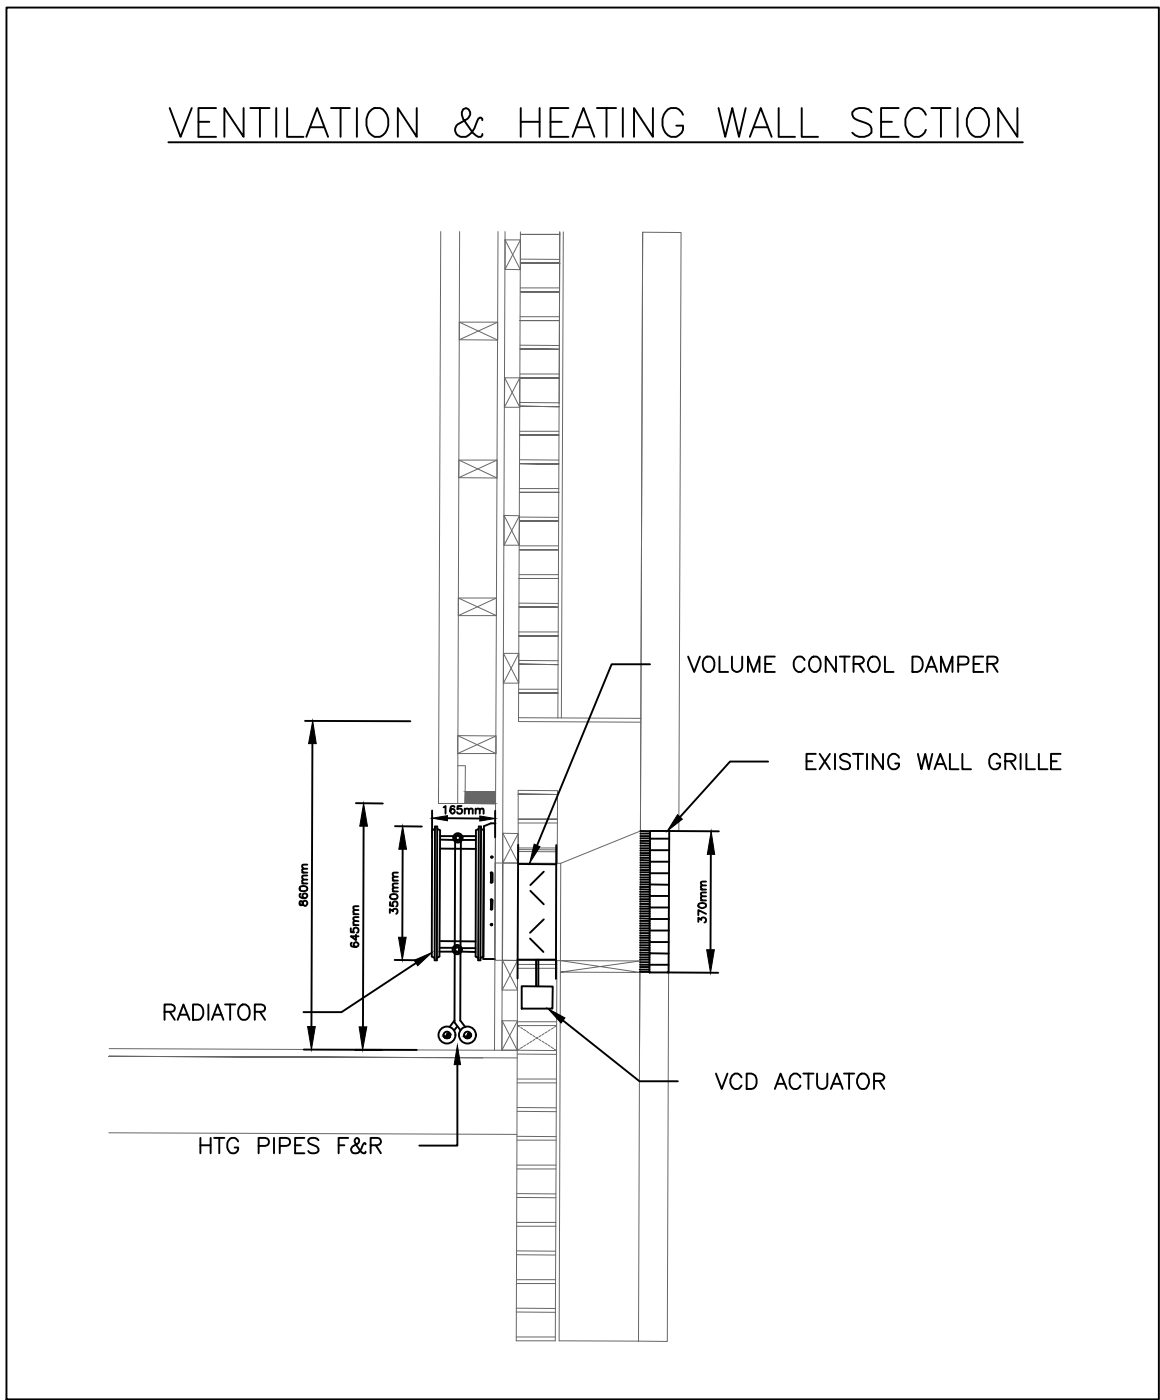

- LEGEND
- HEATING PIPES AT LOW LEVEL
 - HEATING PIPES AT HIGH LEVEL
 - CT HEATING PIPES AT LOW LEVEL
 - CT HEATING PIPES AT HIGH LEVEL
 - EXISTING
 - PIPE RISER (INDICATED ON DRAWING WHETHER TO BELOW OR ABOVE)
 - DIRECTION OF FLOW
 - ISOLATION VALVE
 - TEMPERATURE REGULATING VALVE
 - SINGLE SOCKET FOR LINEA PLUS WITH DBE
 - UNDERFLOOR HEATING ARRAY

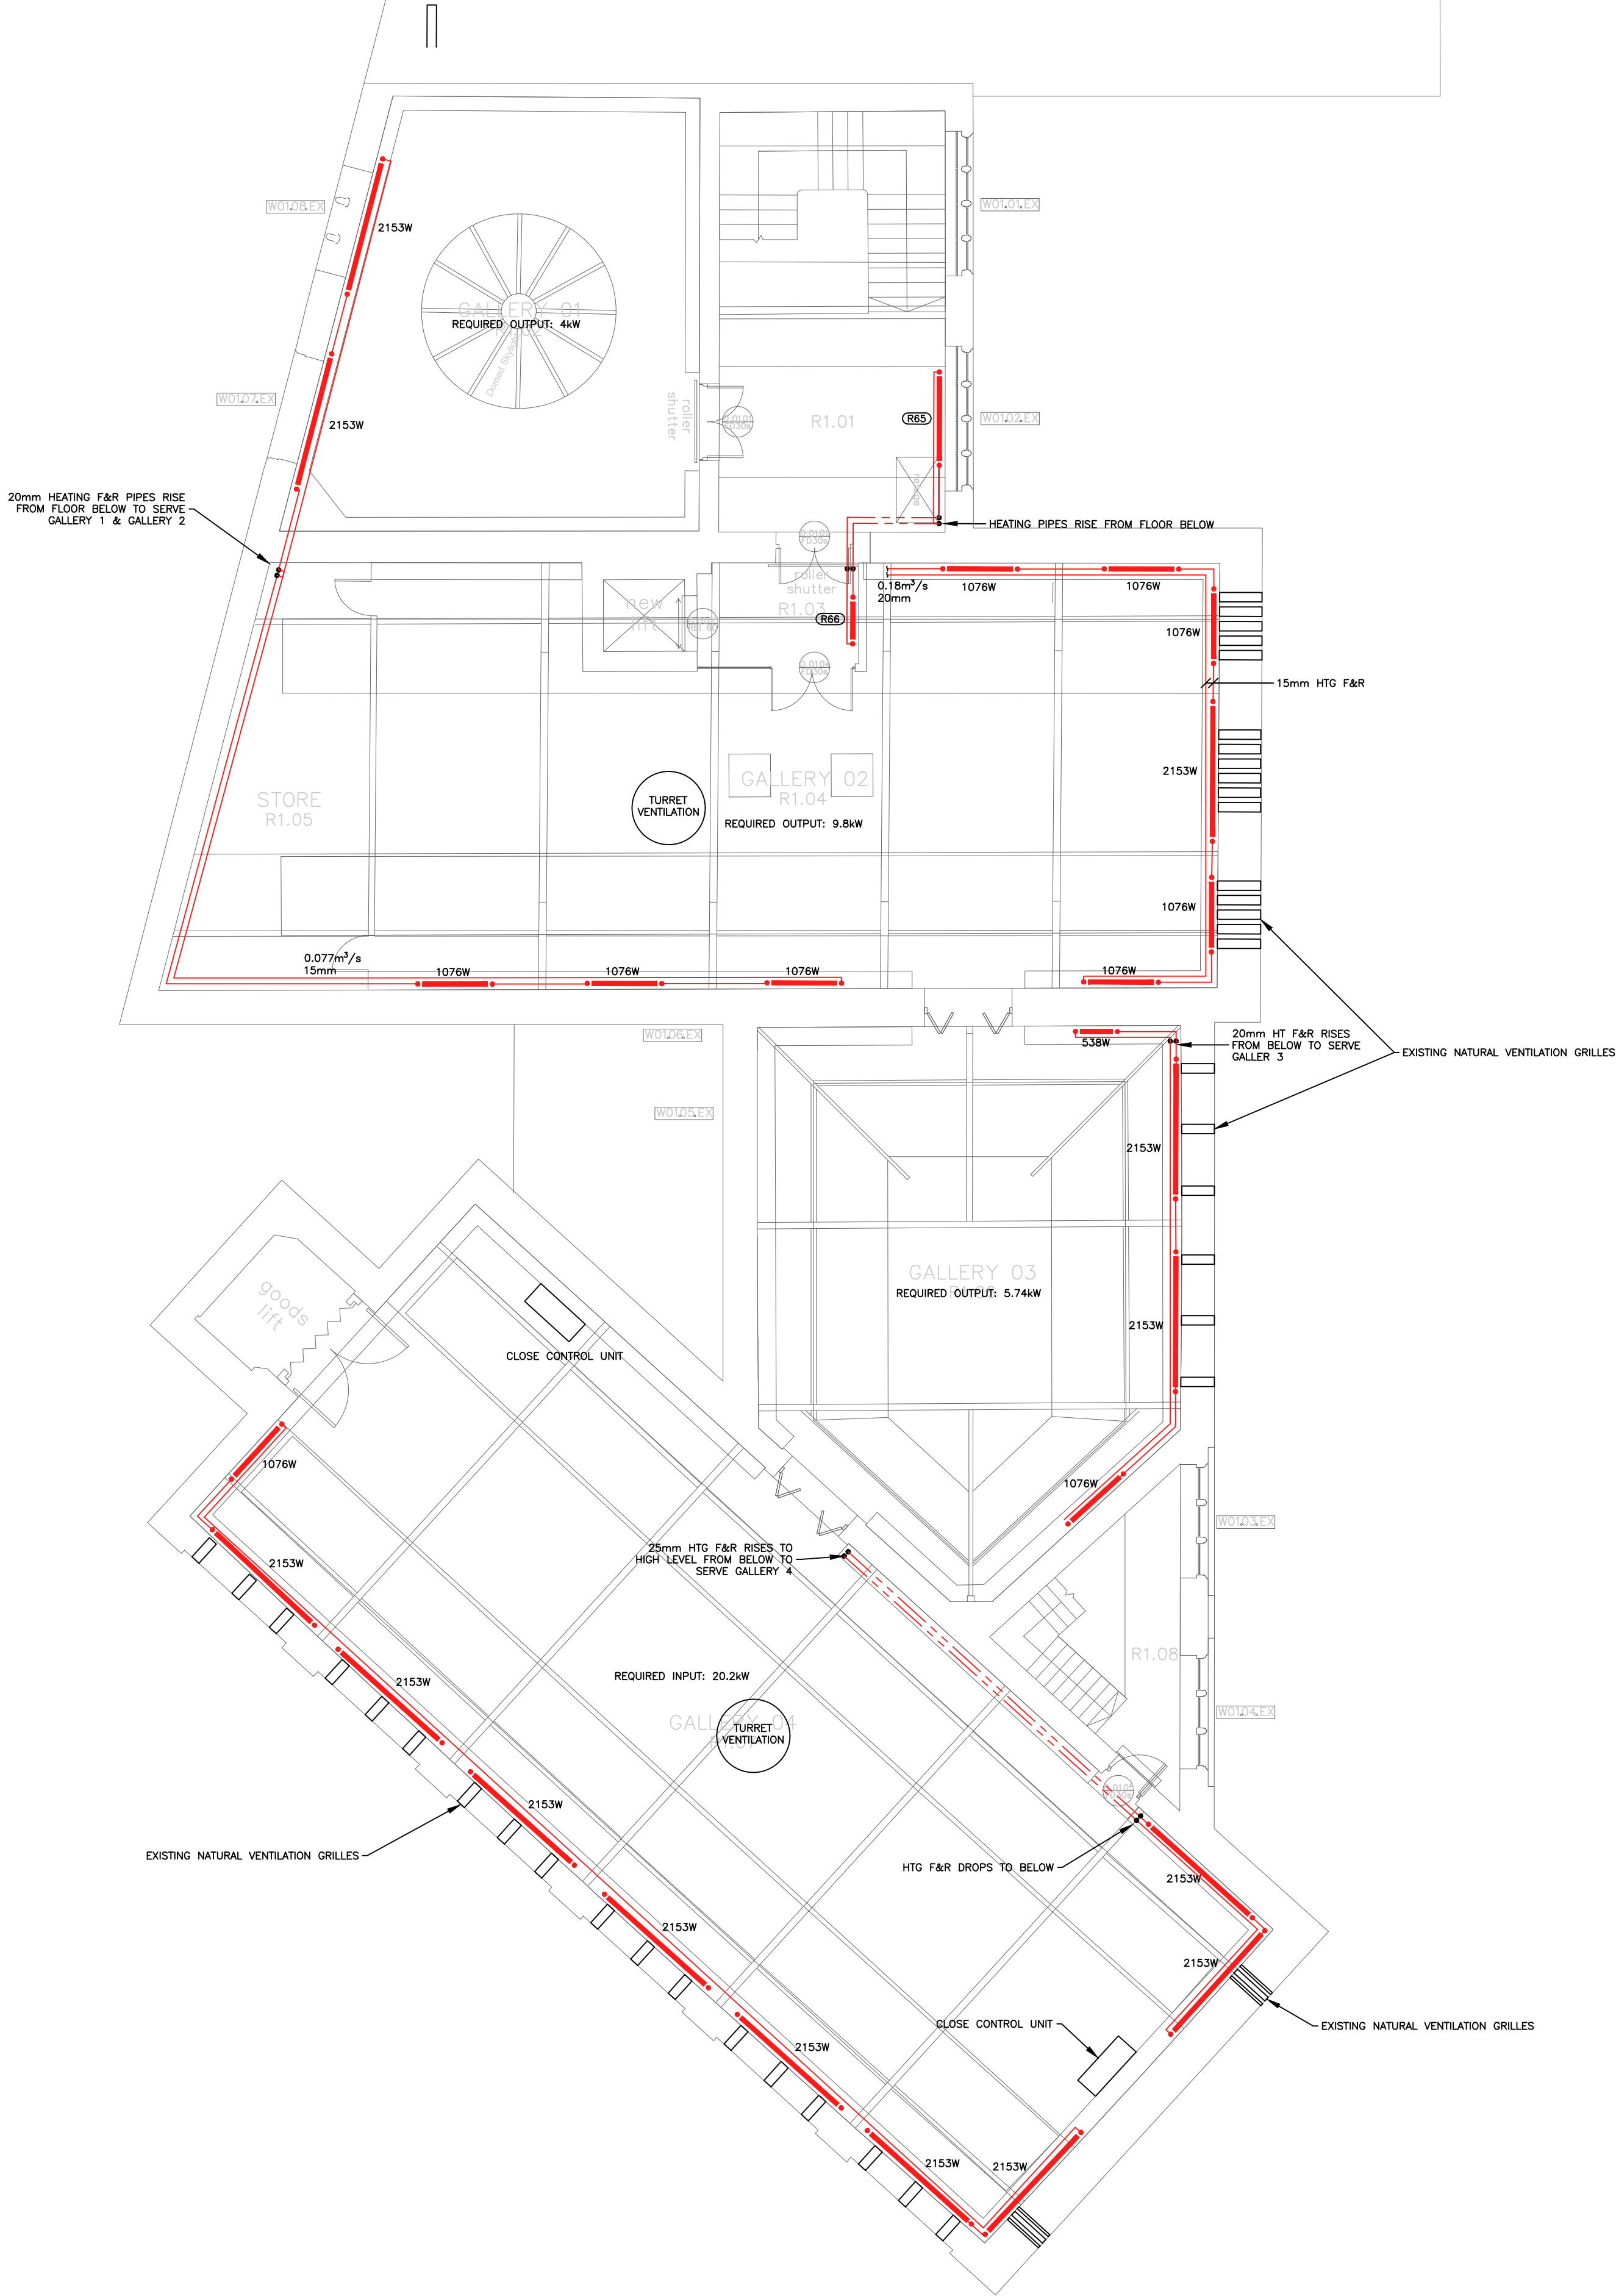

P1	21/11/2023	PRELIMINARY ISSUE			
Revision	Date	Description			
Client & Site					
YOUR TRUST TOUCHSTONES ROCHDALE					
Title					
HEATING LAYOUT					
FIRST FLOOR					
 Steven A. Hunt & Associates Hangar 9, De Havilland Drive, Liverpool L24 8RN T 0151 427 8009 W www.stevenhunt.com E info@stevenhunt.com					
Scale: 1:100		Size: A1	Drawn: EB	Chkd: SH	
Drawing No. ISO19650 Compliant					
Project: 4025 SHA · XX · 01 · DR · M · 1000 · S2 · P1					

PRELIMINARY