
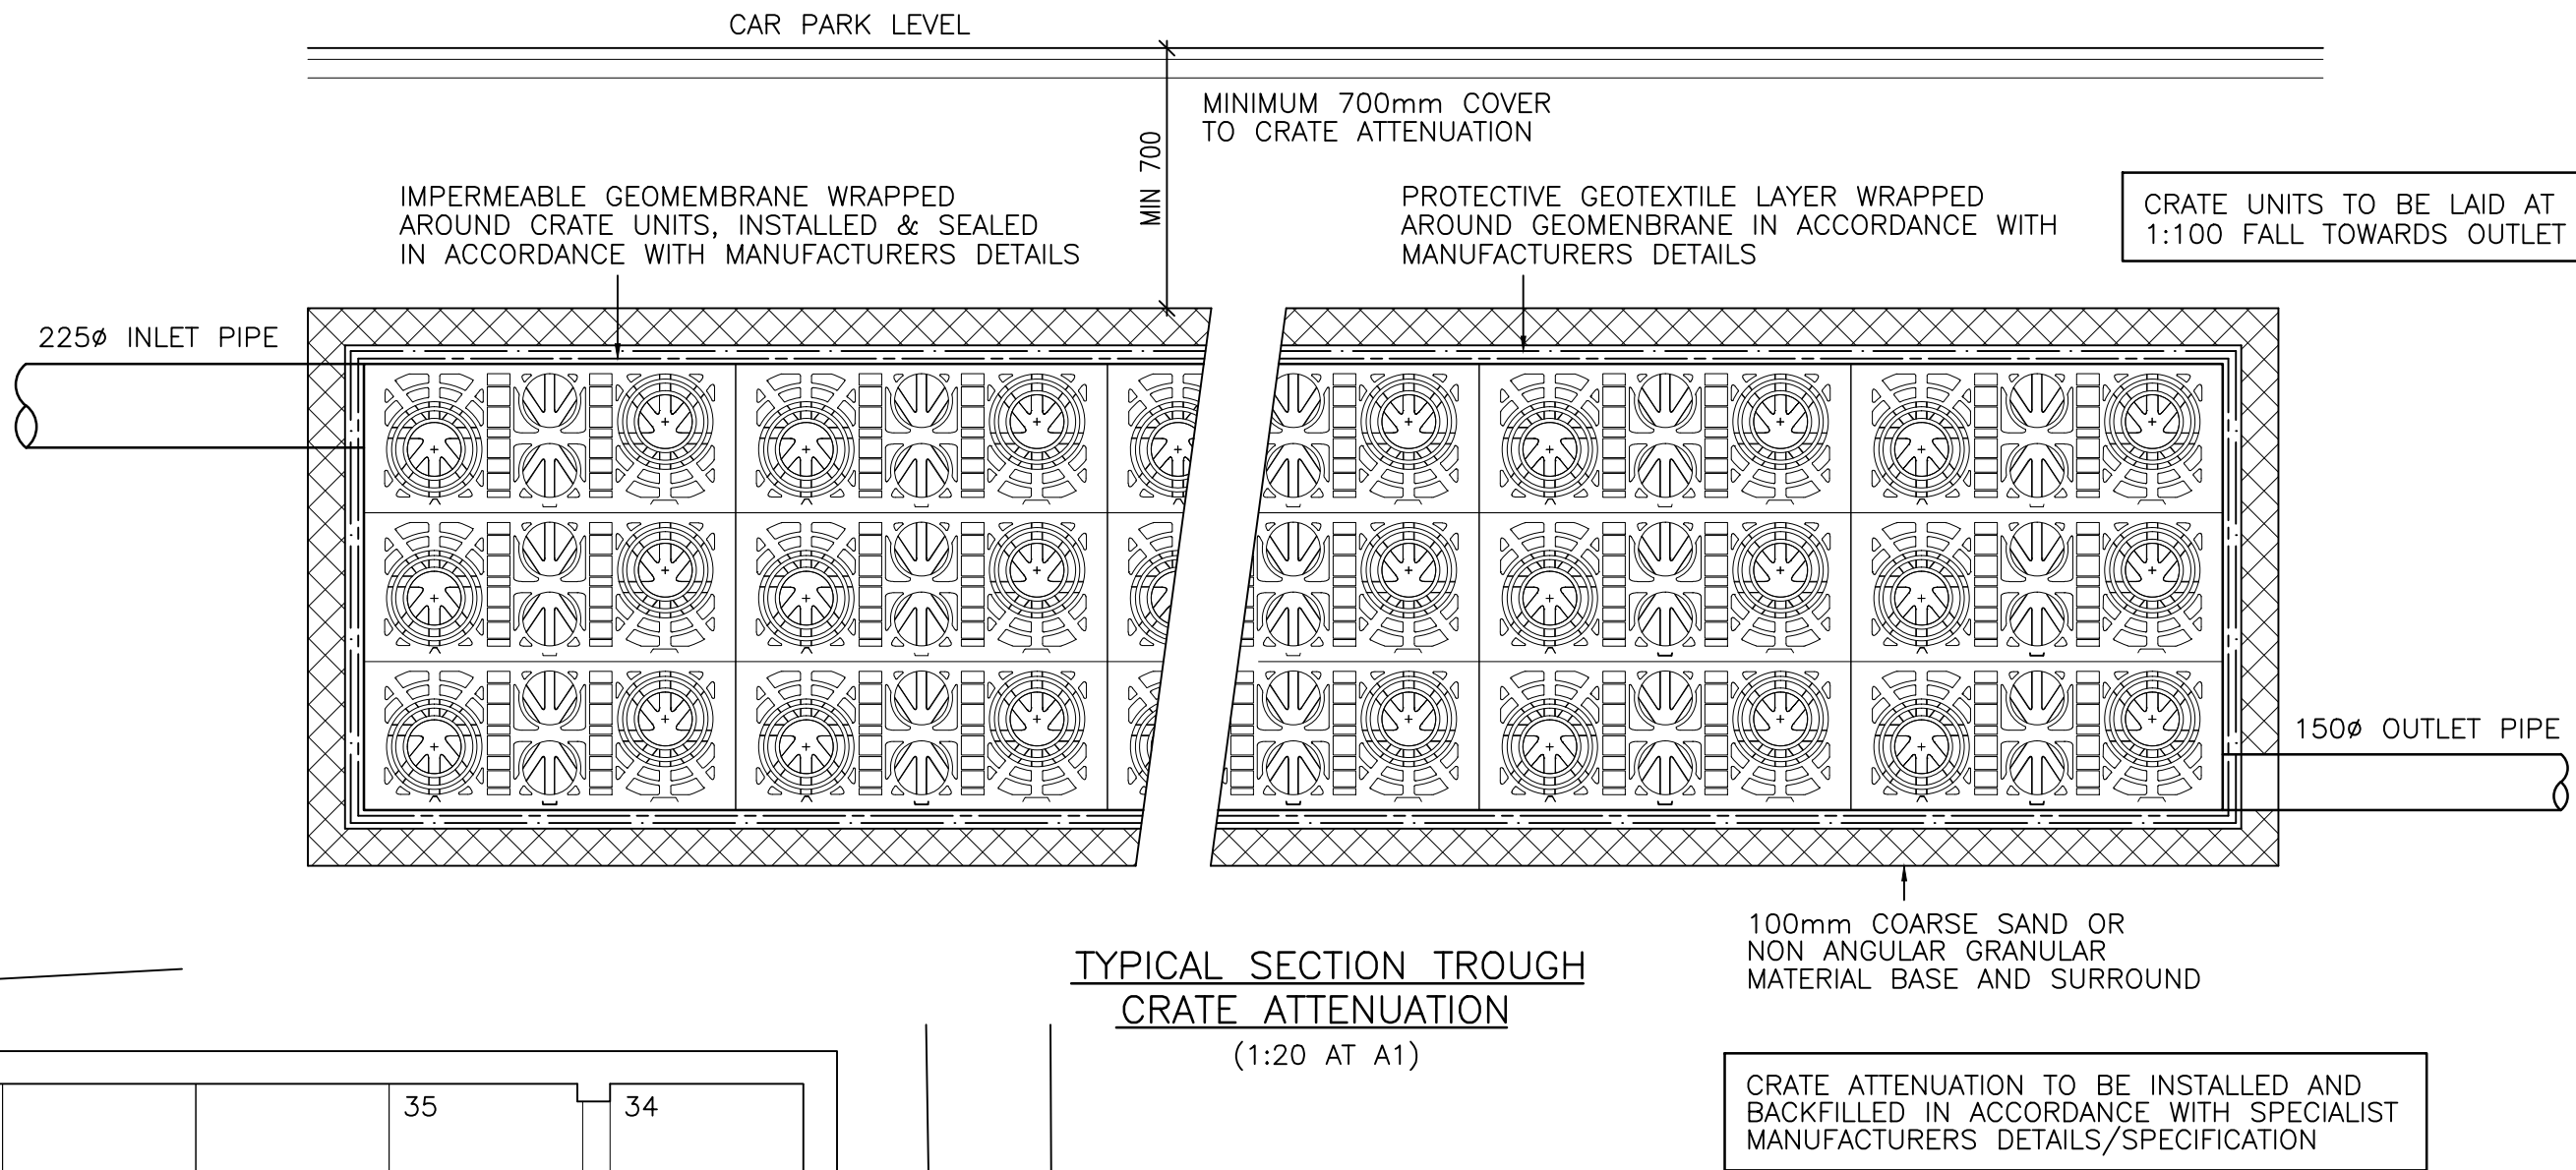


KEY	
• RWP	RAIN WATER PIPE
• SVP	SOIL VENTILATION PIPE
---	SURFACE WATER DRAIN
---	FOUL WATER DRAIN
---	COMBINED WATER DRAIN
---	EXG COMBINED WATER DRAIN

ALL SURFACE & FOUL WATER BRANCH CONNECTIONS TO BE 100mmØ U.N.O	ALL INTERNAL SVP'S TO HAVE RODDING ACCESS POINT
ALL INTERNAL DRAINAGE RUNS ARE DIAGRAMATIC & CAN BE ADJUSTED TO SUIT	ALL EXTERNAL DOORS WITH A LEVEL ACCESS TO HAVE A THRESHOLD DRAIN

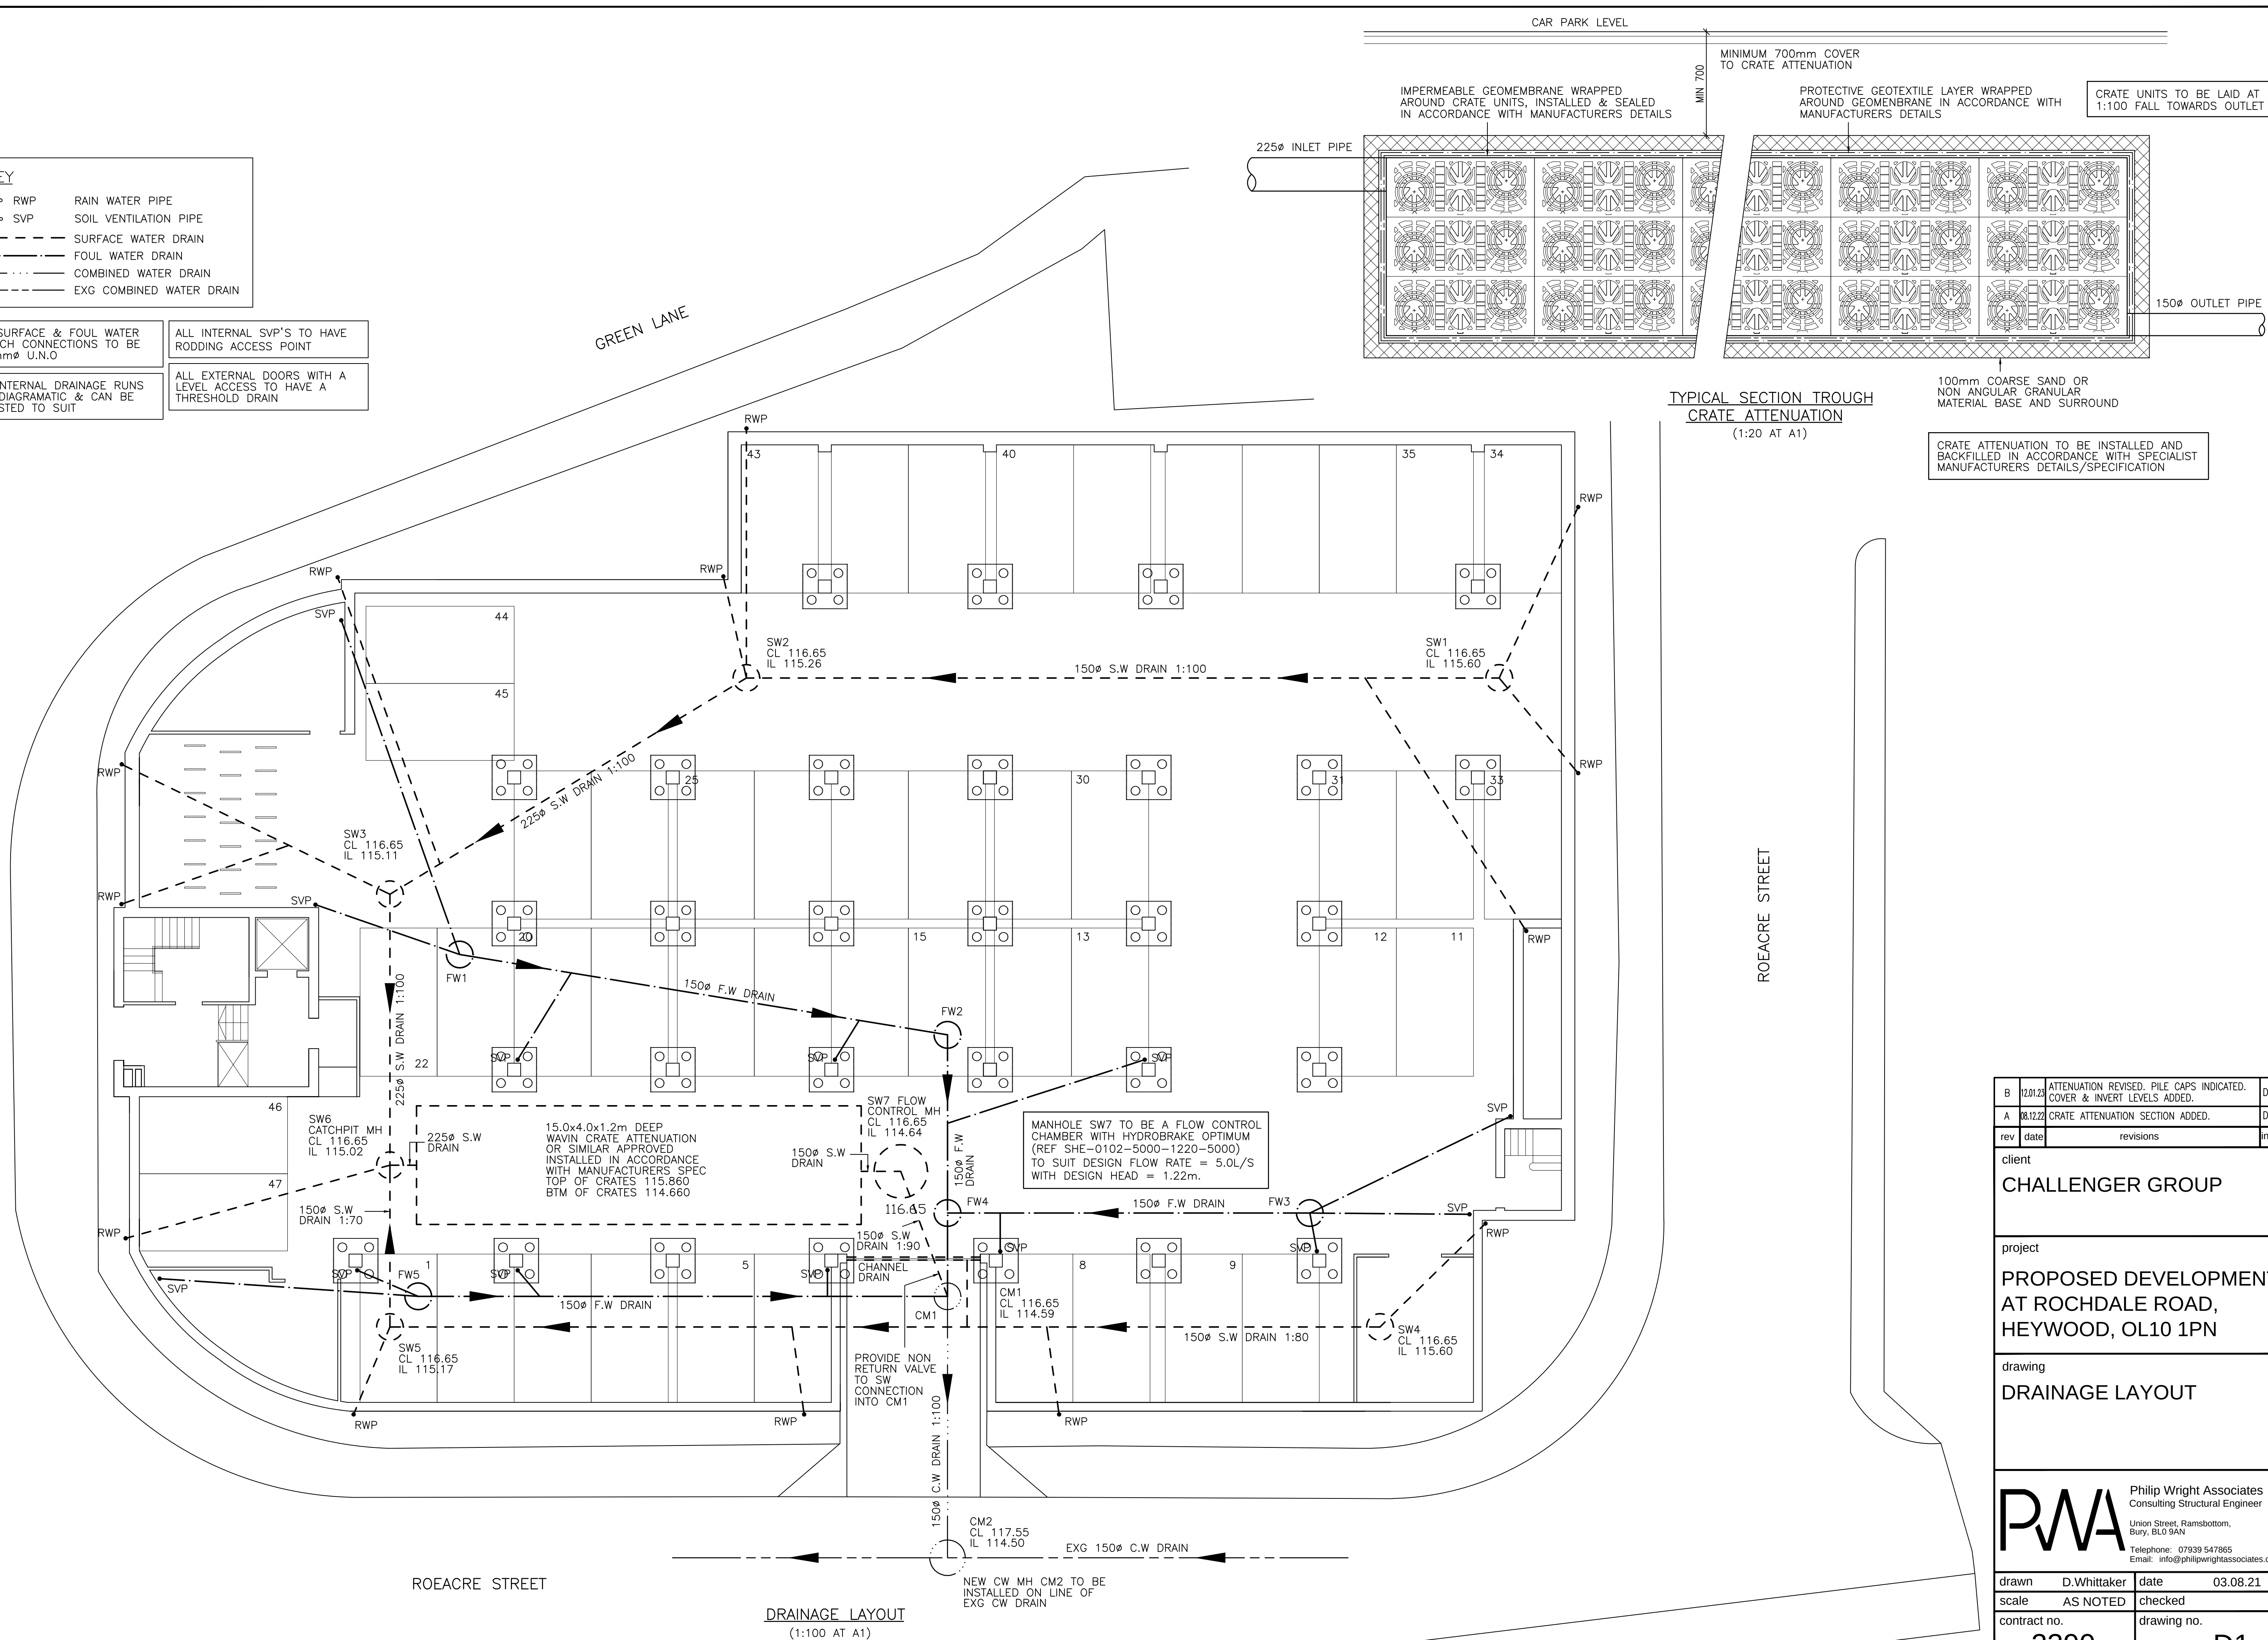

B	12.01.23	ATTENUATION REVISED, PILE CAPS INDICATED, COVER & INVERT LEVELS ADDED.	D.J.W
A	08.12.22	CRATE ATTENUATION SECTION ADDED.	D.J.W
rev	date	revisions	initials

client
CHALLENGER GROUP

project
**PROPOSED DEVELOPMENT
AT ROCHDALE ROAD,
HEYWOOD, OL10 1PN**

drawing
DRAINAGE LAYOUT



Philip Wright Associates
Consulting Structural Engineer
Union Street, Ramsbottom,
Bury, BL0 9AN
Telephone: 07939 547865
Email: info@philipwrightassociates.co.uk

drawn	D.Whittaker	date	03.08.21
scale	AS NOTED	checked	
contract no.	2390	drawing no.	D1 B