


Drainage Plan

Not true to scale
For illustrative purposes only

Drawing to be read in conjunction
with associated report by
Michael Lambert Associates
Consulting Civil Engineers

- R rawwater pipe
 - SVP soil and vent pipe
 - IC 150mm surface water drain and inspection chamber
 - IC 150mm foul drain and inspection chamber
- all drainage to be 100mm diameter unless indicated
all external rawwater pipes to discharge into back inlet gullies

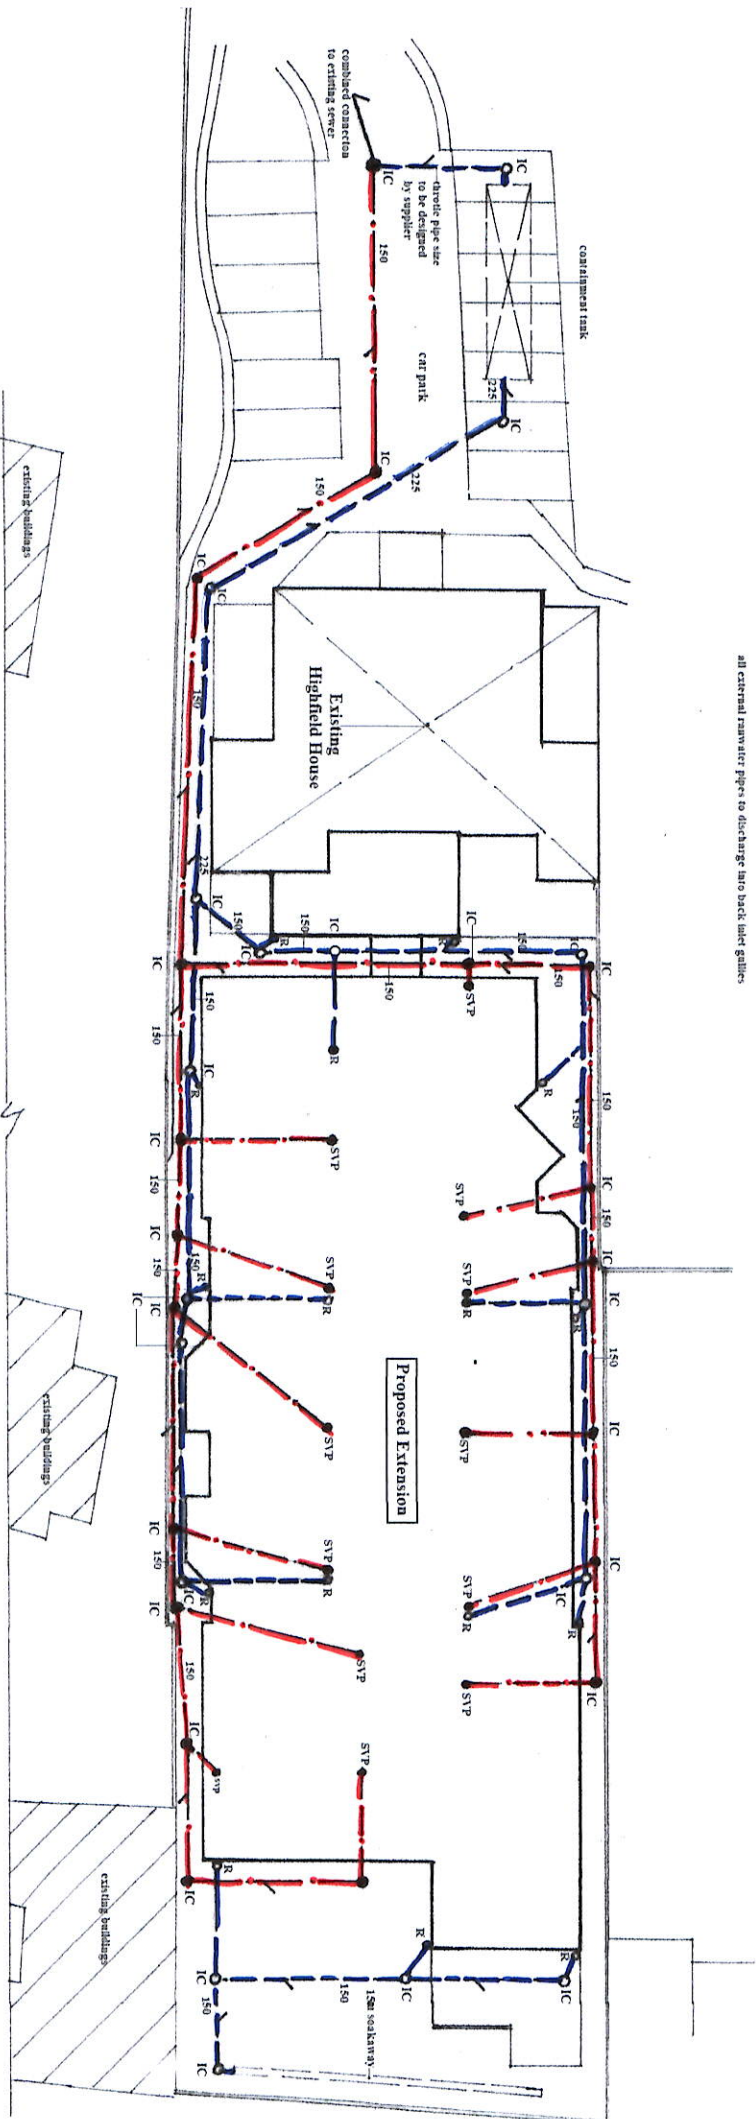

Proposed Rear Extension
Highfield House
Manchester Road
Heywood

Planning Application
Proposed New Drainage Layout

Scale 1:250 @ A3
reference HH02/1022/PL01

P A Dust Chartered Architect
1 Spring Mill
Spring Street
Lancaster
Lancaster LA1 3 6AJ
t-f : 01457 870382
m : 07713 636592
e : tony.dust@btinternet.com