



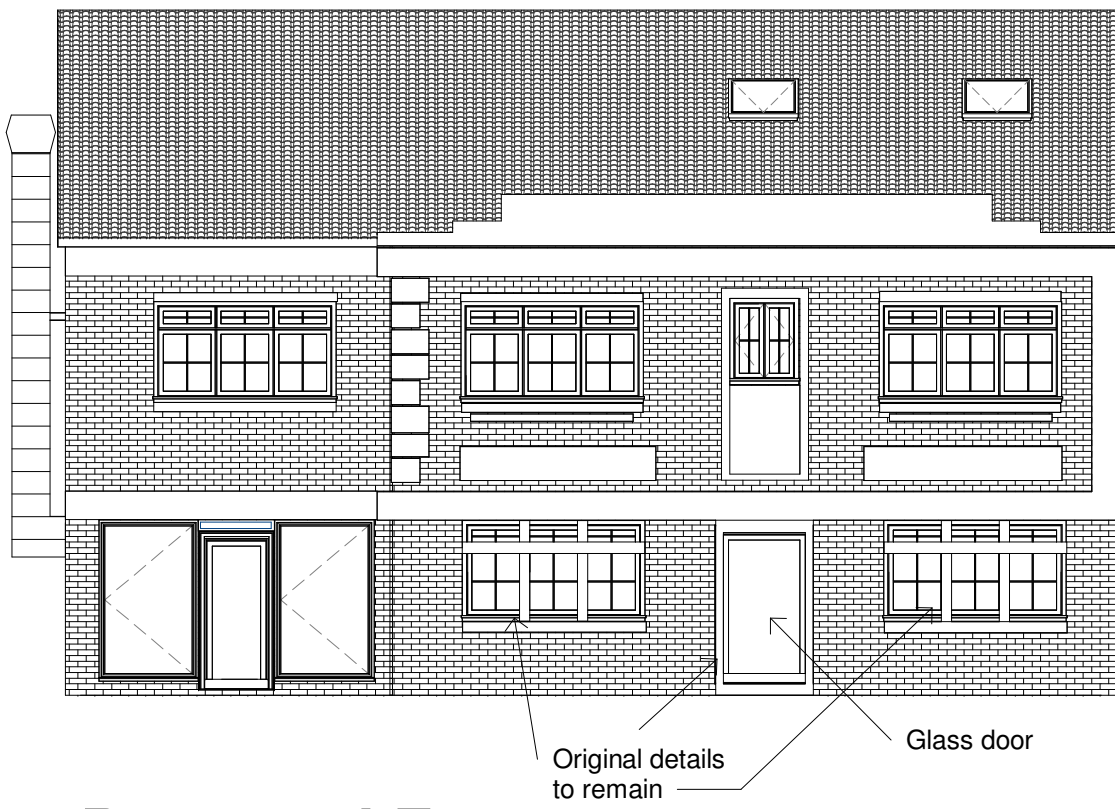

Proposed Front
1 : 100



Proposed Rear
1 : 100

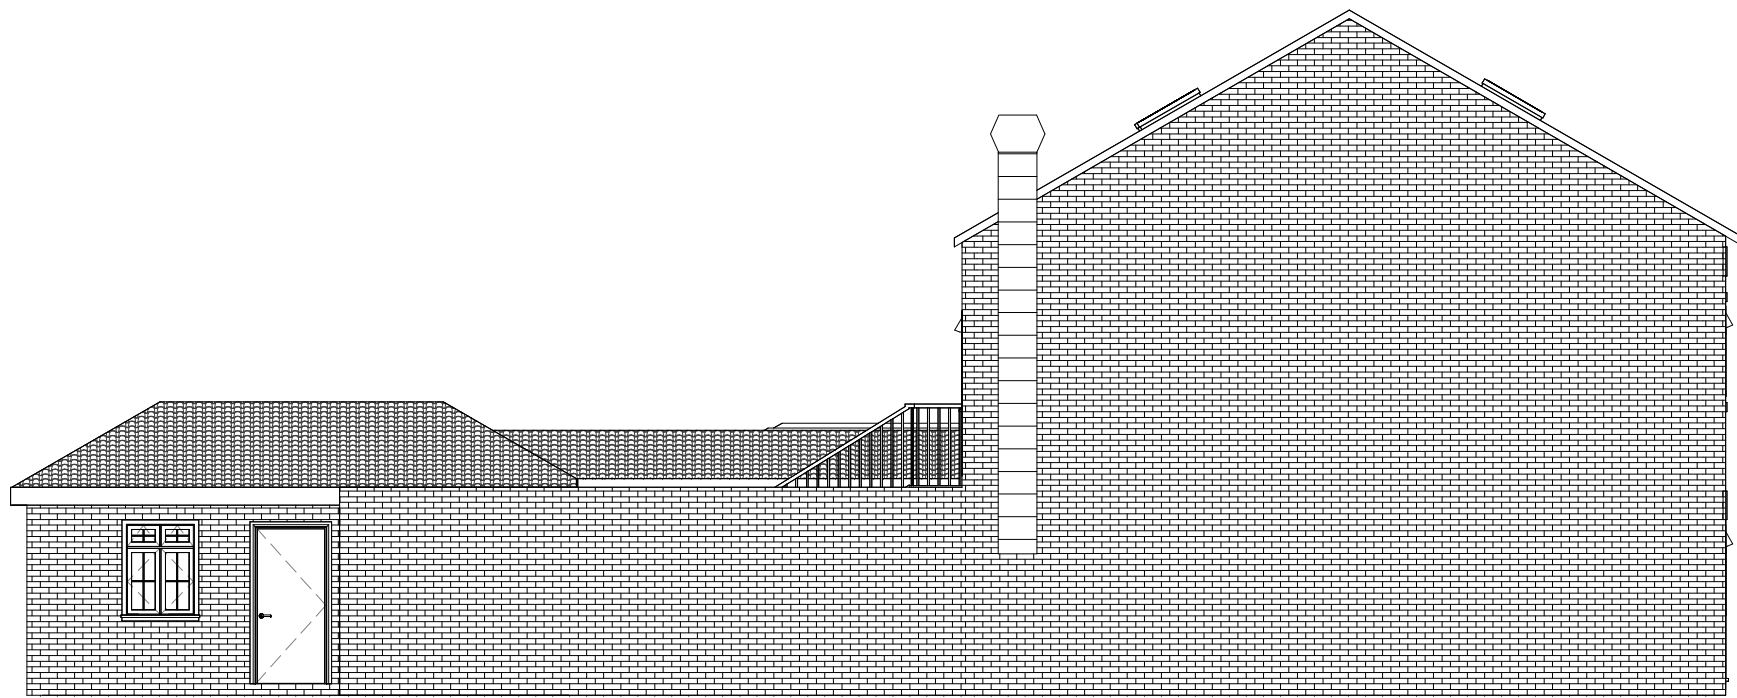


Proposed Side
1 : 100

Scale: @ A1.
Do NOT scale from this drawing.
If in doubt, ask.
Dimensions must be checked by contractor before work is commenced.


This drawing remains the property of Belal Rashid Technical Architecture and should not be reproduced in full or in part without prior consent from Belal Rashid Technical Architecture.

The drawings have been produced for Planning Approval purpose ONLY, and should not be used for any other use.


- 1. Sink to be fitted with grease trap.
- 2. Canopy: Removable baffle grease filters to be used.
- 3. 500mm x 500mm ducting, with axial fan.
- 4. Flakt wood extractor fan x 2 fitted with slincer x 2.
- 5. Carbon box filter, 0.3 to 0.4 second resistance time.
- 6. Gas pipework size to be determined by a Gas Safe engineer.
- Gas supply to be fitted with an interlock system.
- 7. Heat and smoke detectors interlinked.
- 8. Vibration mounts inside and out.

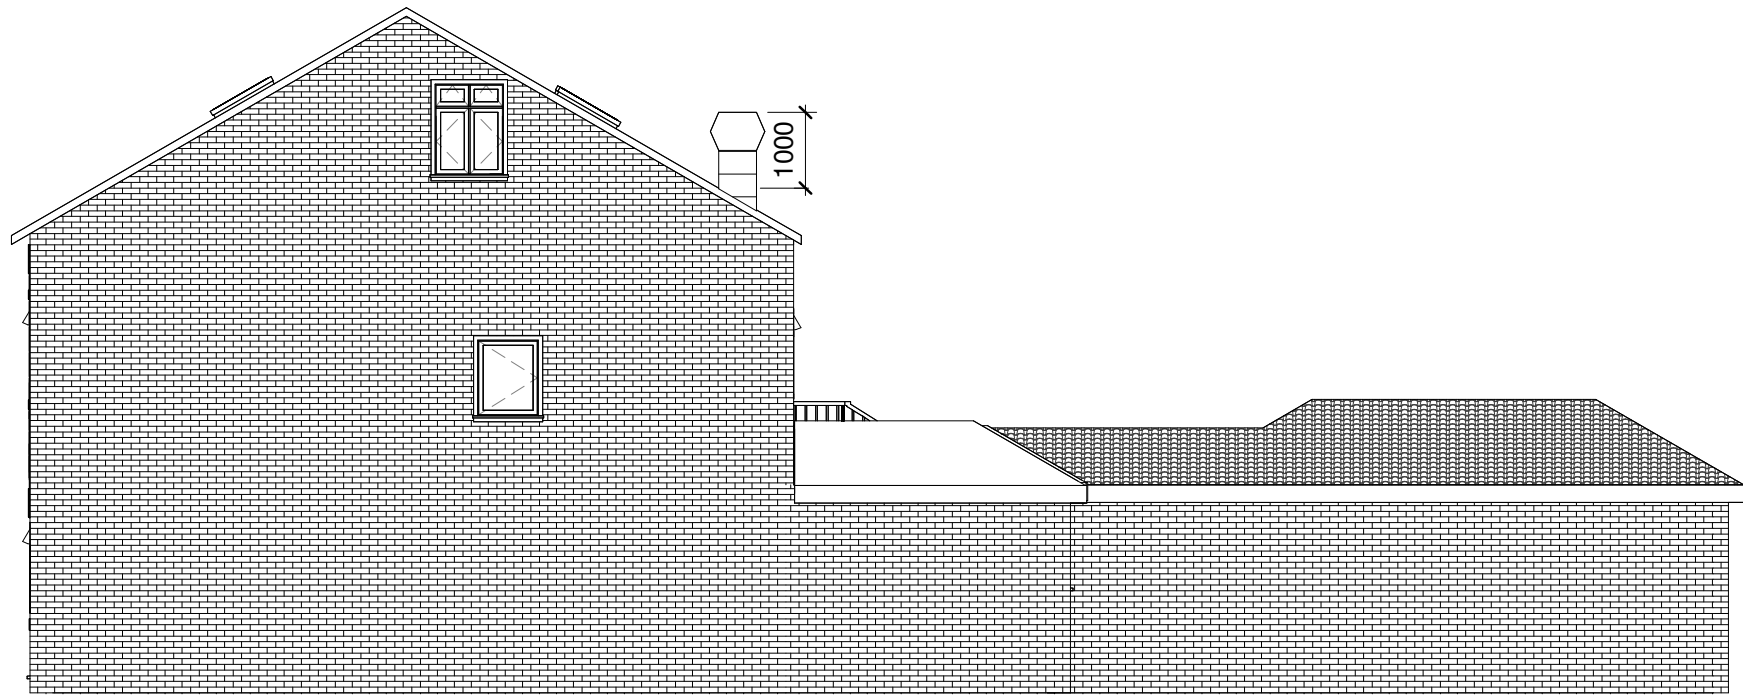

Proposed Side 2
1 : 100

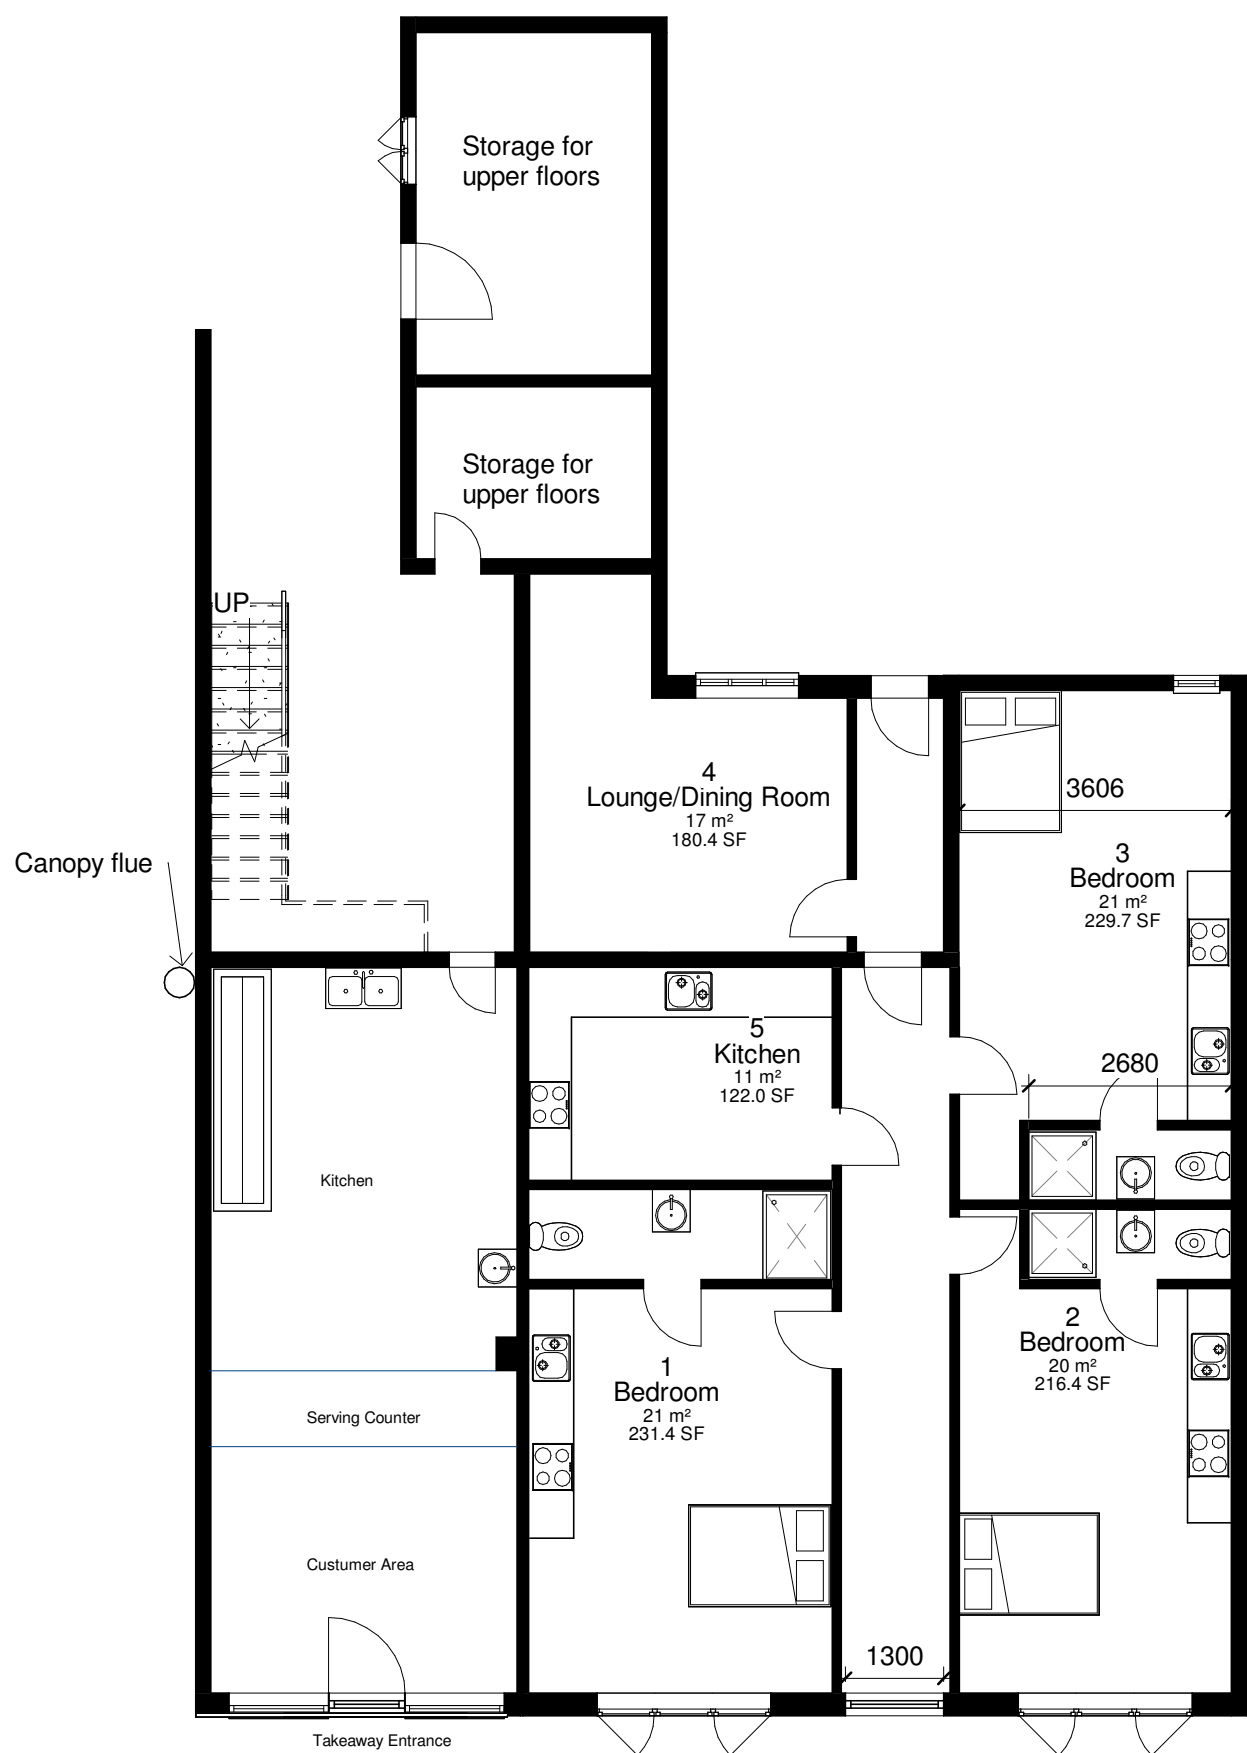

Proposed Ground Floor
1 : 100

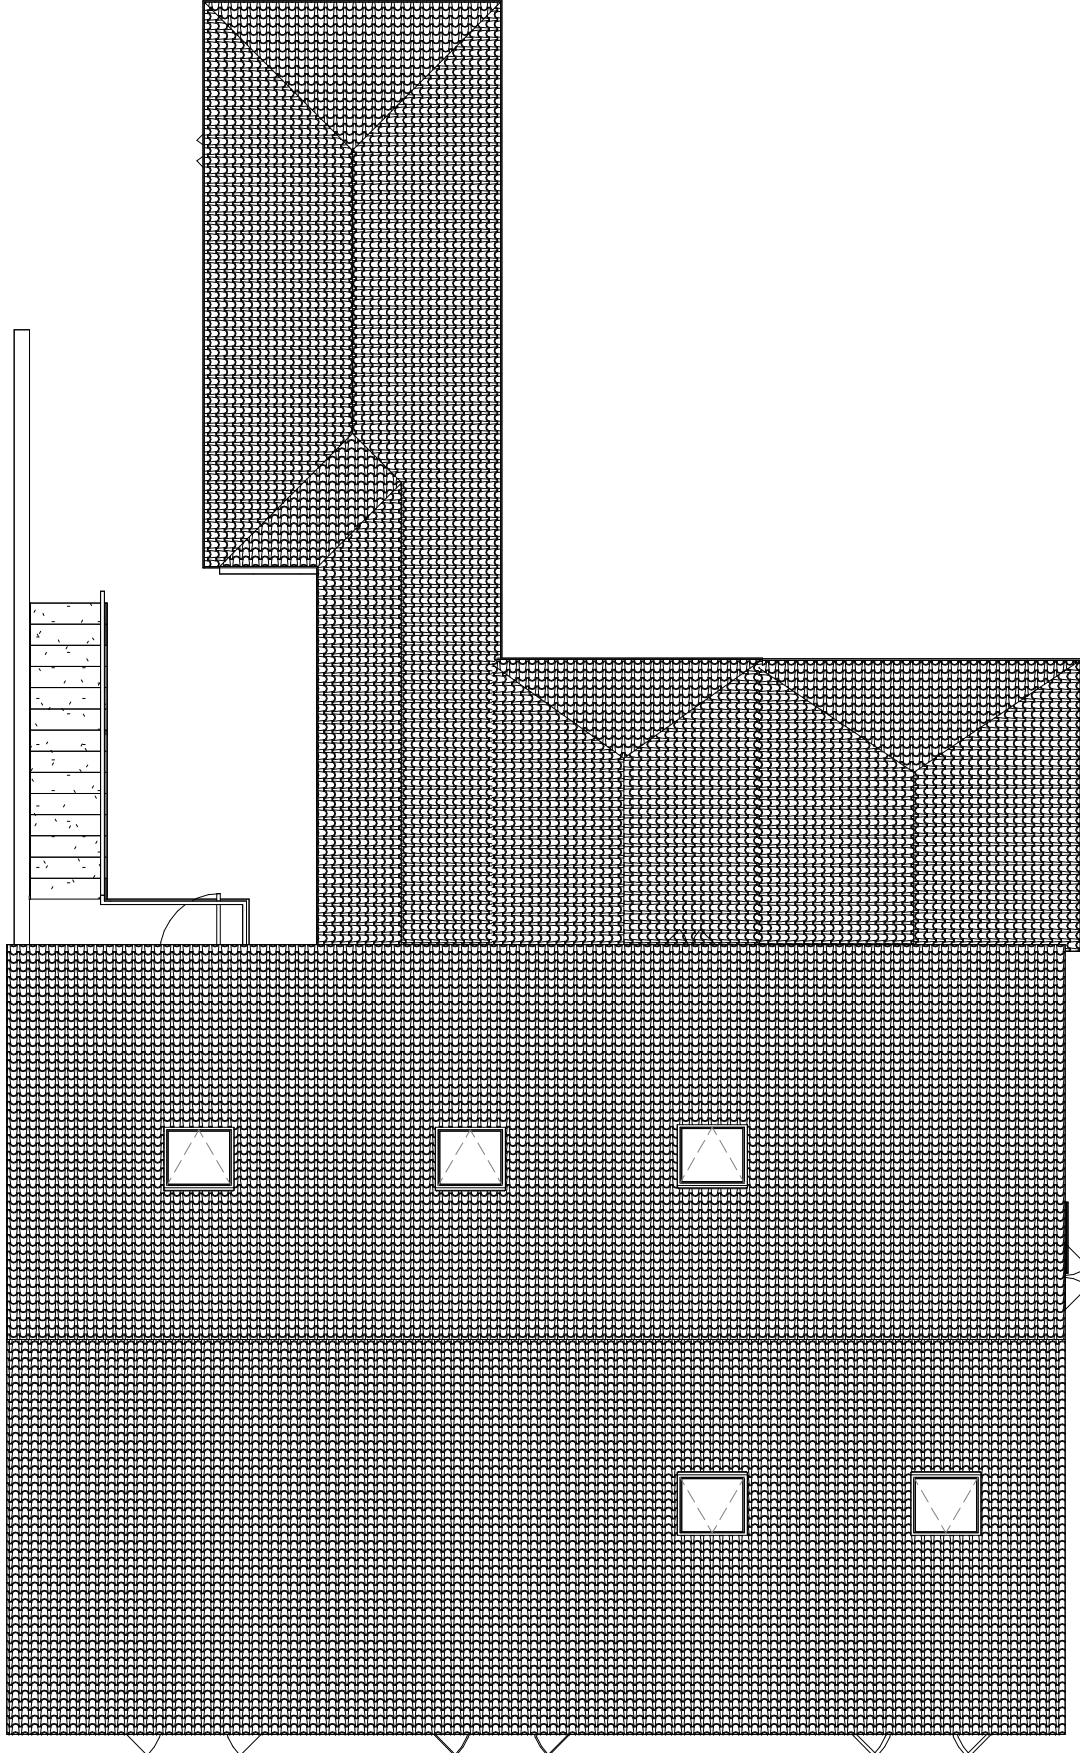

Proposed Roof Plan
1 : 100

Client:
Nawab Khan

Project:
Change of Use
Project Address:
69/71 Halifax Road
Rochdale
OL12 9BA

Drawing Name: Proposed
Drawing Number: A102
Drawing Date: 10/10/23
Author: B.Rashid

Belal Rashid Technical Architecture
Office 12 Falcon Business Centre
Victoria Street
Oldham
Greater Manchester
OL9 0HB

Email: belal.rashid@brta.co.uk
Mobile: 07794529361
Tel: 0161 241 9650

