



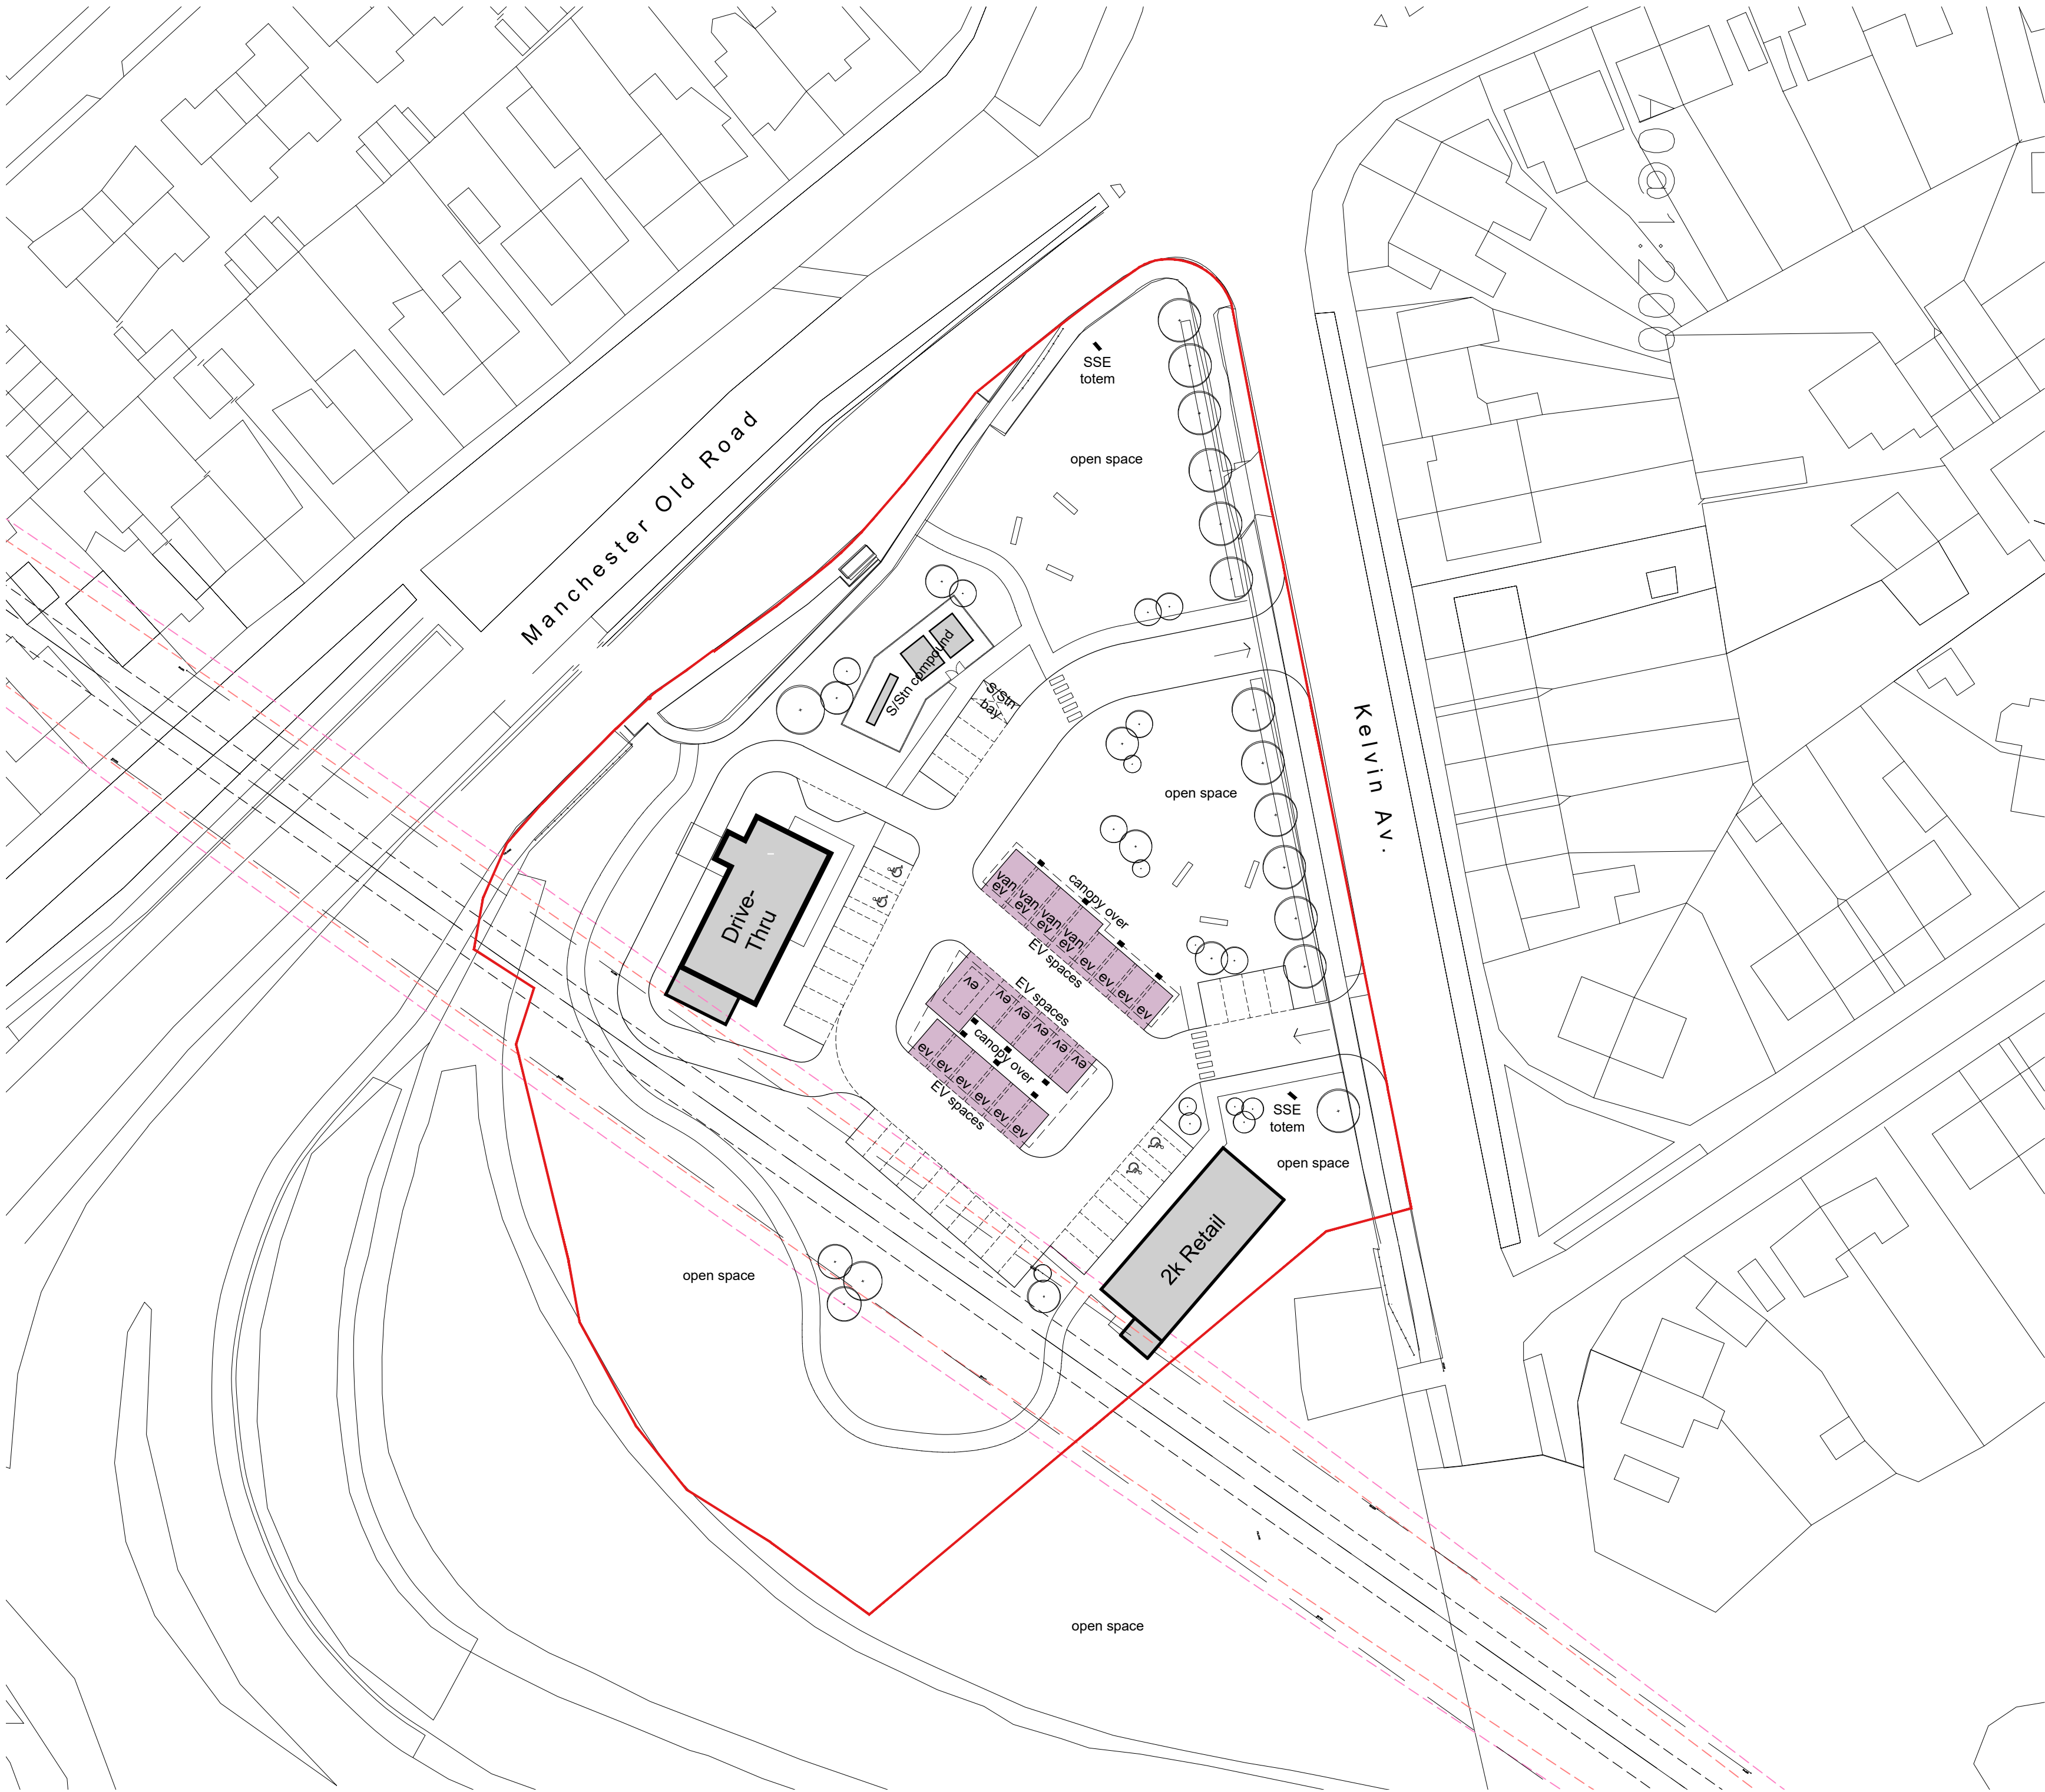

Legend

SSE EV Bays

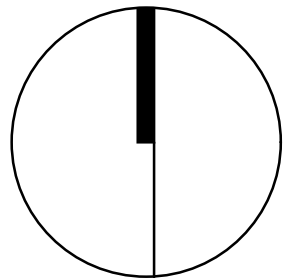

HALLIDAY FRASER MUNRO
CHARTERED ARCHITECTS & PLANNING CONSULTANTS

Project:
Electric Vehicle Charging Hub
Kelvin Avenue

Project No:
12549

Client:
SSE Distributed Energy

Title:
Proposed Site Plan
Screening Request Plan

Document Reference

Identification / Location					Drawing Number		
Project Code	Originator Code	Volume	Location / Level	Type	Role	Classification Number	
SSEKE-	HFM	- ZZ	- ZZ	- SK	- A	- 01	016

Drawing Status:
Information

Revision

Scale:
1:500 @ A2

Date:
January 2024

Do not scale this drawing.
Ordnance Survey material is reproduced with the permission of the controller of her Majesty's Stationery Office Crown Copyright reserved.
The copyright of this drawing subsists in Halliday Fraser Munro Ltd.

Registered Office:
8 Victoria Street,
Aberdeen, AB10 1XB

T: 01224 388 700
E: info@hfm.co.uk
W: hfm.co.uk