


SITE LOCATION


 


Reproduced by permission of Ordnance Survey on behalf of the Controller of Her Majesty's Stationery Office
All rights reserved. © Crown Copyright licence no. 100062043

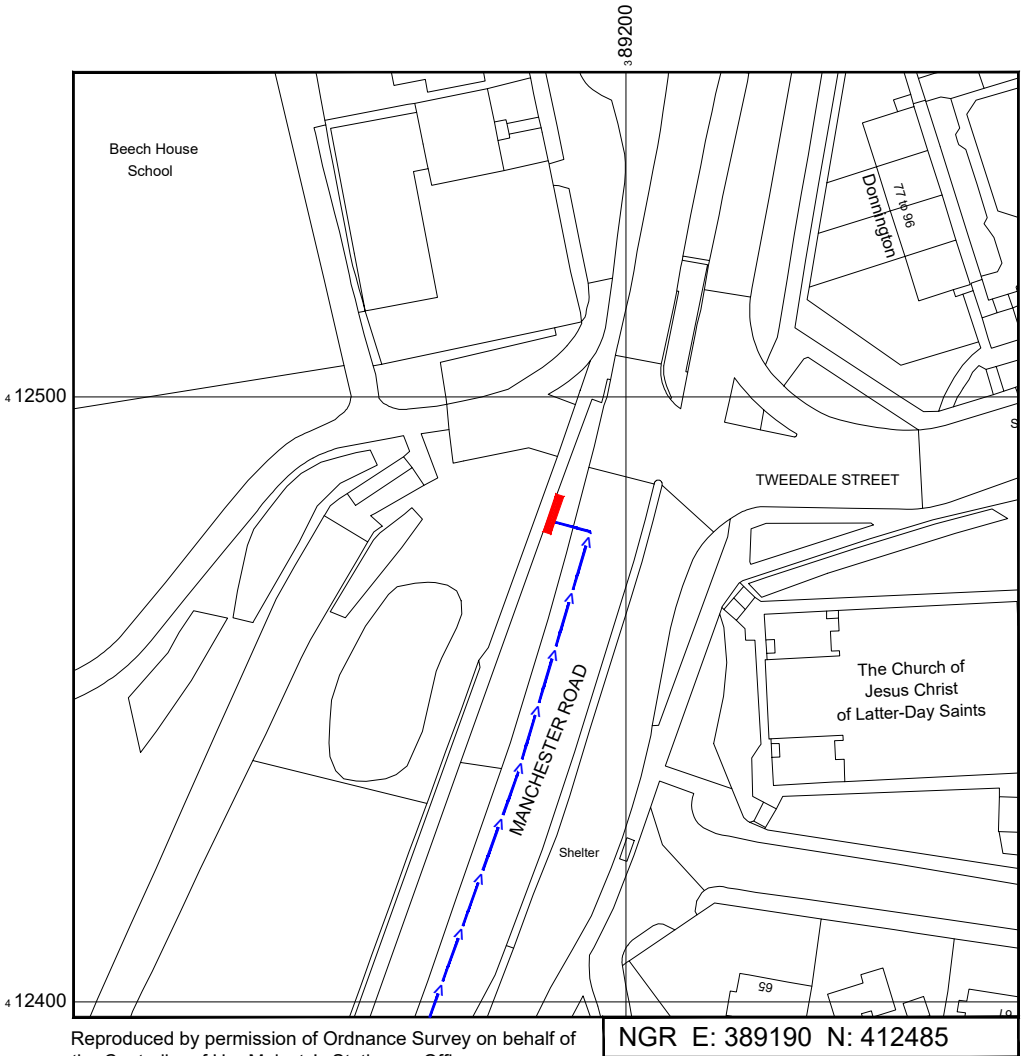


Reproduced by permission of Ordnance Survey on behalf of the Controller of Her Majesty's Stationery Office
All rights reserved. © Crown Copyright licence no. 100062043

SITE AREA PLAN

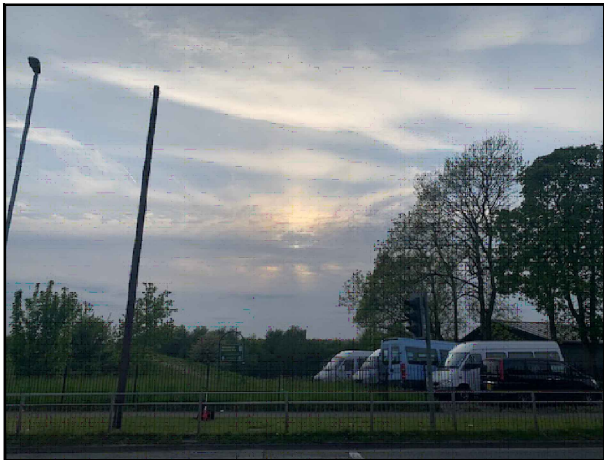

SITE PHOTOGRAPH

 SITE LOCATION PLAN



GOOGLE MAPS QR CODE

GOOGLE MAPS - <https://goo.gl/maps/z7BumEzbEoeZLNFR6>

GOOGLE STREETVIEW - <https://goo.gl/maps/M5egYHHk4a4J3GVc7>

NOTES:

1. ALL DIMENSIONS IN MM UNLESS OTHERWISE NOTED.
- DIRECTIONS TO SITE:
Head north on A627(M). Take the A664 exit towards Rochdale/A58. Merge onto Edinburgh Way/Rochdale Bypass. Turn right onto Manchester Rd/A58. Follow Manchester Road and site location is on the left hand side.



Master:	MBNL / EE:	Project:	Purpose of Issue:	Issue:
M004	MBNL	3UK DNSW	Planning	D
Date:	03/07/2023	Revision / Upgrade Description:		
Drawn:	CDN	Pole type changed to Phase 9		
Checked:	DH			
Approved:	SD			
Master:	MBNL / EE:	Project:	Purpose of Issue:	Issue:
M003	MBNL	3UK DNSW	Planning	C
Date:	22/05/2023	Revision / Upgrade Description:		
Drawn:	CDN	Pole location amended		
Checked:	DH			
Approved:	SD			
Master:	MBNL / EE:	Project:	Purpose of Issue:	Issue:
M002	MBNL	3UK DNSW	Planning	B
Date:	09/03/2022	Revision / Upgrade Description:		
Drawn:	CDN	Pole type changed to Phase 9		
Checked:	DH			
Approved:	SD			
Master:	MBNL / EE:	Project:	Purpose of Issue:	Issue:
M001	MBNL	3UK DNSW	Planning	A
Date:	24/05/2021	Revision / Upgrade Description:		
Drawn:	CDN	First Issue - Site nomination dated: TBC		
Checked:	DH			
Approved:	SD			

CK Hutchison Networks (UK) Limited

Green Park
450 Longwater Avenue
Reading
RG30 3UR

Design Consultant & Principal Contractor:



WHP Telecoms
Unit 1 Maple Park,
Low Fields Avenue, Leeds
LS12 6HH

Tel: 01133023550
e-mail: info@whptelecoms.com

Site Name:
MANCHESTER ROAD STREETWORKS

Site ID:
ROD18035

Address:
MANCHESTER ROAD,
SUDDEN,
CASTLETON,
ROCHDALE,
OL11 4LL


Title:
002 SITE LOCATION PLAN

Project:
3UK DNSW

Purpose of Issue:
GENERAL ARRANGEMENT

EE Cell ID: 83964	MBNL Cell ID: ROD167	Cell ID: OL0348
----------------------	-------------------------	--------------------

Master Drawing No: ROD18035_M004	Issue: D
-------------------------------------	-------------

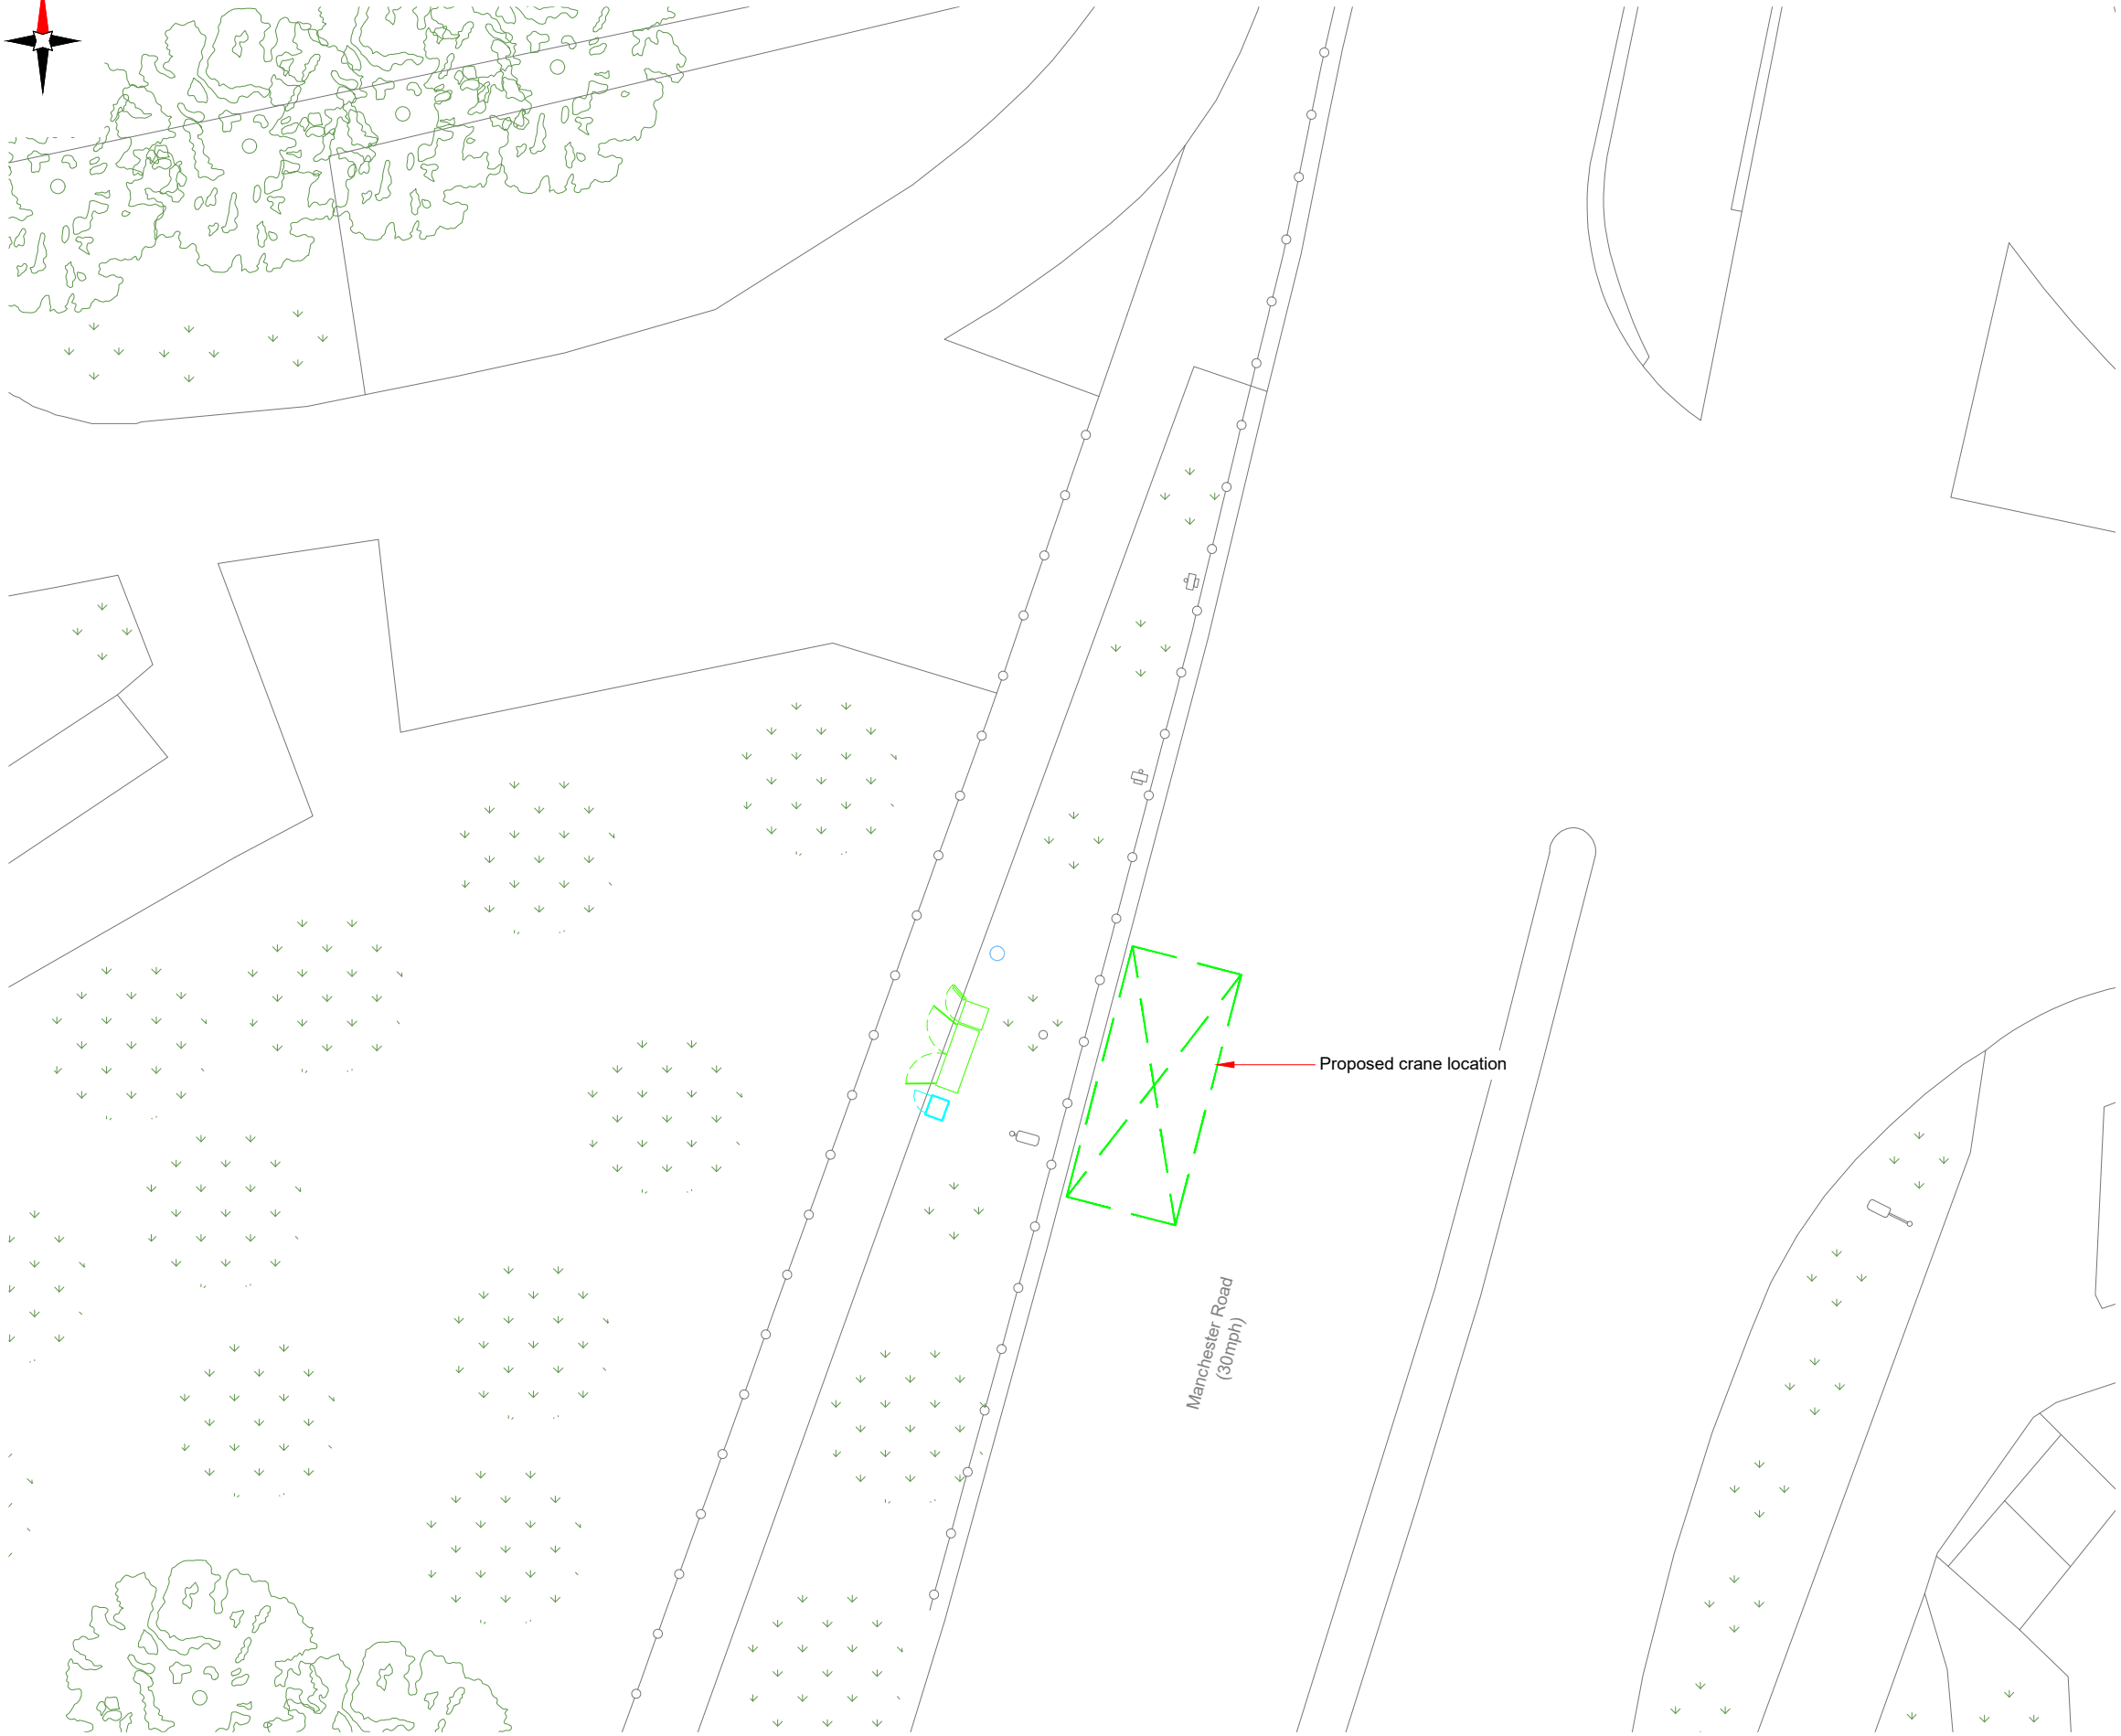

CHERRY PICKER / CRANE LOCATION PLAN



- NOTES:
- ALL DIMENSIONS IN MM UNLESS OTHERWISE NOTED.

PROPOSED CRANE OR CHERRY PICKER LOCATION:



Master:	MBNL / EE:	Project:	Purpose of Issue:	Issue:
M004	MBNL	3UK DNSW	Planning	D
Date:	03/07/2023	Revision / Upgrade Description:		
Drawn:	CDN	Pole type changed to Phase 9		
Checked:	DH			
Approved:	SD			
Master:	MBNL / EE:	Project:	Purpose of Issue:	Issue:
M003	MBNL	3UK DNSW	Planning	C
Date:	22/05/2023	Revision / Upgrade Description:		
Drawn:	CDN	Pole location amended		
Checked:	DH			
Approved:	SD			
Master:	MBNL / EE:	Project:	Purpose of Issue:	Issue:
M002	MBNL	3UK DNSW	Planning	B
Date:	09/03/2022	Revision / Upgrade Description:		
Drawn:	CDN	Pole type changed to Phase 9		
Checked:	DH			
Approved:	SD			
Master:	MBNL / EE:	Project:	Purpose of Issue:	Issue:
M001	MBNL	3UK DNSW	Planning	A
Date:	24/05/2021	Revision / Upgrade Description:		
Drawn:	CDN	First Issue - Site nomination dated: TBC		
Checked:	DH			
Approved:	SD			

CK Hutchison
Networks (UK)
Limited

Green Park
450 Longwater Avenue
Reading
RG30 3UR

Design Consultant & Principal Contractor:



WHP Telecoms

Unit 1 Maple Park,
Low Fields Avenue, Leeds
LS12 6HH

Tel: 01133023550
e-mail: info@whptelecoms.com

Site Name:
MANCHESTER ROAD STREETWORKS

Site ID:
ROD18035

Address:
MANCHESTER ROAD,
SUDDEN,
CASTLETON,
ROCHDALE,
OL11 4LL


Title:
005 CHERRY PICKER & CRANE LOCATION

Project:
3UK DNSW


Purpose of Issue:
GENERAL ARRANGEMENT

EE Cell ID: 83964	MBNL Cell ID: ROD167	Cell ID: OL0348
----------------------	-------------------------	--------------------

Master Drawing No: ROD18035_M004	Issue: D
-------------------------------------	-------------

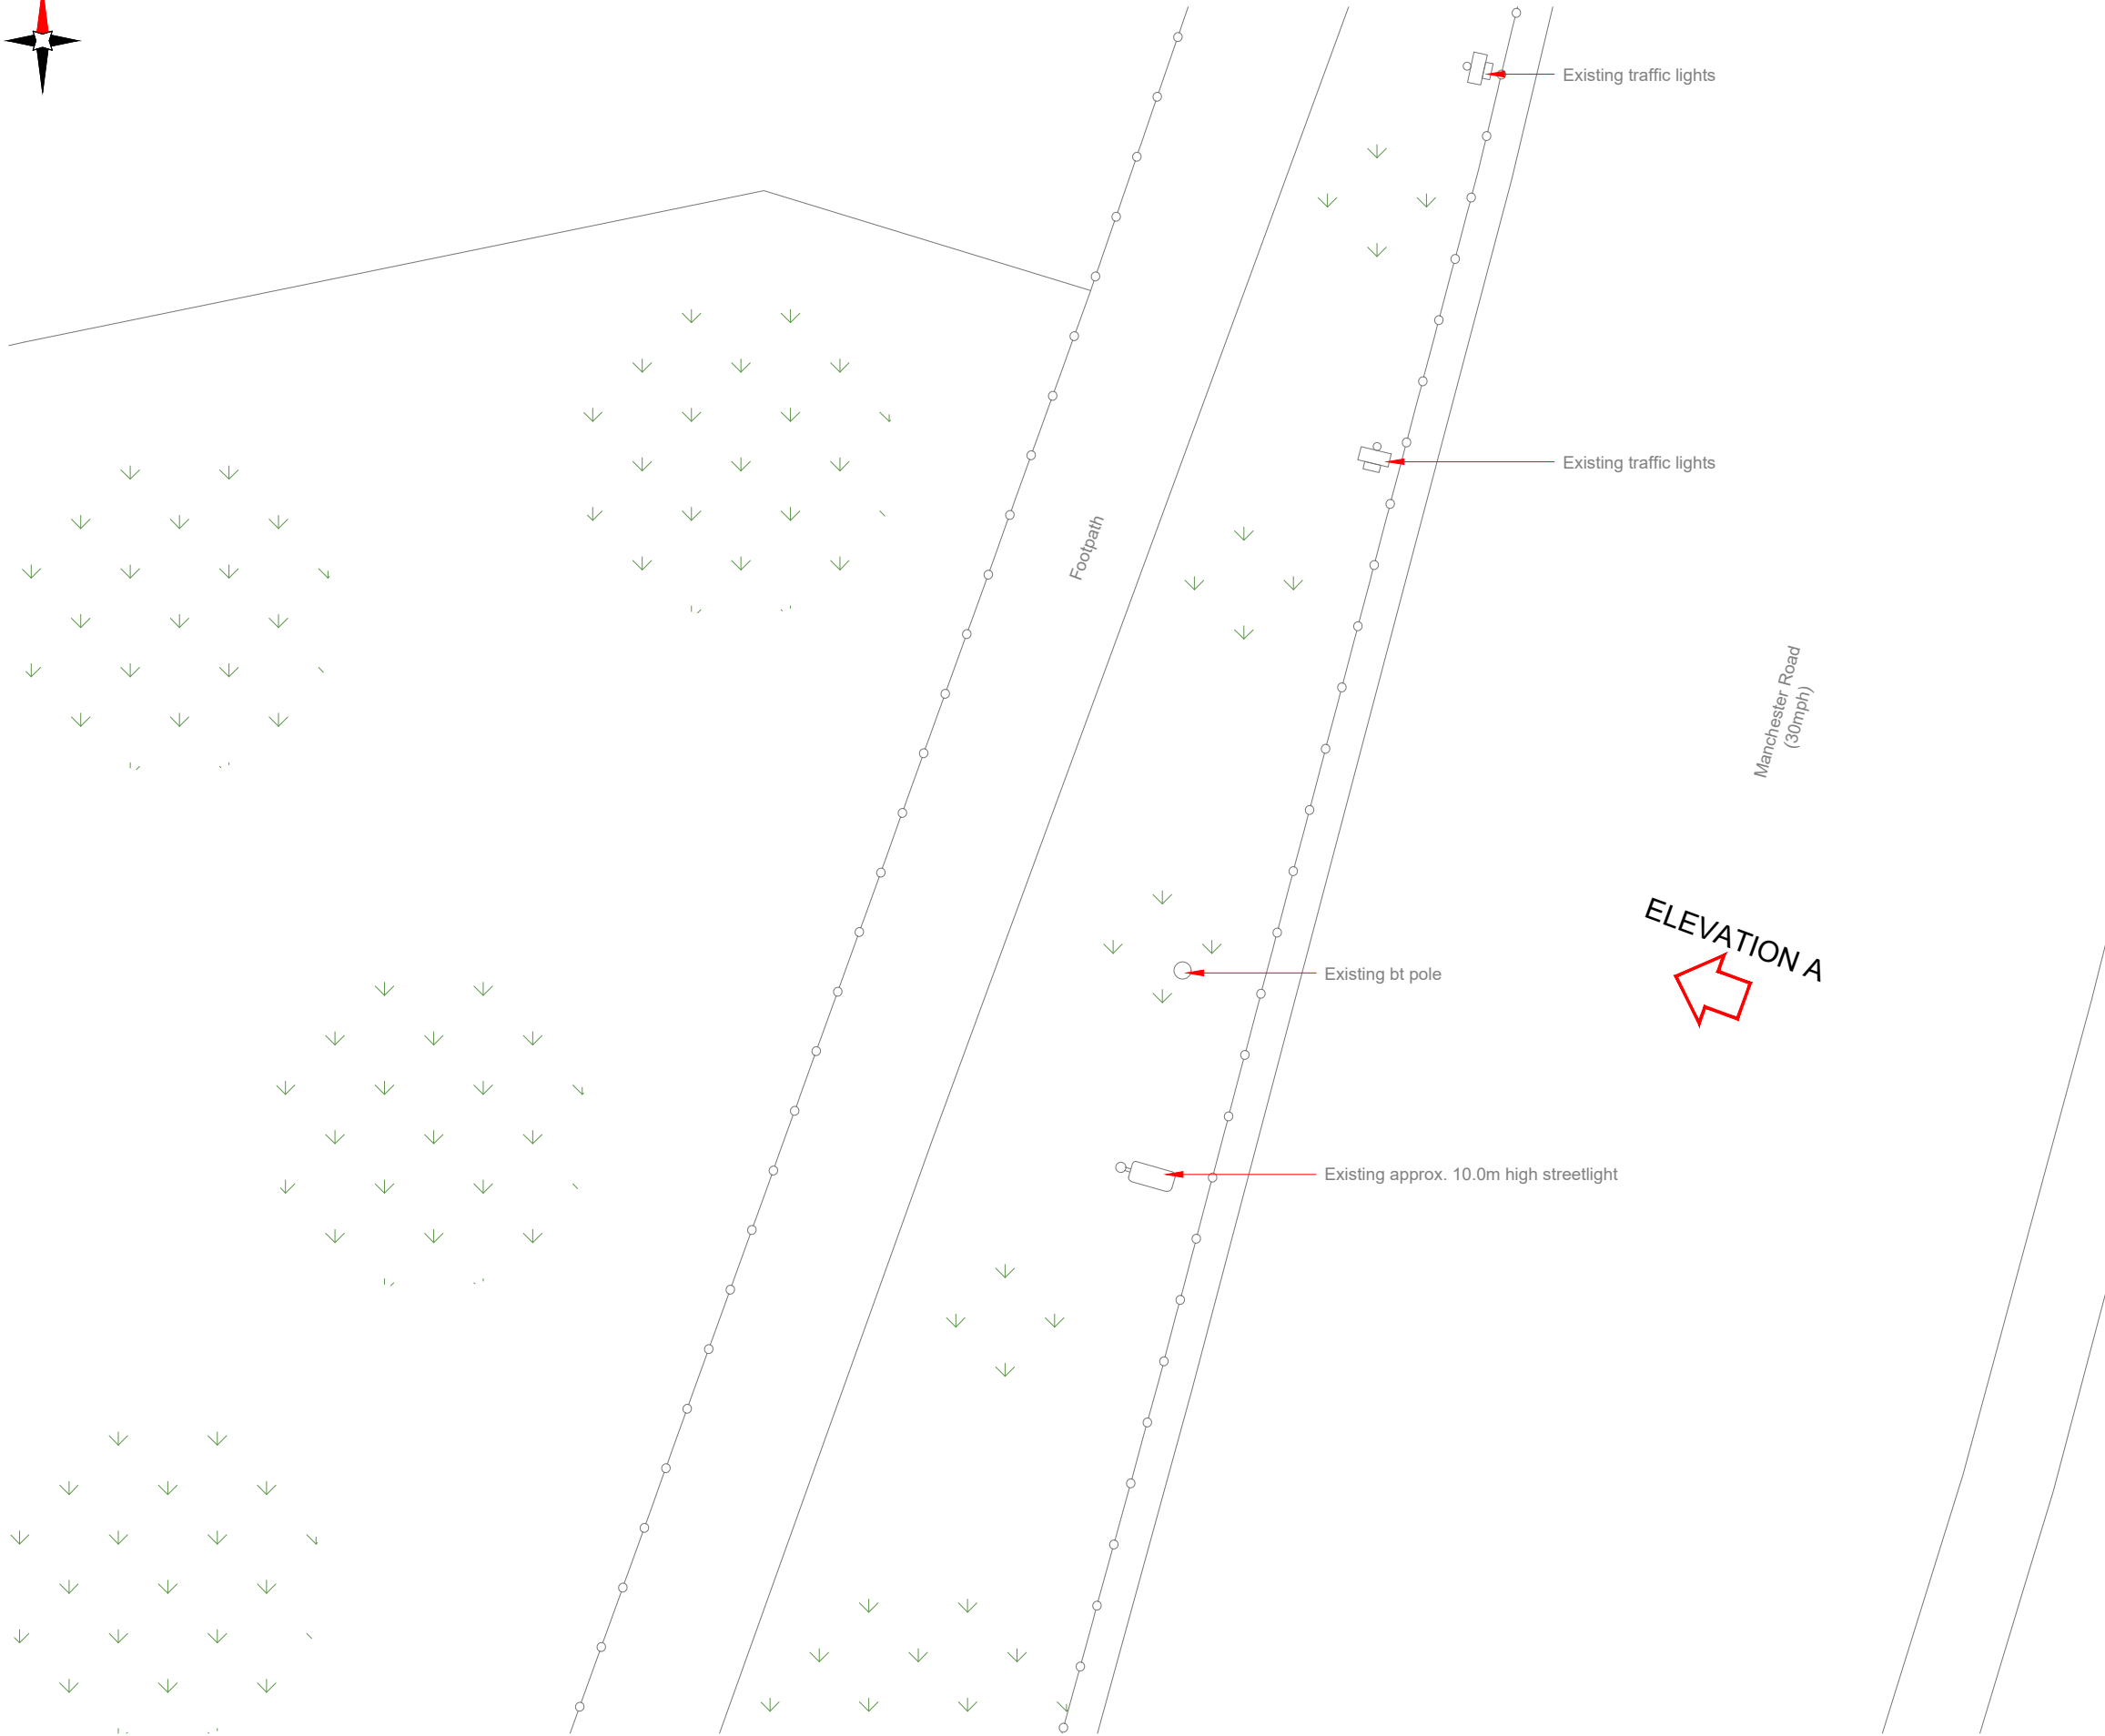

EXISTING SITE PLAN

 

100mm

150mm

10mm

- NOTES:
- ALL DIMENSIONS IN MM UNLESS OTHERWISE NOTED.

Master:	MBNL / EE:	Project:	Purpose of Issue:	Issue:
M004	MBNL	3UK DNSW	Planning	D
Date:	03/07/2023	Revision / Upgrade Description:		
Drawn:	CDN	Pole type changed to Phase 9		
Checked:	DH			
Approved:	SD			
Master:	MBNL / EE:	Project:	Purpose of Issue:	Issue:
M003	MBNL	3UK DNSW	Planning	C
Date:	22/05/2023	Revision / Upgrade Description:		
Drawn:	CDN	Pole location amended		
Checked:	DH			
Approved:	SD			
Master:	MBNL / EE:	Project:	Purpose of Issue:	Issue:
M002	MBNL	3UK DNSW	Planning	B
Date:	09/03/2022	Revision / Upgrade Description:		
Drawn:	CDN	Pole type changed to Phase 9		
Checked:	DH			
Approved:	SD			
Master:	MBNL / EE:	Project:	Purpose of Issue:	Issue:
M001	MBNL	3UK DNSW	Planning	A
Date:	24/05/2021	Revision / Upgrade Description:		
Drawn:	CDN	First Issue - Site nomination dated: TBC		
Checked:	DH			
Approved:	SD			

CK Hutchison
Networks (UK)
Limited

Green Park
450 Longwater Avenue
Reading
RG30 3UR

Design Consultant & Principal Contractor:



WHP Telecoms
Unit 1 Maple Park,
Low Fields Avenue, Leeds
LS12 6HH

Tel: 01133023550
e-mail: info@whptelecoms.com

Site Name:
MANCHESTER ROAD STREETWORKS

Site ID:
ROD18035

Address:
MANCHESTER ROAD,
SUDDEN,
CASTLETON,
ROCHDALE,
OL11 4LL

Title:
100 EXISTING SITE PLAN

Project:
3UK DNSW

Purpose of Issue:
GENERAL ARRANGEMENT


EE Cell ID: 83964	MBNL Cell ID: ROD167	Cell ID: OL0348
----------------------	-------------------------	--------------------

Master Drawing No: ROD18035_M004	Issue: D
-------------------------------------	-------------


100mm

150mm

10mm

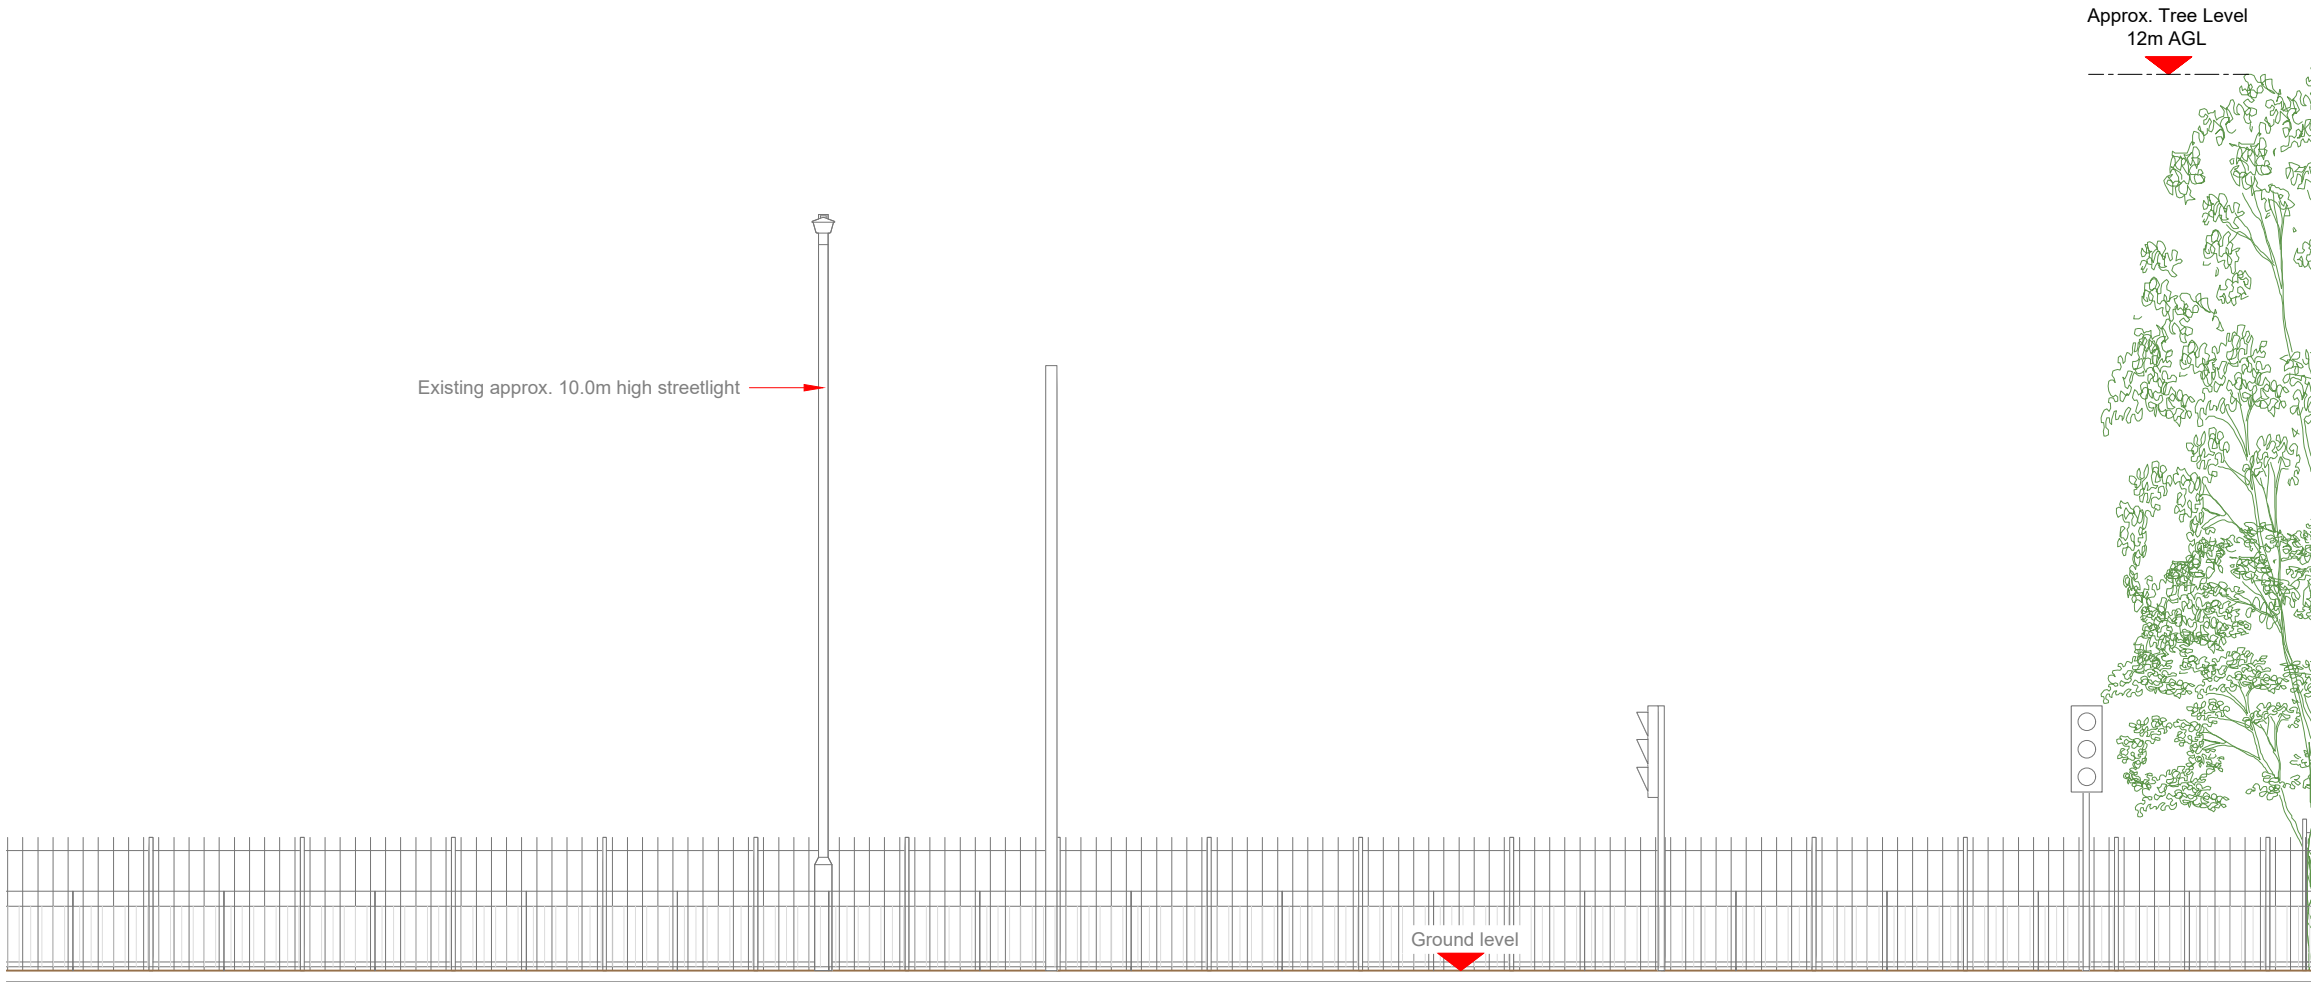

EXISTING ELEVATION A

 

- NOTES:
- ALL DIMENSIONS IN MM UNLESS OTHERWISE NOTED.

Master:	MBNL / EE:	Project:	Purpose of Issue:	Issue:
M004	MBNL	3UK DNSW	Planning	D
Date:	03/07/2023	Revision / Upgrade Description:		
Drawn:	CDN	Pole type changed to Phase 9		
Checked:	DH			
Approved:	SD			
Master:	MBNL / EE:	Project:	Purpose of Issue:	Issue:
M003	MBNL	3UK DNSW	Planning	C
Date:	22/05/2023	Revision / Upgrade Description:		
Drawn:	CDN	Pole location amended		
Checked:	DH			
Approved:	SD			
Master:	MBNL / EE:	Project:	Purpose of Issue:	Issue:
M002	MBNL	3UK DNSW	Planning	B
Date:	09/03/2022	Revision / Upgrade Description:		
Drawn:	CDN	Pole type changed to Phase 9		
Checked:	DH			
Approved:	SD			
Master:	MBNL / EE:	Project:	Purpose of Issue:	Issue:
M001	MBNL	3UK DNSW	Planning	A
Date:	24/05/2021	Revision / Upgrade Description:		
Drawn:	CDN	First Issue - Site nomination dated: TBC		
Checked:	DH			
Approved:	SD			

CK Hutchison
Networks (UK)
Limited

Green Park
450 Longwater Avenue
Reading
RG30 3UR

Design Consultant & Principal Contractor:



WHP Telecoms
Unit 1 Maple Park,
Low Fields Avenue, Leeds
LS12 6HH

Tel: 01133023550
e-mail: info@whptelecoms.com

Site Name:
MANCHESTER ROAD STREETWORKS

Site ID:
ROD18035

Address:

MANCHESTER ROAD,
SUDDEN,
CASTLETON,
ROCHDALE,
OL11 4LL


Title:
150 EXISTING ELEVATION A

Project:
3UK DNSW


Purpose of Issue:
GENERAL ARRANGEMENT

EE Cell ID: 83964	MBNL Cell ID: ROD167	Cell ID: OL0348
----------------------	-------------------------	--------------------

Master Drawing No: ROD18035_M004	Issue: D
-------------------------------------	-------------

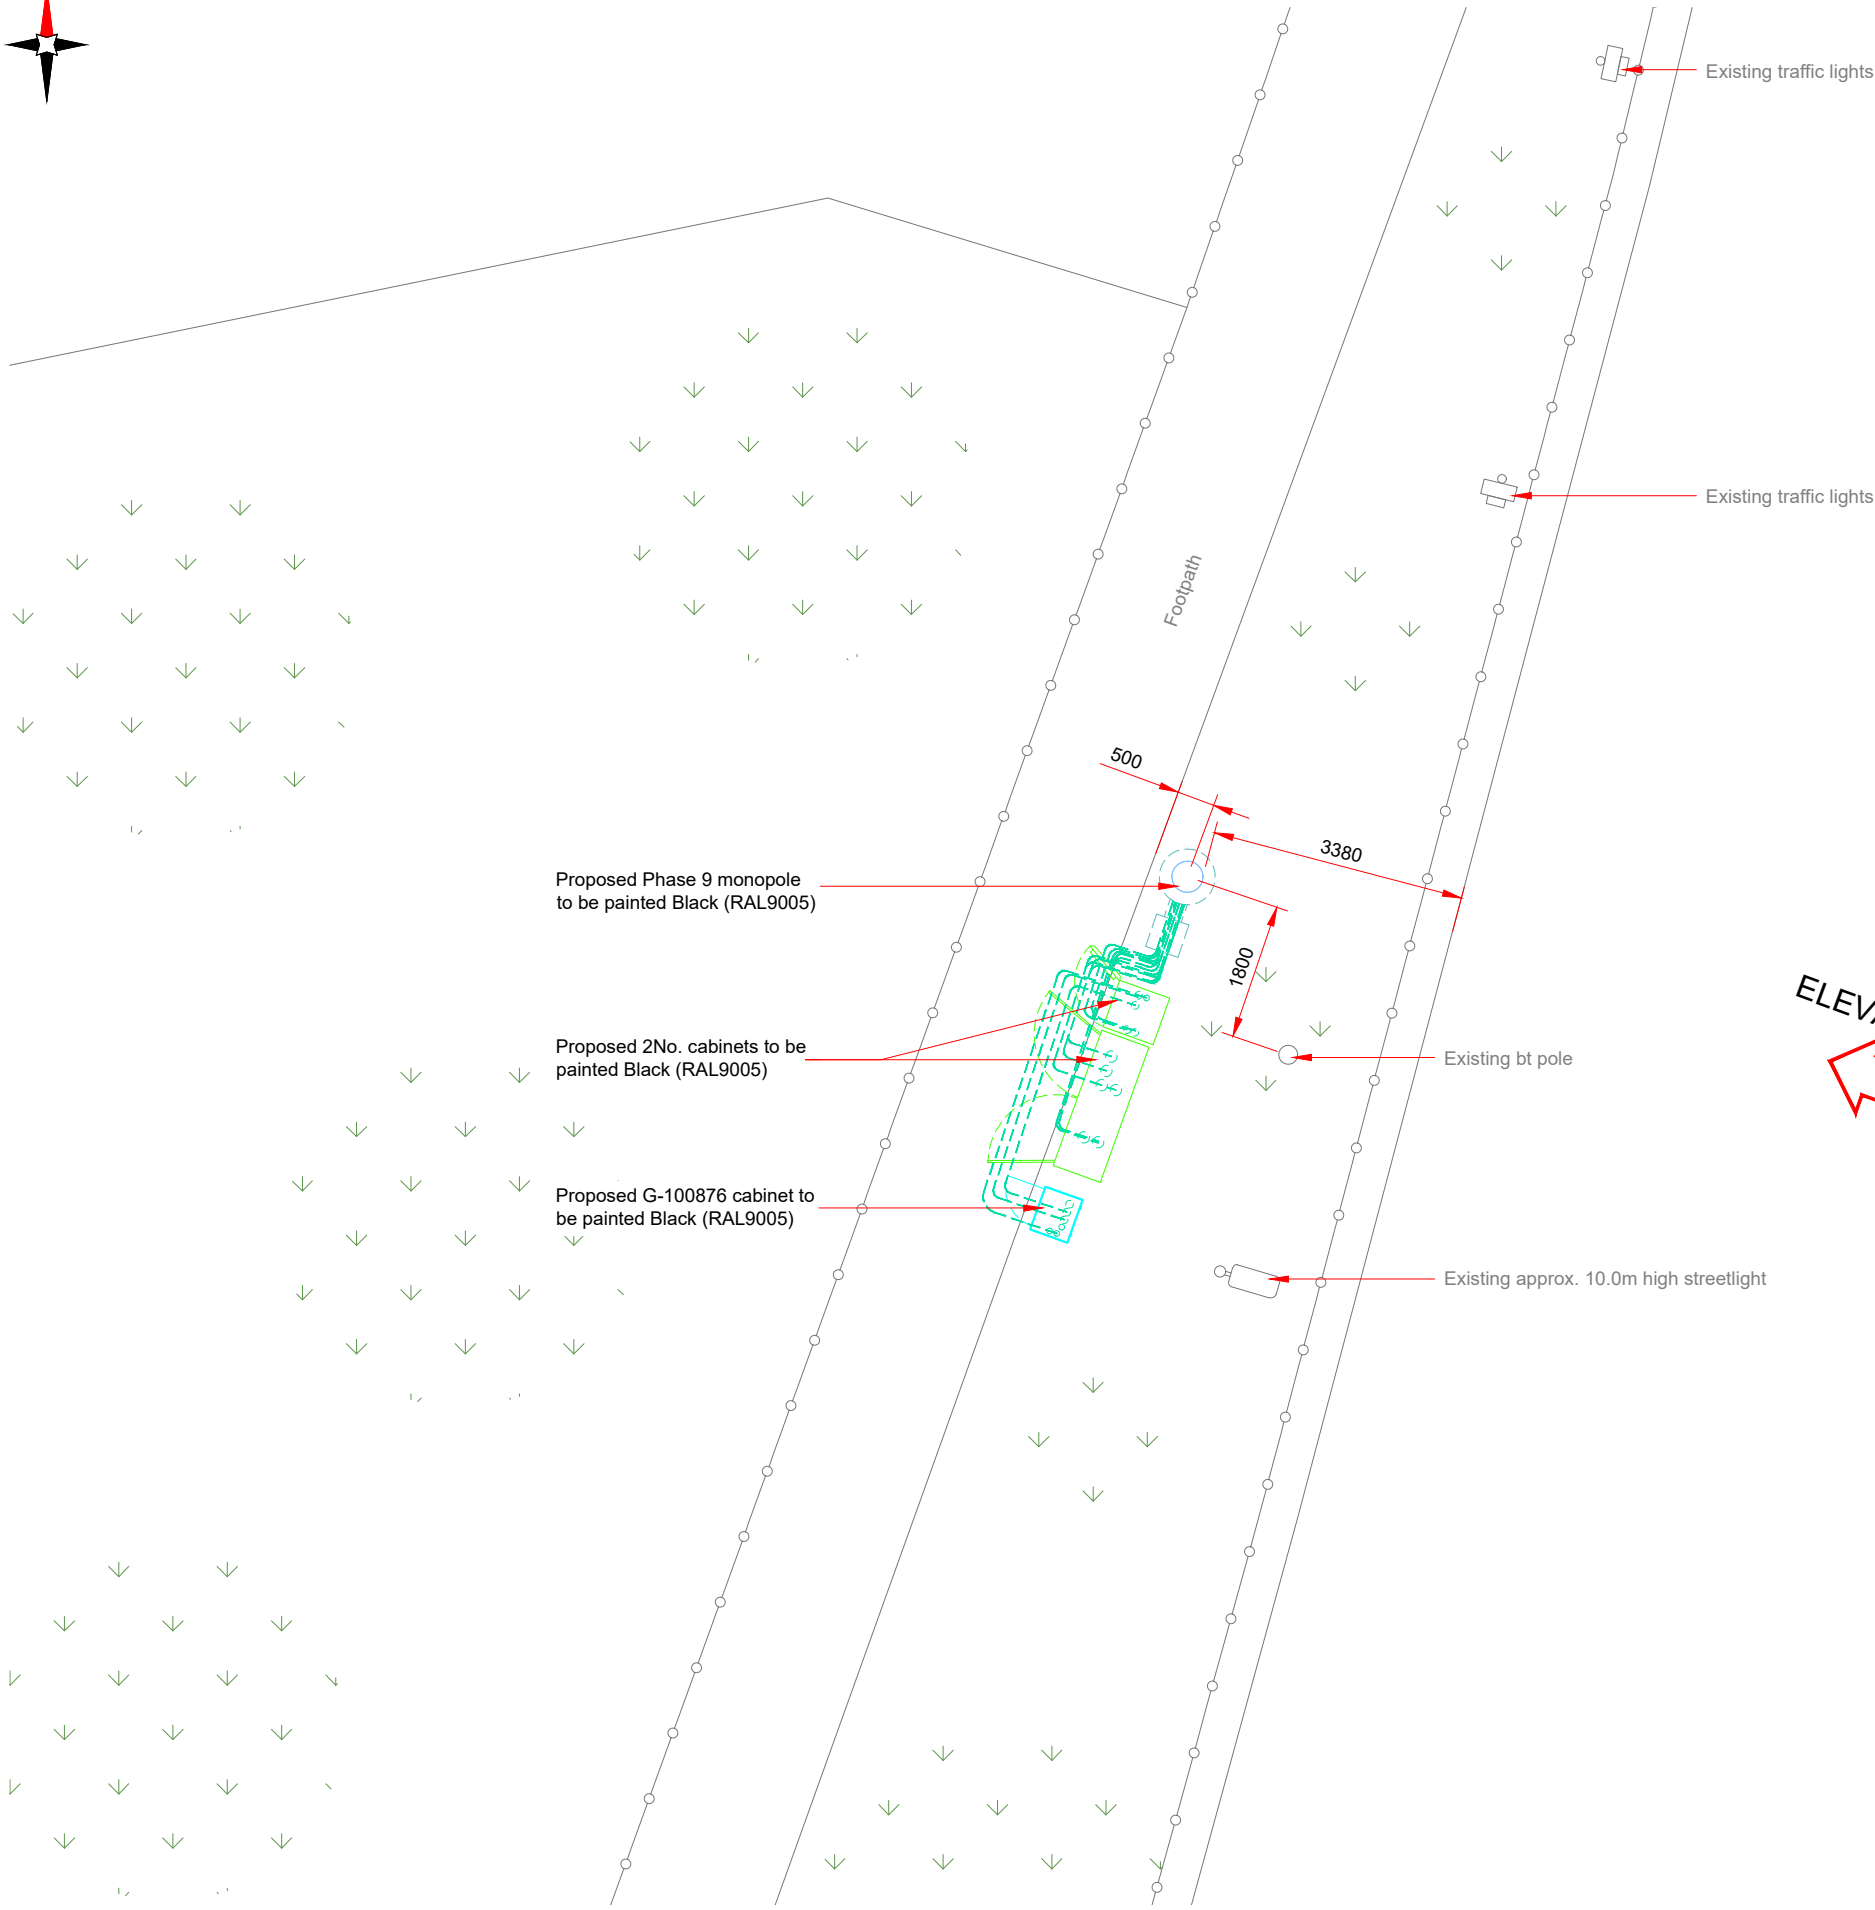

PROPOSED SITE PLAN

 

Antenna Aperture ID	Proposed 4G/5G Bearing
A1	40°
B1	160°
C1	280°
A2	40°
B2	160°
C2	280°

NOTES:
1. ALL DIMENSIONS IN MM UNLESS OTHERWISE NOTED.

Master:	MBNL / EE:	Project:	Purpose of Issue:	Issue:
M004	MBNL	3UK DNSW	Planning	D
Date:	03/07/2023	Revision / Upgrade Description:		
Drawn:	CDN	Pole type changed to Phase 9		
Checked:	DH			
Approved:	SD			
Master:	MBNL / EE:	Project:	Purpose of Issue:	Issue:
M003	MBNL	3UK DNSW	Planning	C
Date:	22/05/2023	Revision / Upgrade Description:		
Drawn:	CDN	Pole location amended		
Checked:	DH			
Approved:	SD			
Master:	MBNL / EE:	Project:	Purpose of Issue:	Issue:
M002	MBNL	3UK DNSW	Planning	B
Date:	09/03/2022	Revision / Upgrade Description:		
Drawn:	CDN	Pole type changed to Phase 9		
Checked:	DH			
Approved:	SD			
Master:	MBNL / EE:	Project:	Purpose of Issue:	Issue:
M001	MBNL	3UK DNSW	Planning	A
Date:	24/05/2021	Revision / Upgrade Description:		
Drawn:	CDN	First Issue - Site nomination dated: TBC		
Checked:	DH			
Approved:	SD			

CK Hutchison Networks (UK) Limited

Green Park
450 Longwater Avenue
Reading
RG30 3UR

Design Consultant & Principal Contractor:



WHP Telecoms

Unit 1 Maple Park,
Low Fields Avenue, Leeds
LS12 6HH

Tel: 01133023550
e-mail: info@whptelecoms.com

Site Name:
MANCHESTER ROAD STREETWORKS

Site ID:
ROD18035

Address:
MANCHESTER ROAD,
SUDDEN,
CASTLETON,
ROCHDALE,
OL11 4LL

Title:
210 PROPOSED SITE PLAN

Project:
3UK DNSW

Purpose of Issue:
GENERAL ARRANGEMENT

EE Cell ID: 83964	MBNL Cell ID: ROD167	Cell ID: OL0348
----------------------	-------------------------	--------------------

Master Drawing No: ROD18035_M004	Issue: D
-------------------------------------	-------------

Antenna Aperture ID	Proposed 4G/5G Bearing
A1	40°
B1	160°
C1	280°
A2	40°
B2	160°
C2	280°

NOTES:

1. ALL DIMENSIONS IN MM UNLESS OTHERWISE NOTED.

Master:	MBNL / EE:	Project:	Purpose of Issue:	Issue:
M004	MBNL	3UK DNSW	Planning	D
Date:	03/07/2023	Revision / Upgrade Description:		
Drawn:	CDN	Pole type changed to Phase 9		
Checked:	DH			
Approved:	SD			
Master:	MBNL / EE:	Project:	Purpose of Issue:	Issue:
M003	MBNL	3UK DNSW	Planning	C
Date:	22/05/2023	Revision / Upgrade Description:		
Drawn:	CDN	Pole location amended		
Checked:	DH			
Approved:	SD			
Master:	MBNL / EE:	Project:	Purpose of Issue:	Issue:
M002	MBNL	3UK DNSW	Planning	B
Date:	09/03/2022	Revision / Upgrade Description:		
Drawn:	CDN	Pole type changed to Phase 9		
Checked:	DH			
Approved:	SD			
Master:	MBNL / EE:	Project:	Purpose of Issue:	Issue:
M001	MBNL	3UK DNSW	Planning	A
Date:	24/05/2021	Revision / Upgrade Description:		
Drawn:	CDN	First Issue - Site nomination dated: TBC		
Checked:	DH			
Approved:	SD			

CK Hutchison
Networks (UK)
Limited

Green Park
450 Longwater Avenue
Reading
RG30 3UR

Design Consultant & Principal Contractor:



WHP Telecoms

Unit 1 Maple Park,
Low Fields Avenue, Leeds
LS12 6HH

Tel: 01133023550
e-mail: info@whptelecoms.com

Site Name:
MANCHESTER ROAD STREETWORKS

Site ID:
ROD18035

Address:

MANCHESTER ROAD,
SUDDEN,
CASTLETON,
ROCHDALE,
OL11 4LL

Title:
260 PROPOSED ELEVATION

Project:
3UK DNSW

Purpose of Issue:
GENERAL ARRANGEMENT

EE Cell ID: 83964	MBNL Cell ID: ROD167	Cell ID: OL0348
----------------------	-------------------------	--------------------

Master Drawing No: ROD18035_M004	Issue: D
-------------------------------------	-------------

