


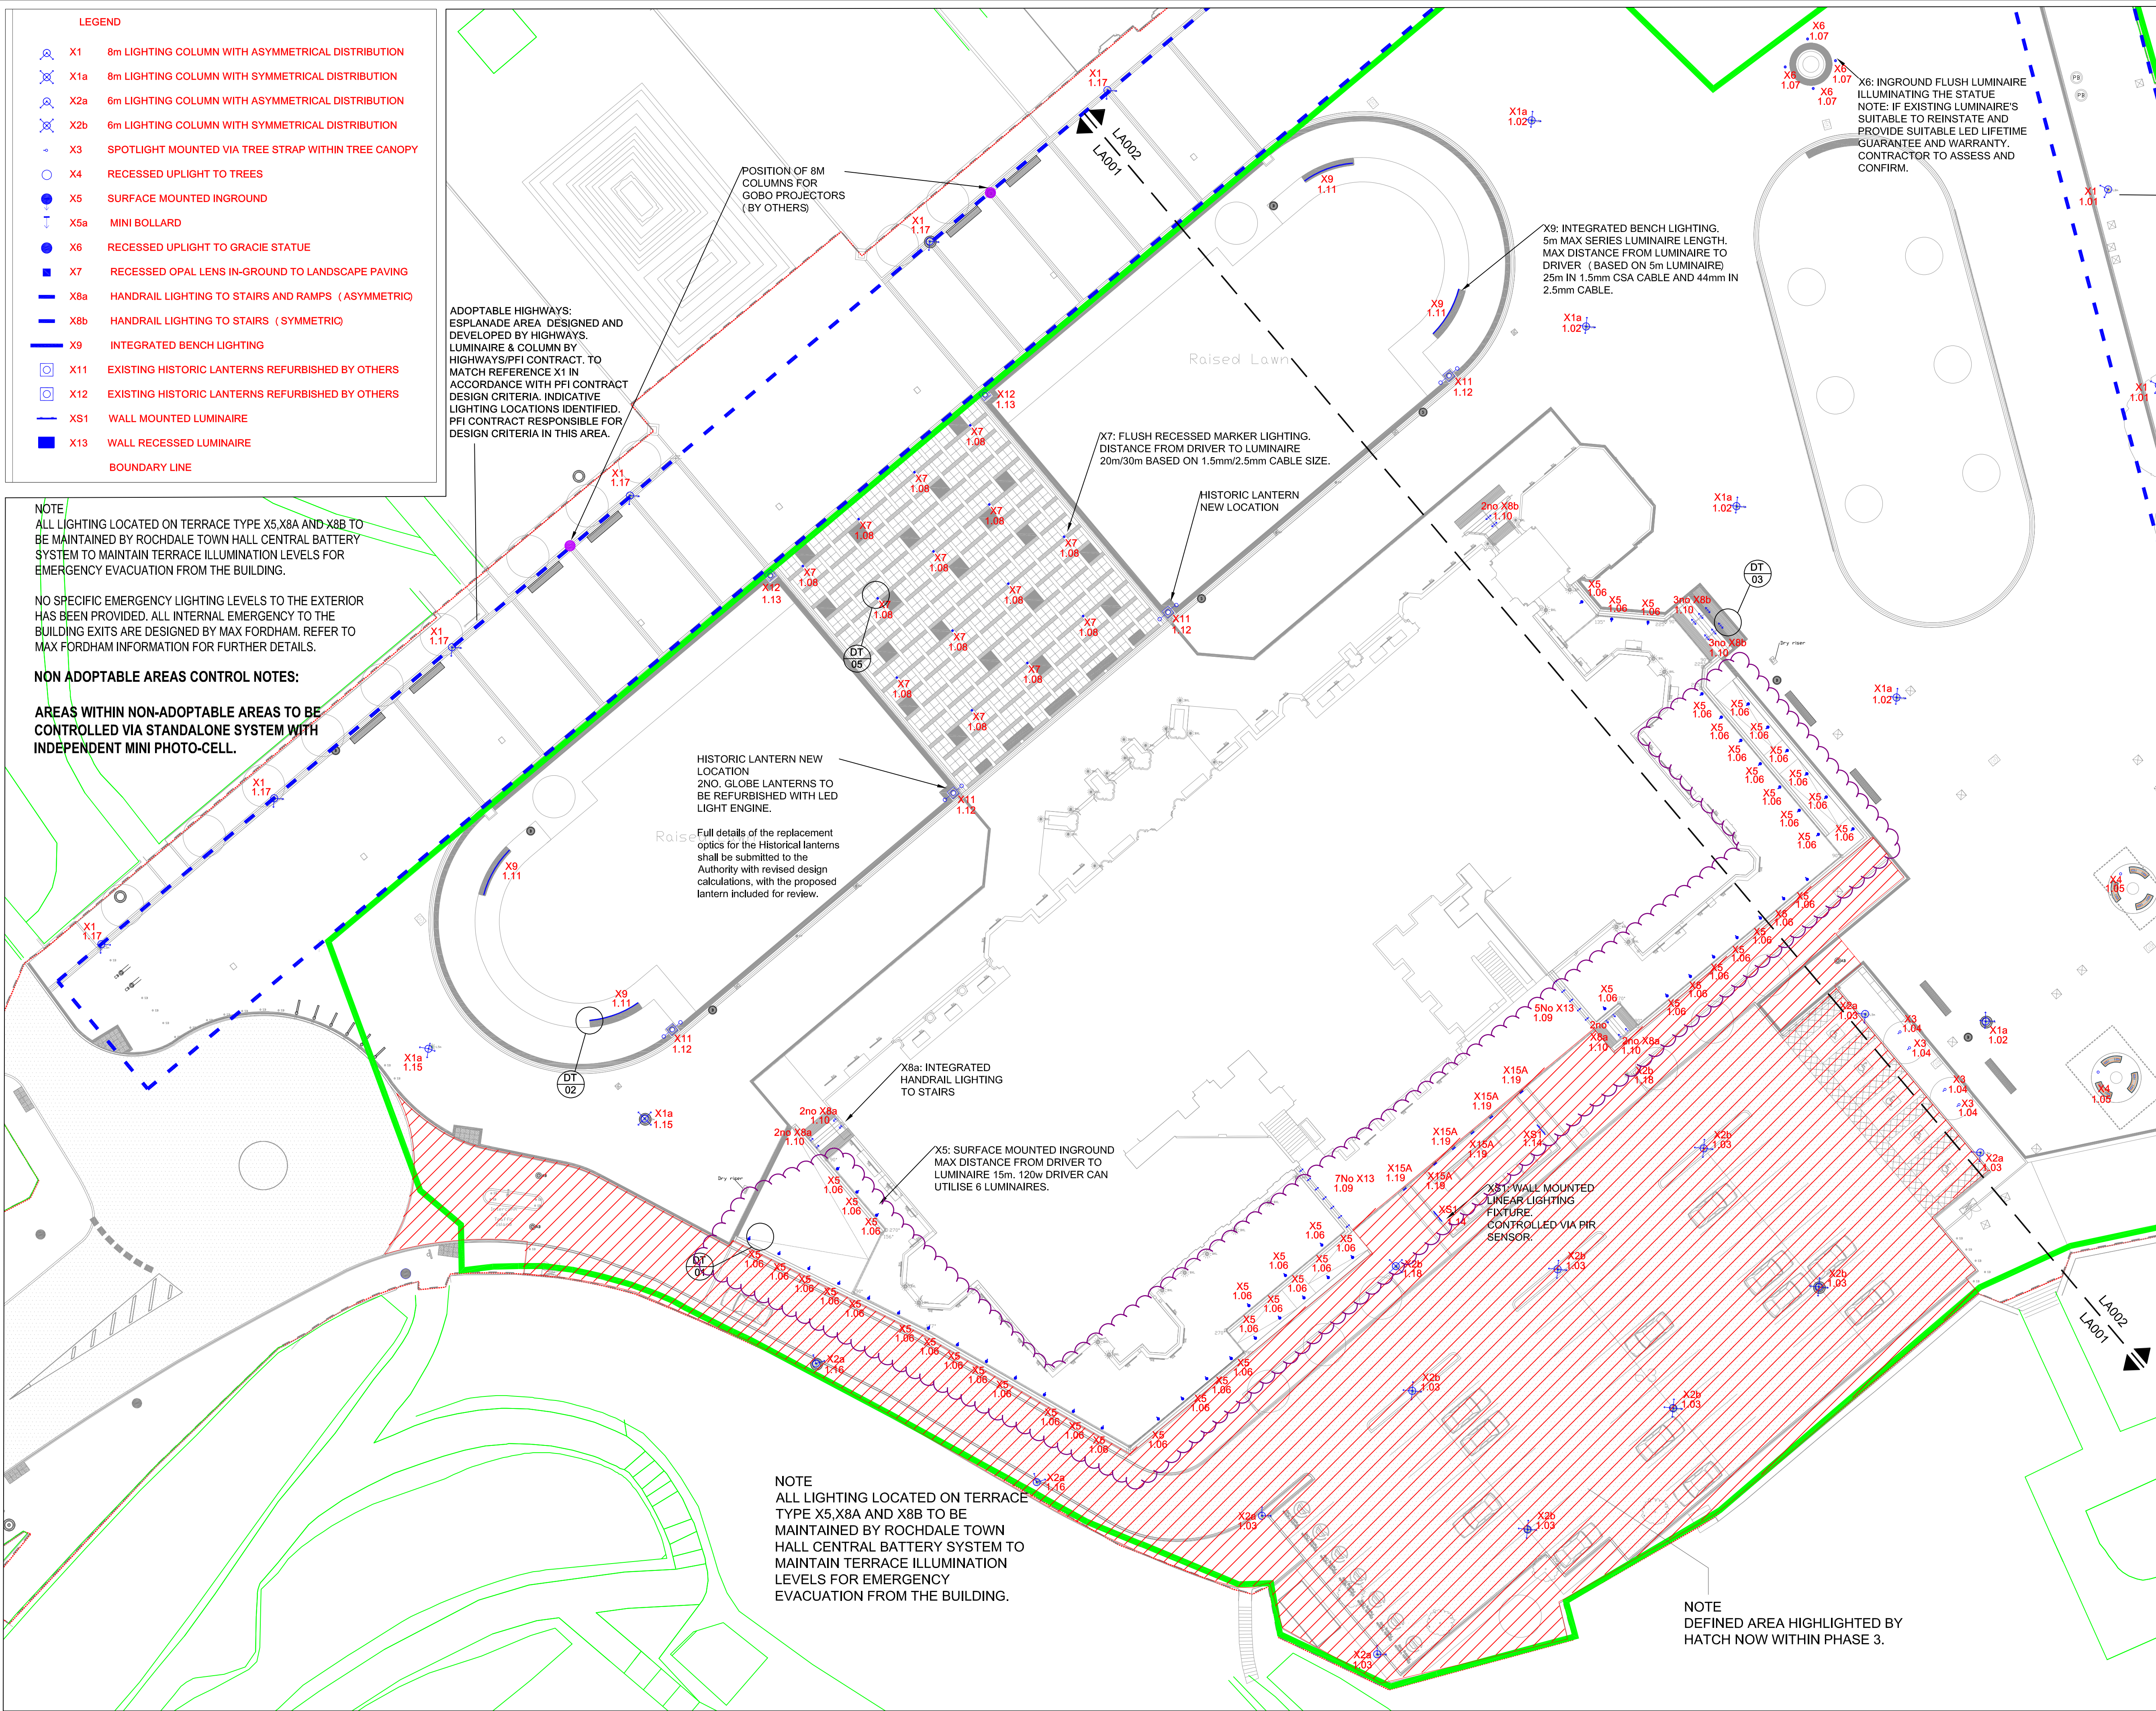

© Buro Happold Limited or its group companies.
All Rights reserved. Buro Happold and its group companies assert (unless otherwise agreed in writing) their rights under s.77 to 80 of the Copyright, Designs and Patents Act 1988.
DO NOT SCALE THIS DRAWING.

HEALTH AND SAFETY INFORMATION

IN ADDITION TO THE HAZARDS/RISKS NORMALLY ASSOCIATED WITH THE TYPES OF WORK DETAILED ON THIS DRAWING, NOTE THE FOLLOWING CONSTRUCTION.

MAINTENANCE/CLEANING/OPERATION

DECOMMISSIONING/DEMOLITION

Notes

LIGHTING NOTES

- THIS DRAWING IS TO BE READ IN CONJUNCTION WITH ALL OTHER DISCIPLINES, DRAWINGS, SCHEDULES AND SPECIFICATIONS. LEGENDS AND STANDARD DETAILS.
- THIS DRAWING IS COPYRIGHT AND SHALL NOT BE REPRODUCED WITHOUT PERMISSION.
- DIMENSIONS GOVERN ON ALL DRAWINGS AND DETAILS. SHOULD ANY DISCREPANCIES BE FOUND WITH THIS DRAWING AND ANY ASSOCIATED DRAWINGS OR SPECIFICATIONS THIS SHOULD BE BROUGHT TO THE ATTENTION OF THE M&E BUILDING SERVICES CONSULTANT IMMEDIATELY.
- UNLESS OTHERWISE STATED ALL DIMENSIONS ARE IN MILLIMETRES.
- DO NOT SCALE FROM THIS DRAWING.
- DIMENSIONS TO BE CHECKED ON SITE BEFORE ANY WORK IS PUT IN HAND OR PREFABRICATED.
- THIS DRAWING SHOULD ONLY BE USED FOR THE SPECIFIC SERVICES INTENDED.
- THIS DRAWING SHOWS THE DESIGN INTENT ONLY. THE CONTRACTOR SHALL BE RESPONSIBLE FOR THE FULL CO-ORDINATION OF THE SERVICES INDICATED ON THIS AND ALL OTHER SERVICES DRAWINGS.
- FINAL ACCESS AND SETTING OUT OF SERVICES SHALL BE AGREED BETWEEN THE ARCHITECT AND THE CONTRACTOR.
- THE PROJECT NOTES ARE TO BE READ IN CONJUNCTION WITH ALL RELEVANT TECHNICAL SPECIFICATIONS.
- FOR THE SPECIFICATION OF ALL LUMINAIRES PLEASE REFER TO THE LUMINAIRE SCHEDULE.

FOR ADOPTABLE HIGHWAY LIGHTING DESIGN LAYOUT AND STANDARD DETAILS FOR ESPLANADE REFER TO ROCHDALE COUNCIL DRAWINGS:

PD067-12-14-1302-01
PD067-12-14-1401-01

THE CONTRACTOR MUST CONSULT AND COMPLY WITH ALL THE REQUIREMENTS OF OLDHAM AND ROCHDALE COUNCIL'S STREET LIGHTING PFI SPECIFICATION AND THE SPECIFICATION OF ROAD LIGHTING.

ANY PROPOSED COLUMN POSITIONS ARE TO BE JOINTLY MARKED OUR ON SITE BY THE ROCHDALE MBC STREET LIGHTING ENGINEER.

C04	Construction - Lighting location update	03/03/23	AR	CH
C03	Construction - Packer street update	31/10/22	AR	CH
C02	Construction - Packer street update	04/08/22	AR	CH
C01	Construction	06/07/22	AR	CH
10	Tree lighting omitted - Clouded	07/06/22	AR	CH
09	Bench light omitted - Clouded	04/05/22	LK	AR
08	Design change	29/03/22	LK	AR
07	Terrace update	25/11/21	AR	CH
06	Terrace update	01/10/21	AR	CH
05	Stage 4 - For Tender	26/05/21	AR	CH
04	Stage 4 - PFI Approval	03/05/21	AR	CH
03	Stage 4	26/01/21	LK	AR
02	Stage 4	11/12/20	LK	AR
01	For information	16/04/20	LK	AR

Rev Description Date Drawn By Approved

CONSTRUCTION

Status/Suitability of drawing

**BUROHAPPOLD
ENGINEERING**

17 Newiman Street
London
W1T 3EQ
UK

Tel: +44 (0)20 7627 9790
Fax: +44 (0)20 787 4145
Web: www.burohappold.com

Architect **GILLESPIES**
Project **ROCHDALE TOWN HALL SQUARE**
Drg Title **Lighting layout Sheet 1**

Scales@A1 **1:250** Job No. **0042509**

Drawing No. **042509_LA001** Revision **C04**