


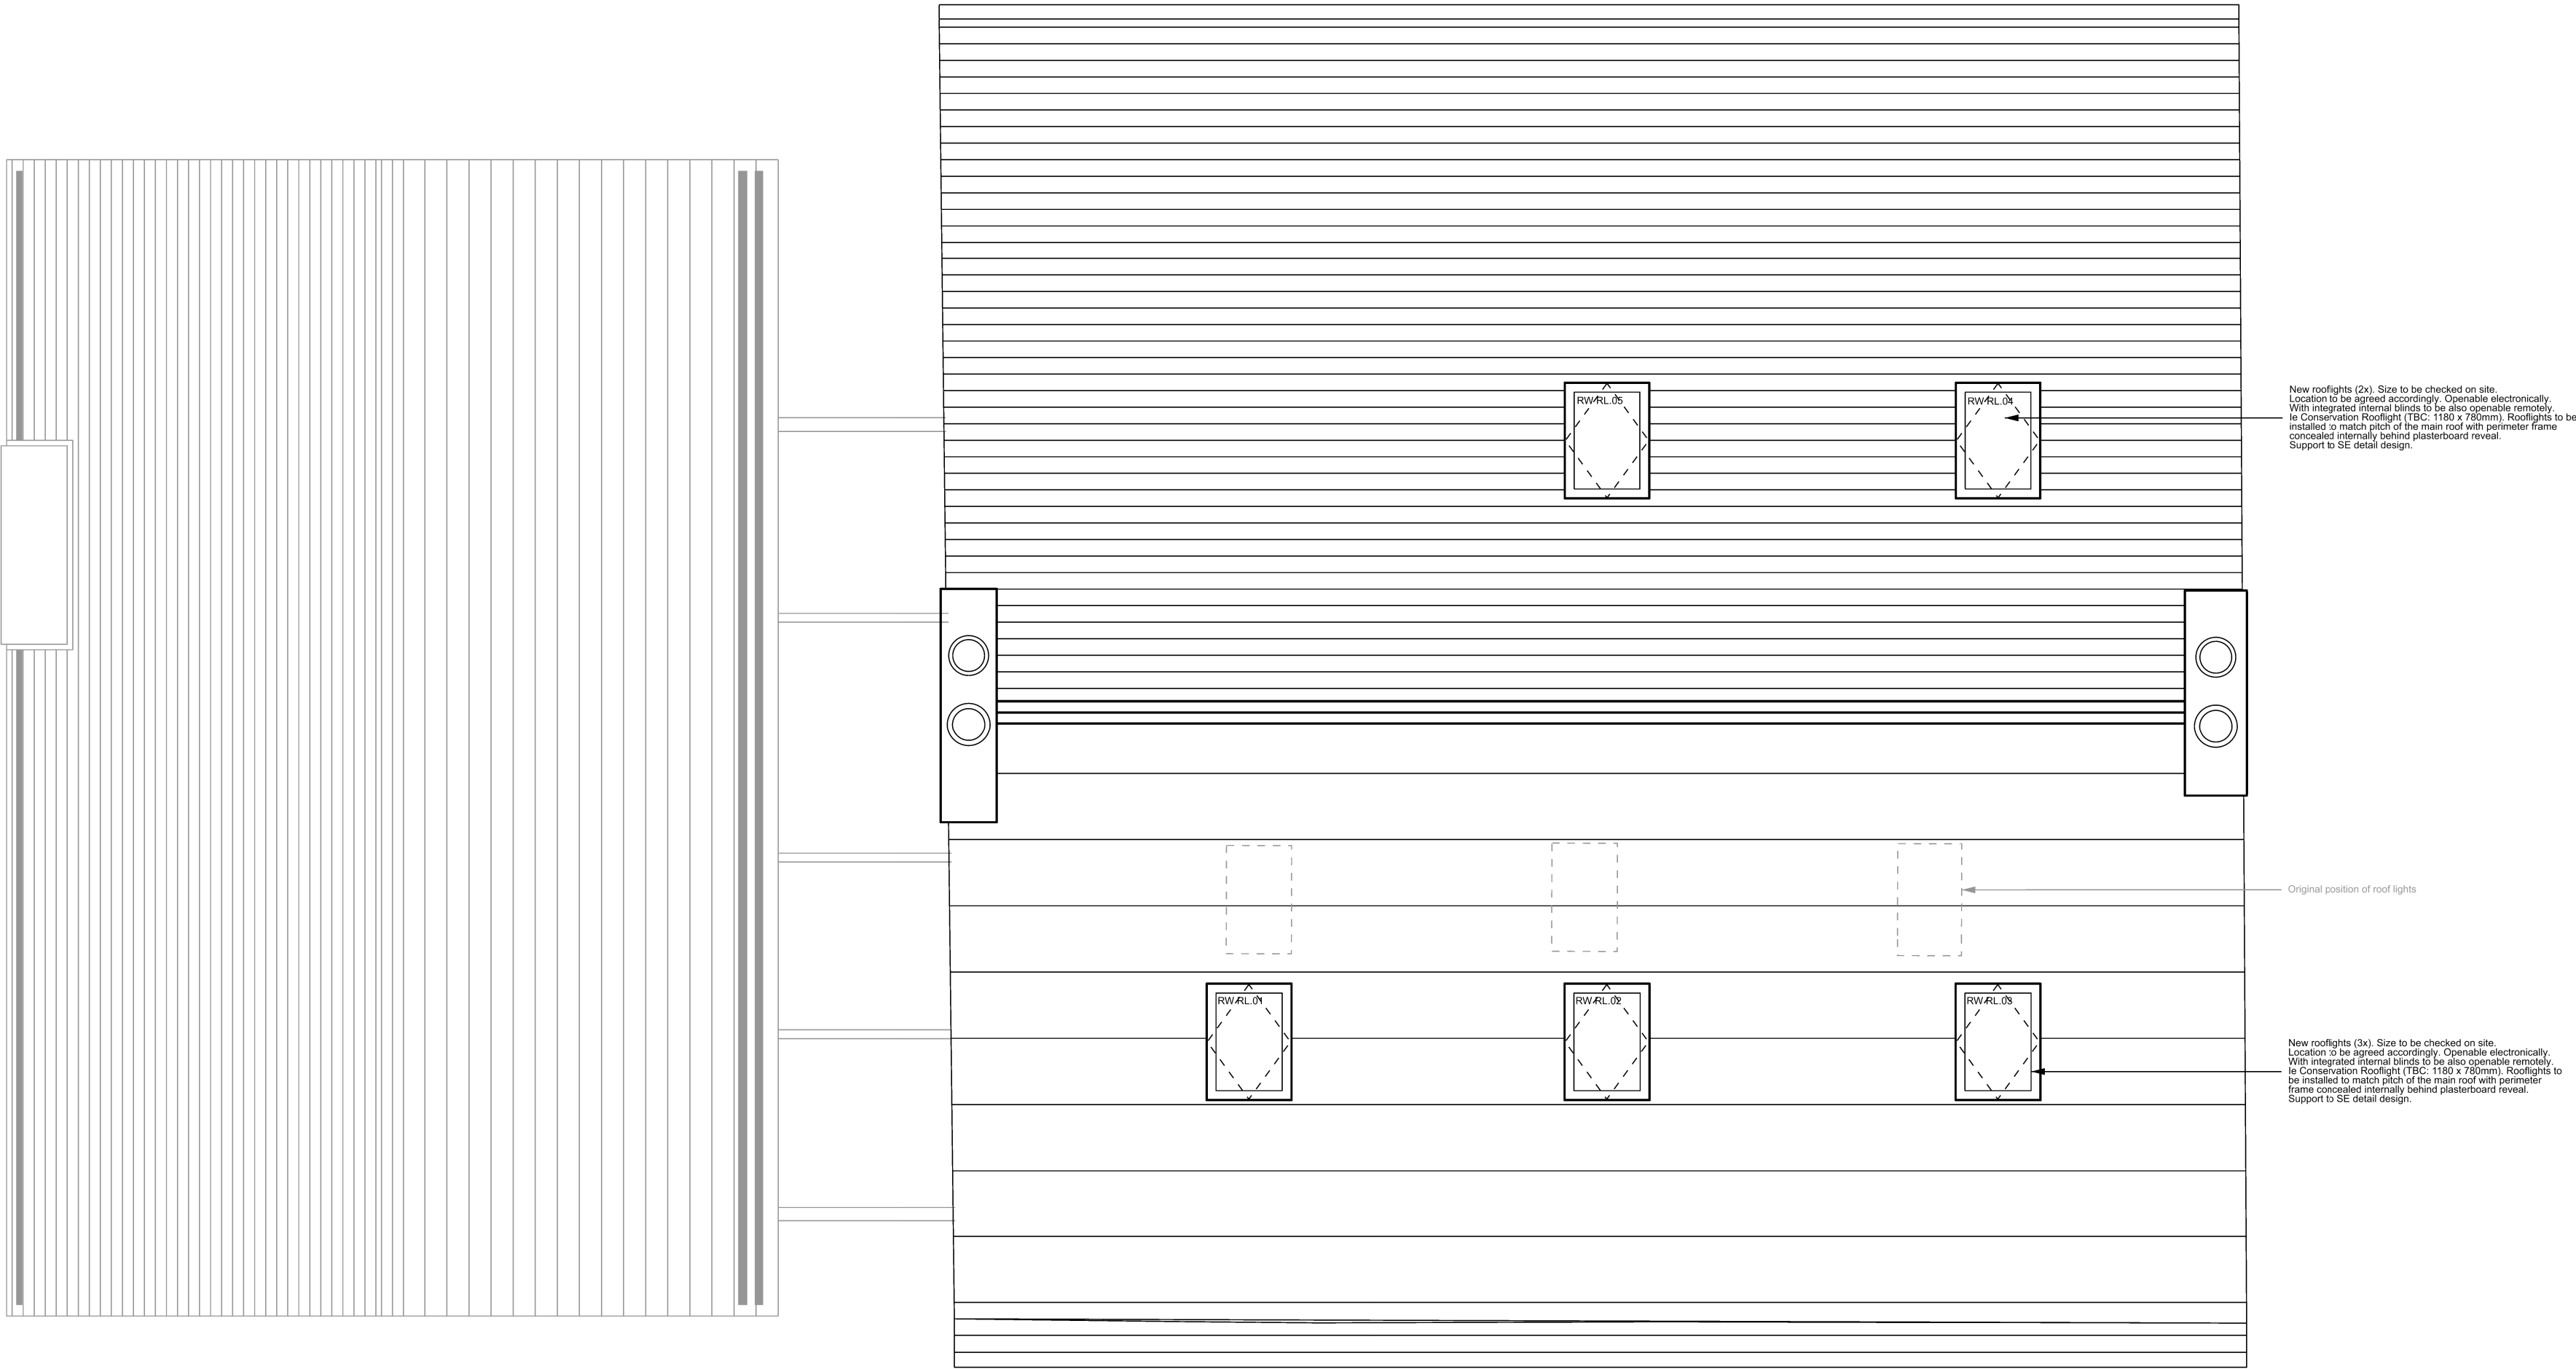

Notes:

Do not scale from this drawing.

All dimensions are in millimetres unless otherwise noted.

All dimensions to be checked on site before proceeding with work.

 
All omissions and discrepancies to be reported in writing to Project 3 Architects Ltd.

Areas indicated on this drawing are approximate and indicative only.

© Project 3 Architects Limited Registered in England & Wales Number 08021795.

- Notes:**
- These are Design Intent drawings for Planning Condition 4 discharge.
 - All to be in line with British Standards, other relevant standards and Building Regulations.
 - All to be in line with fire, acoustic, structural and any other relevant project specific requirements.
 - All works to be done with Health and Safety measures in place.
- Roof lights specification:**
- Product supplier: Velux
 - Conservation Rooflight type MK 06
 - Size: 1180 x 780 mm
 - Colour: Black/dark grey to match roof finish
 - Double glazed unit, all in line with Building Regulations and British Standards
 - Remotely controlled - openable via solar kit
 - Remotely controlled - internal blinds

P01 10/04/25 PC 4 AS
Rev: Date: Description: By:



PROJECT3
architects

4 back grafton street
altrincham
cheshire
WA14 1DY

0161 233 0575
mail@project3architects.com
www.project3architects.com

Project:
The Farmhouse
Littleborough
Title:
Farmhouse: PC 4
Roof lights: Roof Plan
Status: Scale @ ISO A1:
PLANNING CONDITION 4 1:50
Drawing Number: Revision:
0763-P3A-XX-XX-DR-A-05310 P01

PROPOSED ROOF PLAN
PLANNING CONDITION 4 : ROOF LIGHTS
scale 1:50 @ A1