




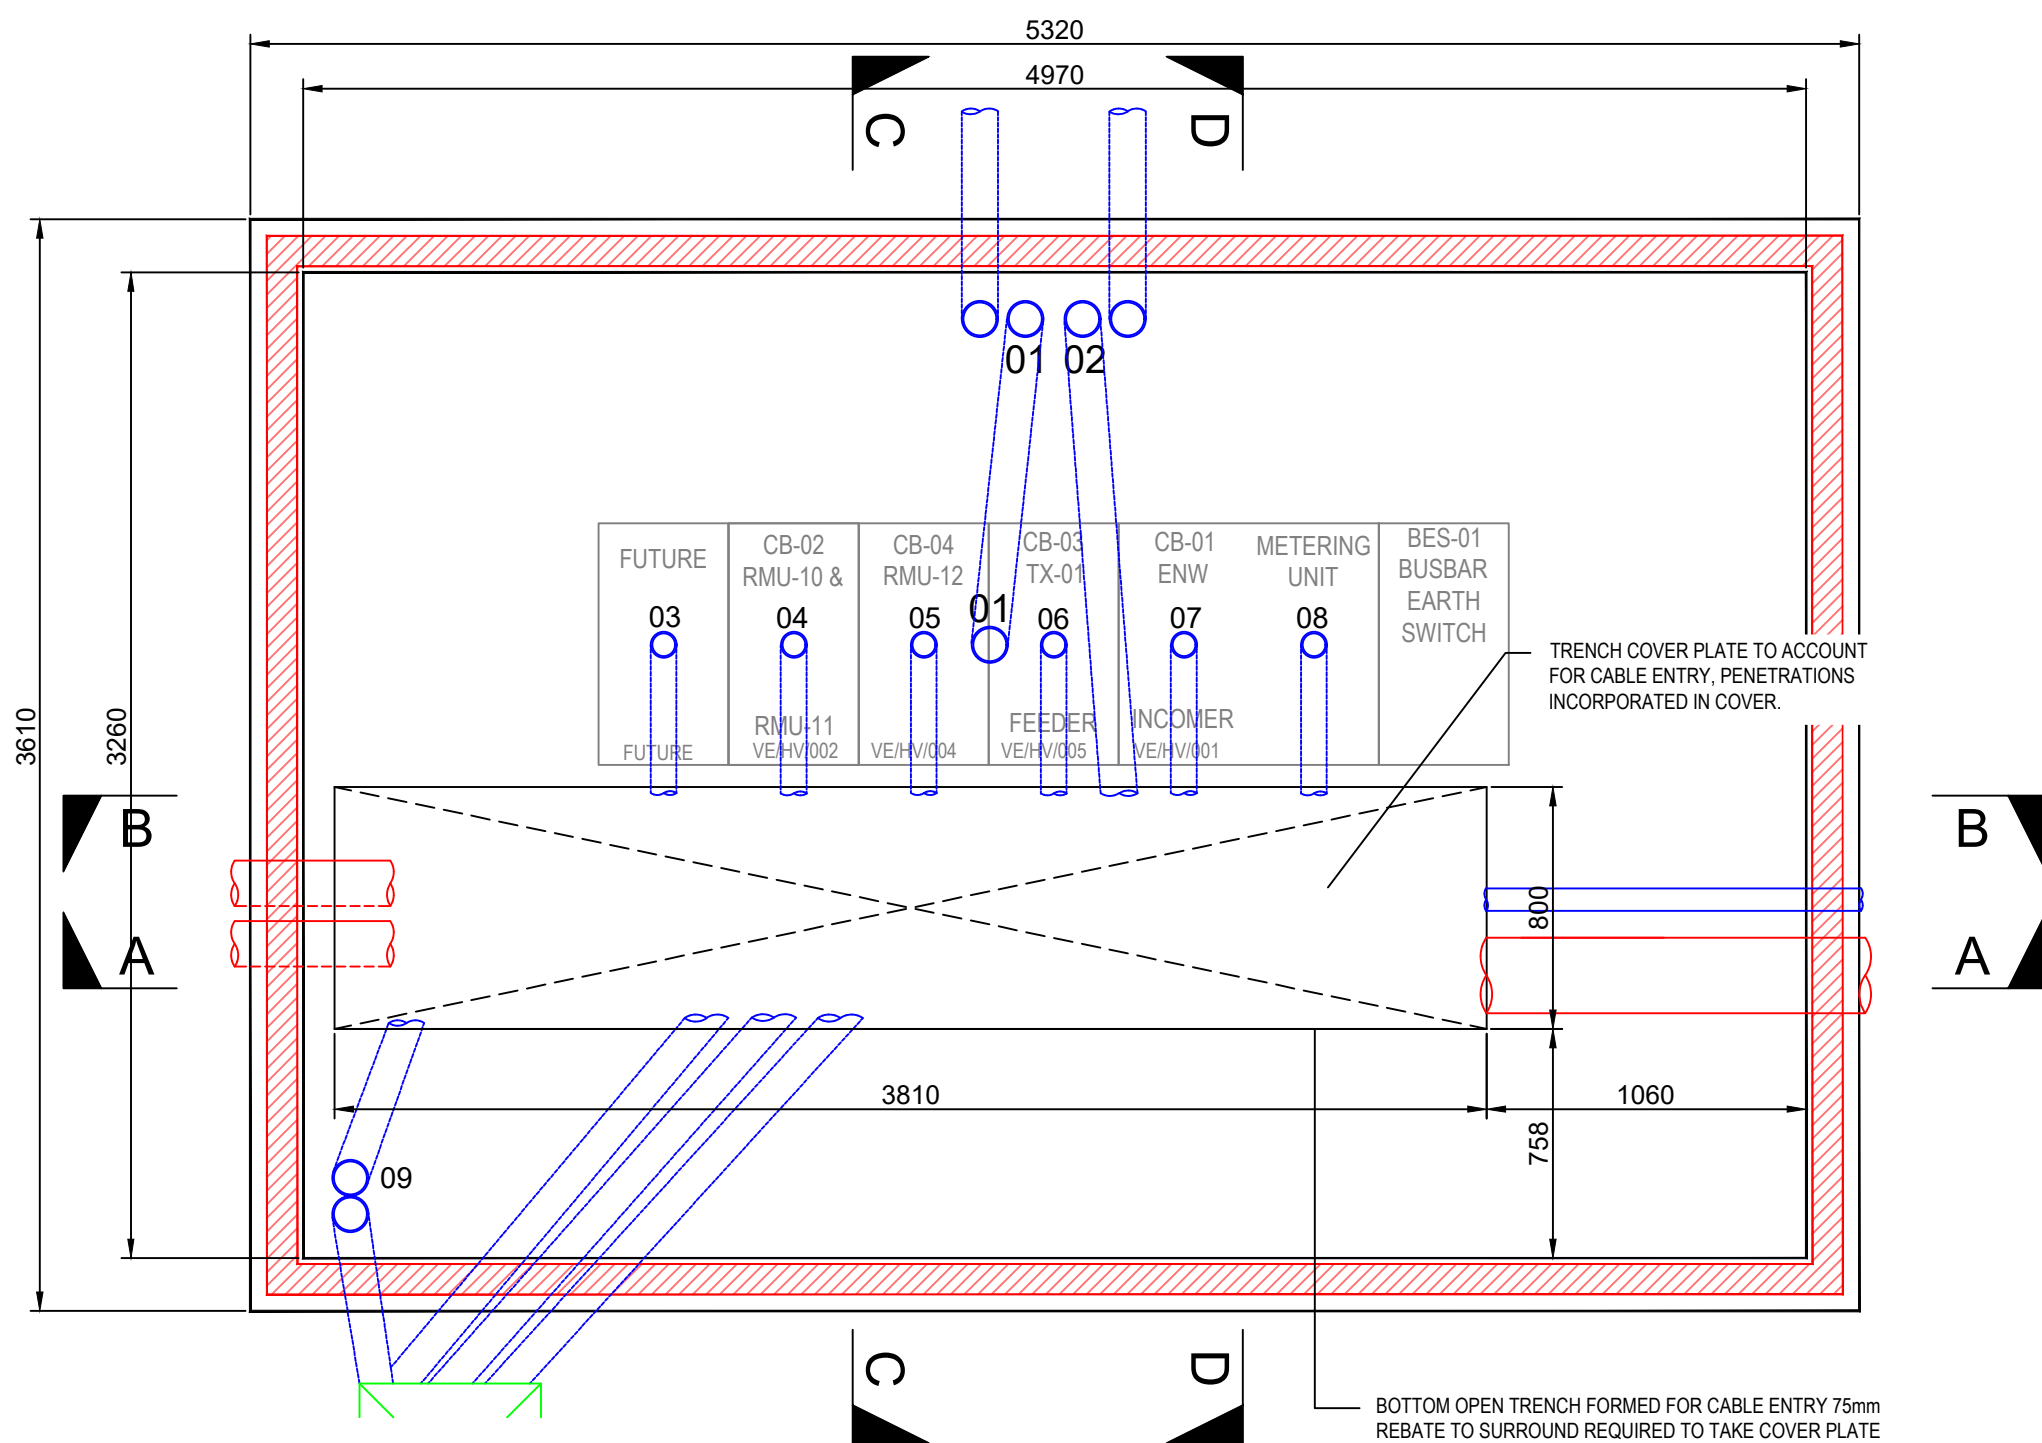


HV SWITCHGEAR BASE LAYOUT
SCALE 1:20

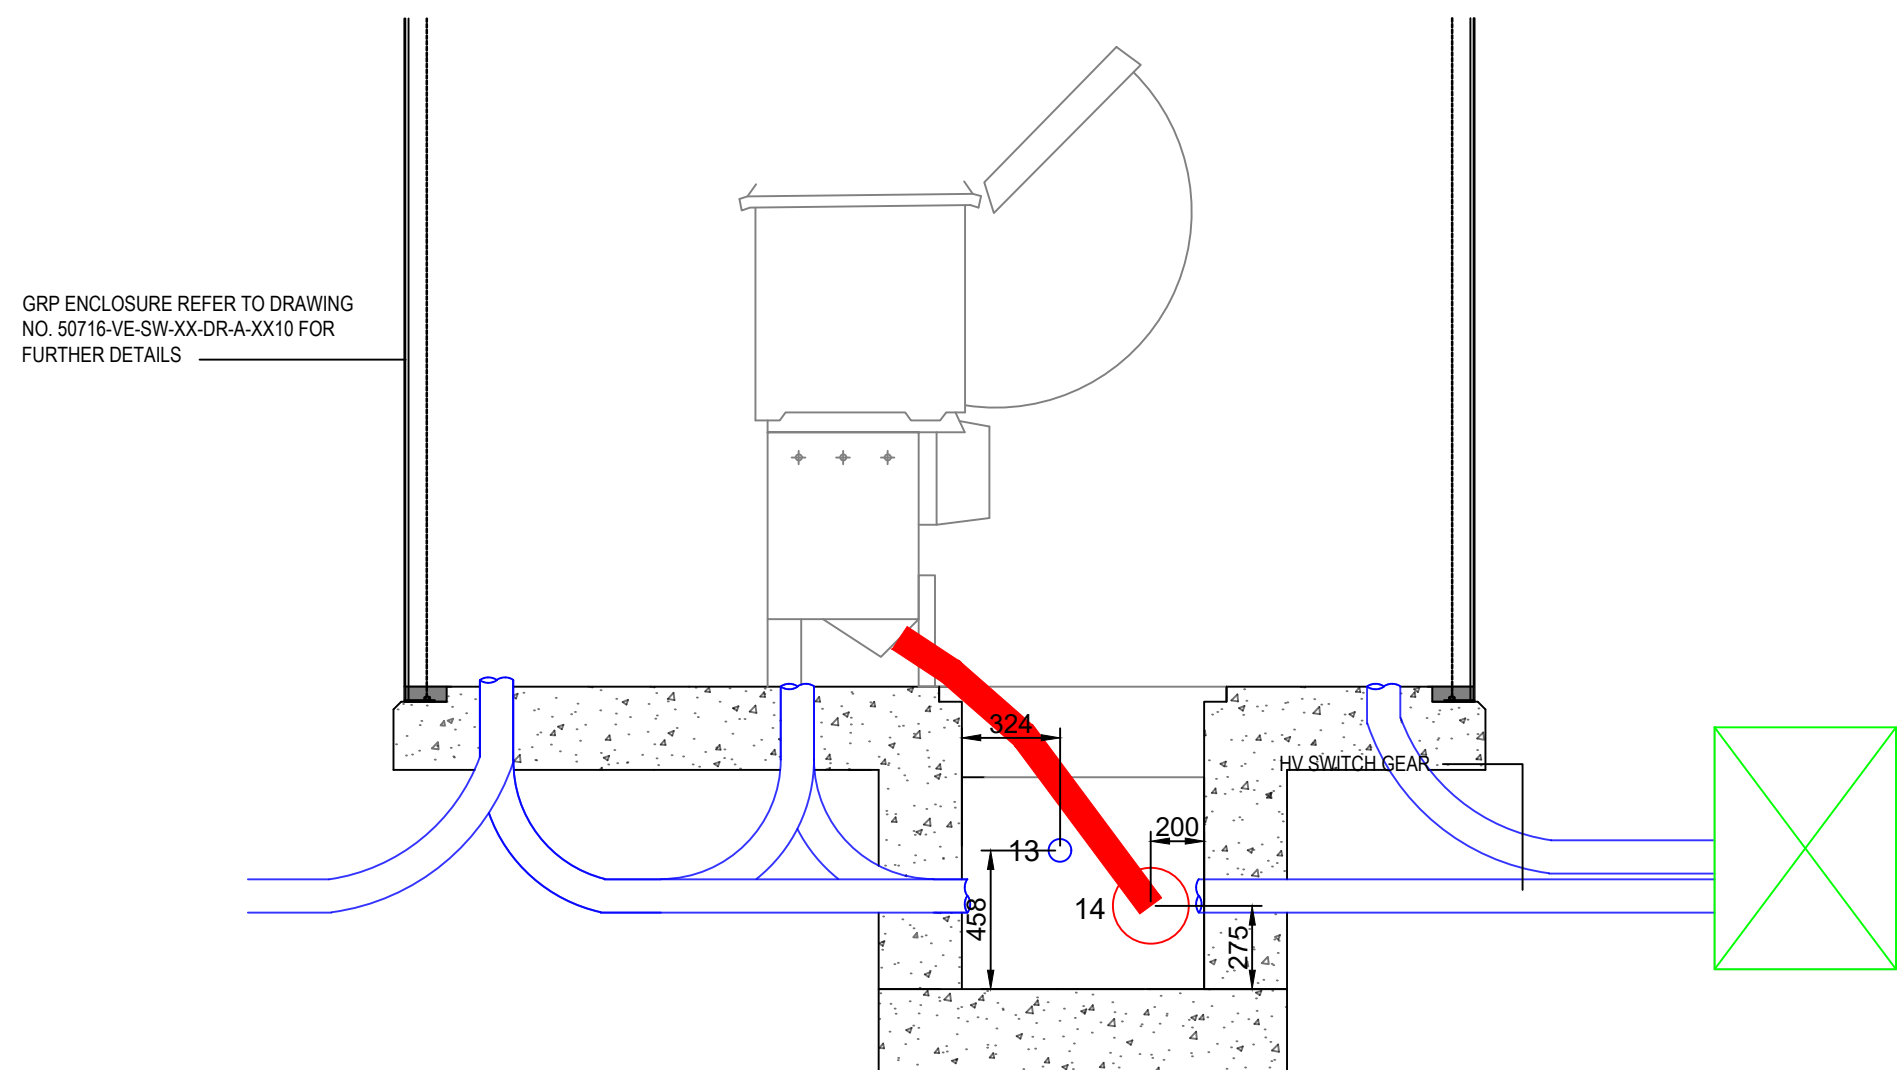


SECTION C-C
SCALE 1:25

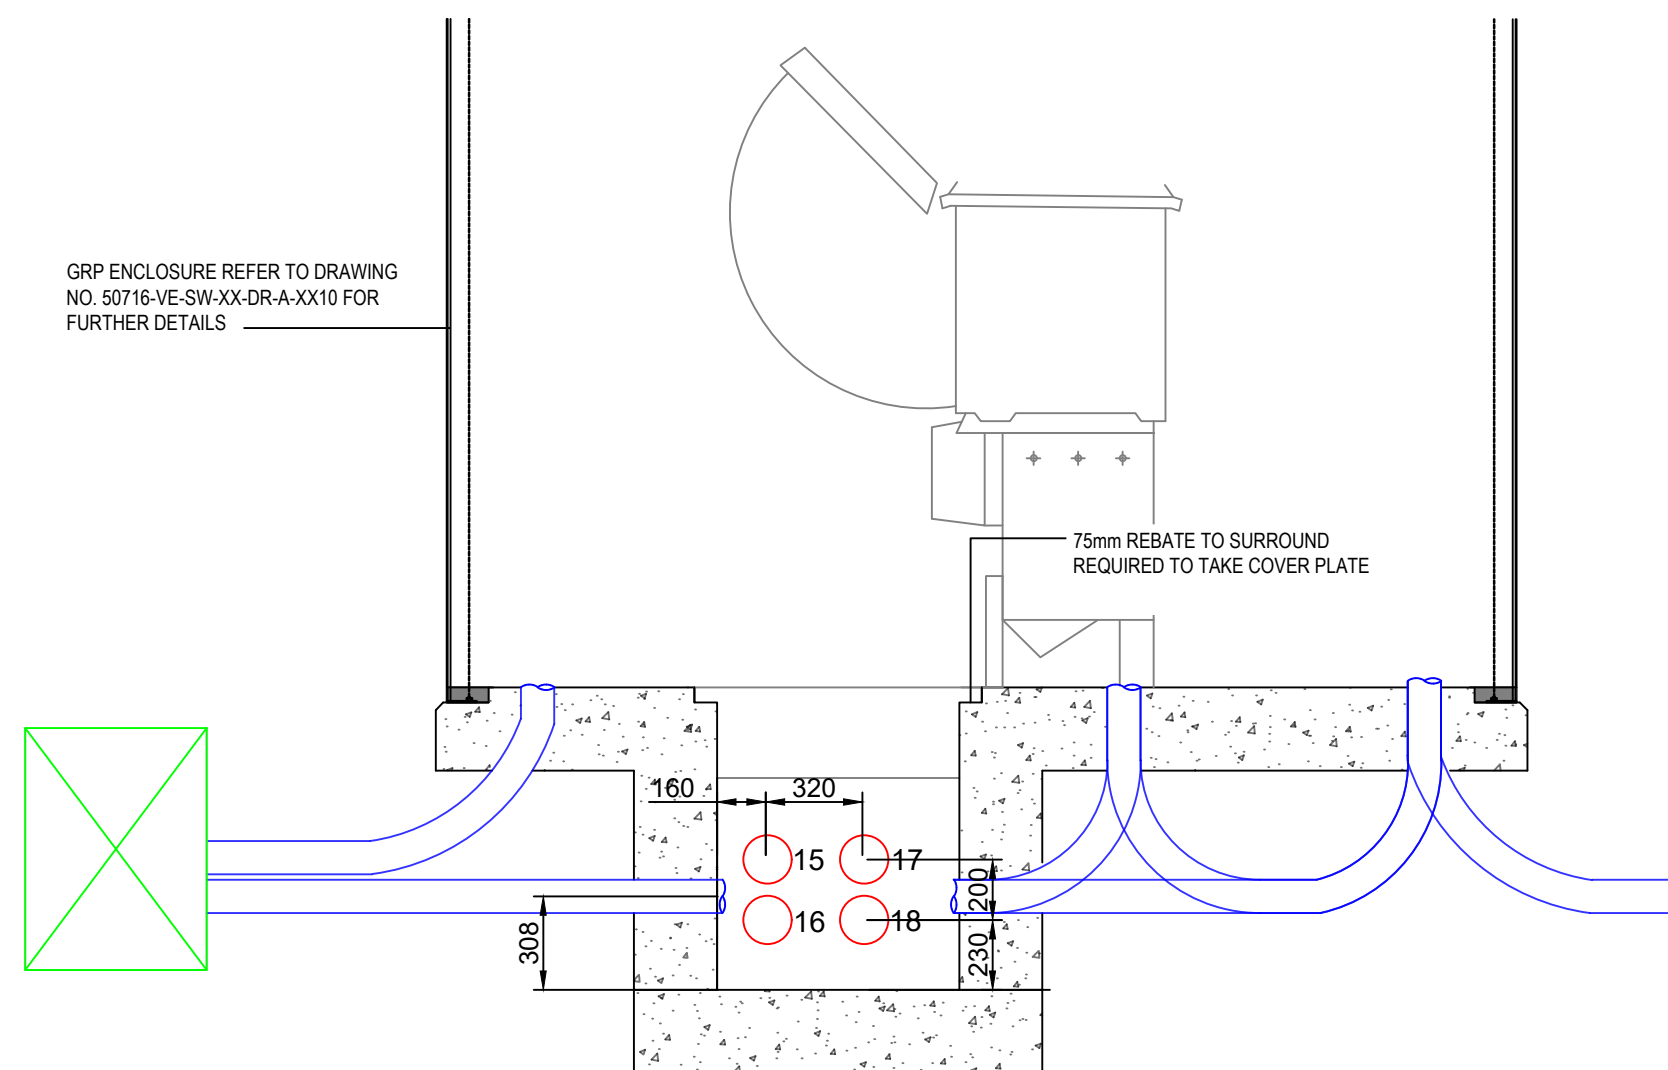


SECTION D-D
SCALE 1:25

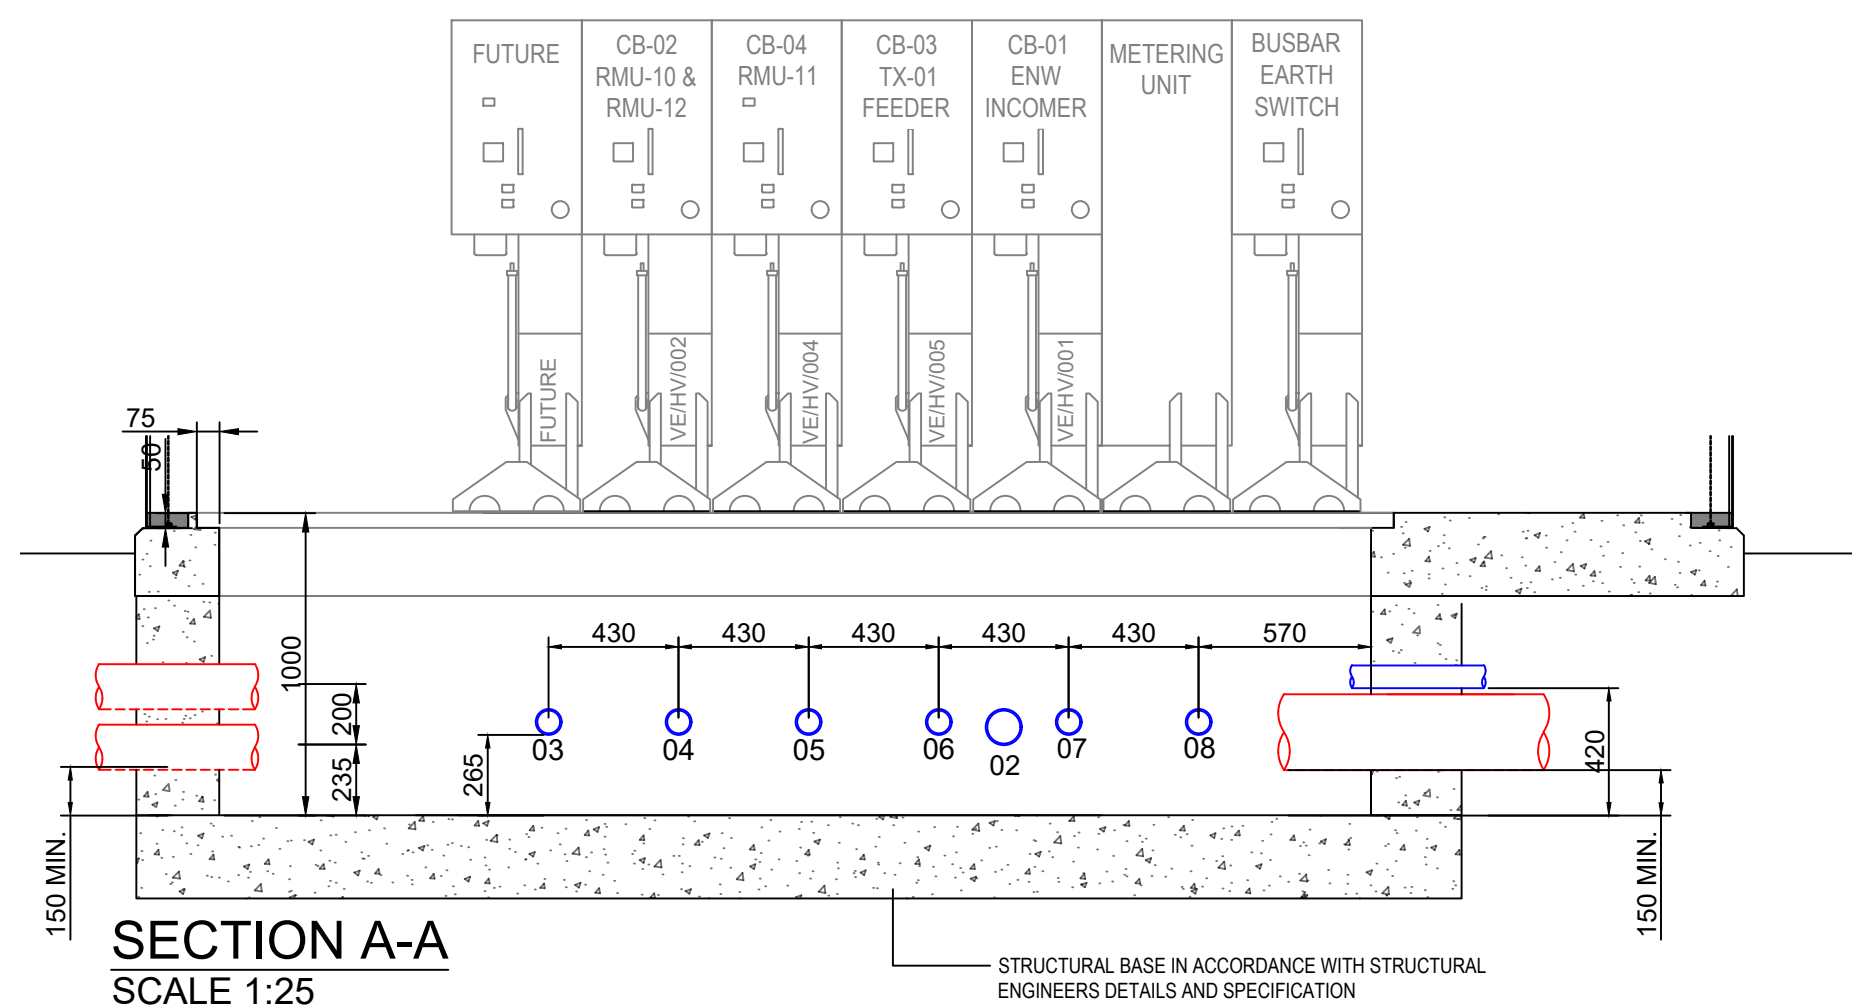

SECTION A-A
SCALE 1:25

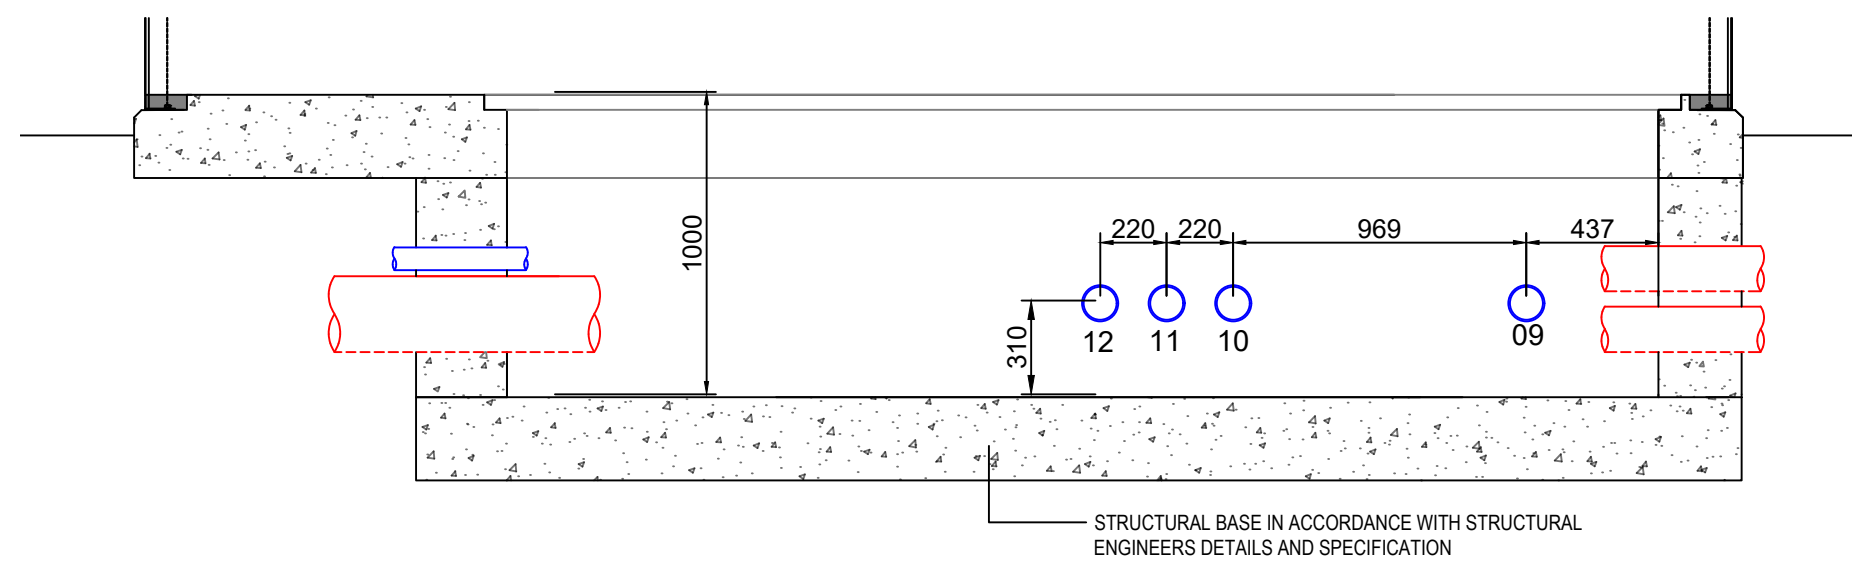

SECTION B-B
SCALE 1:25

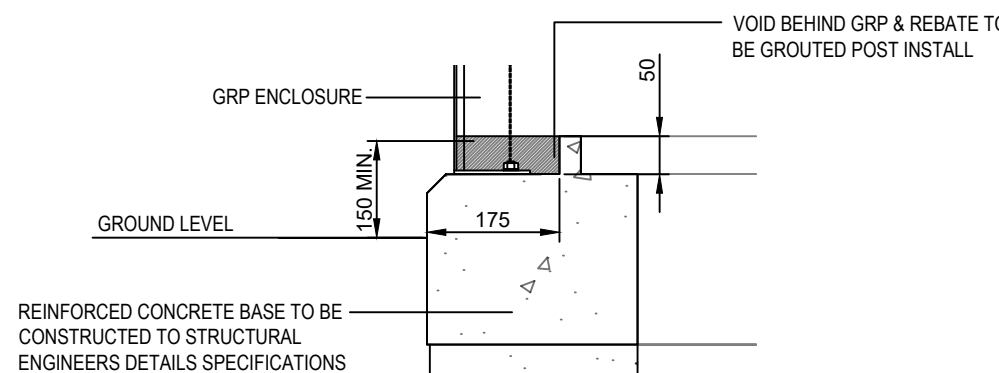

TYPICAL REBATE DETAIL
SCALE 1:10

GENERAL NOTES:

ALL BUILDERS WORK IS TO BE CONSTRUCTED IN ACCORDANCE WITH THE CURRENT AND RELEVANT BUILDING REGULATIONS AND BRITISH STANDARDS. MANUFACTURERS INSTALLATION/ GUIDANCE NOTES ARE TO BE READ IN CONJUNCTION TO TASK BEING CARRIED OUT.

ALL DIMENSIONS ON DRAWING ARE IN MILLIMETERS UNLESS OTHERWISE STATED. ALL LEVELS ON DRAWING ARE IN METERS UNLESS OTHERWISE STATED.

THE CONTRACTOR SHALL BE RESPONSIBLE FOR THE ACCURACY OF ALL DIMENSIONS AND FOR THE CORRECT SETTING OUT OF WORK CARRIED OUT ON SITE.


THIS DRAWING IS TO BE READ IN CONJUNCTION WITH ALL RELEVANT ARCHITECTURAL, STRUCTURAL AND MECHANICAL DRAWINGS/ SPECIFICATIONS ISSUED.

ALL MATERIALS AND WORKMANSHIP SHALL BE IN ACCORDANCE WITH THE RELEVANT SPECIFICATIONS AND BRITISH STANDARDS

THE CONTRACTOR SHALL ENSURE THE STABILITY OF THE BUILDING AND ANY ADJOINING STRUCTURES IS MAINTAINED AT ALL STAGES OF CONSTRUCTION. THE CONTRACTOR SHALL DESIGN, INSTALL AND MAINTAIN ANY NECESSARY TEMPORARY WORKS.

CONTRACTOR TO PROVIDE METHOD STATEMENTS AND RISK ASSESSMENTS TO THE ENGINEER AND PLANNING SUPERVISOR A MINIMUM OF 14 DAYS BEFORE THE WORKS COMMENCE

DUCT ID	INTERNAL DIAMETER	COLOUR
1	100	BLACK
2	100	BLACK
3	60	BLACK
4	60	BLACK
5	60	BLACK
6	60	BLACK
7	60	BLACK
8	60	BLACK
9	60	BLACK
10	100	BLACK
11	100	BLACK
12	100	BLACK
13	60	BLACK
14	250	RED
15	150	RED
16	150	RED
17	150	RED
18	150	RED

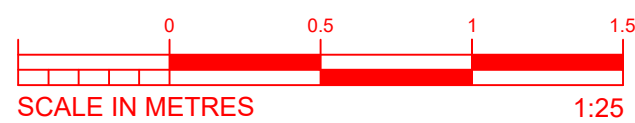

ISSUED FOR
CONSTRUCTION

C1	26.06.23	ISSUED FOR CONSTRUCTION	WE	RJR	BMc
P6	13.06.23	UPDATED IN LINE WITH CIVIL ENGINEERS DESIGN	WE	RJR	BMc
P5	07.06.23	UPDATED TO SUIT ELECTRICAL LAYOUT	WE	RJR	BMc
P4	11.05.23	UPDATED TO SUIT CLIENTS COMMENTS	RJR	BMc	DC
P3	27.04.23	UPDATED TO SUIT NEW GRP SIZING	WE	RJR	BMc
P2	28.03.23	UPDATED FOLLOWING COMMENTS	WE	RJR	BMc
P1	15.03.23	ISSUE FOR INFORMATION	WE	RJR	BMc
REV	DATE	DESCRIPTION	DRW	CHKD	APP

**VITAL
ENERGI**

Vital Energi, Century House, Roman Road, Blackburn, Lancashire, BB1 2LD
Tel: +44 (0)1254 296 000 Fax: +44 (0)1254 296 040

Project: CHAMBER HOUSE				
Title: HV SWITCHGEAR BASE LAYOUT AND SECTION				
DATE	07.06.2023	SCALE	N.T.S	SHEET
ISSUED FOR CONSTRUCTION				Status: A
50716-VE-SW-XX-DR-A-XX11				Rev: C1