


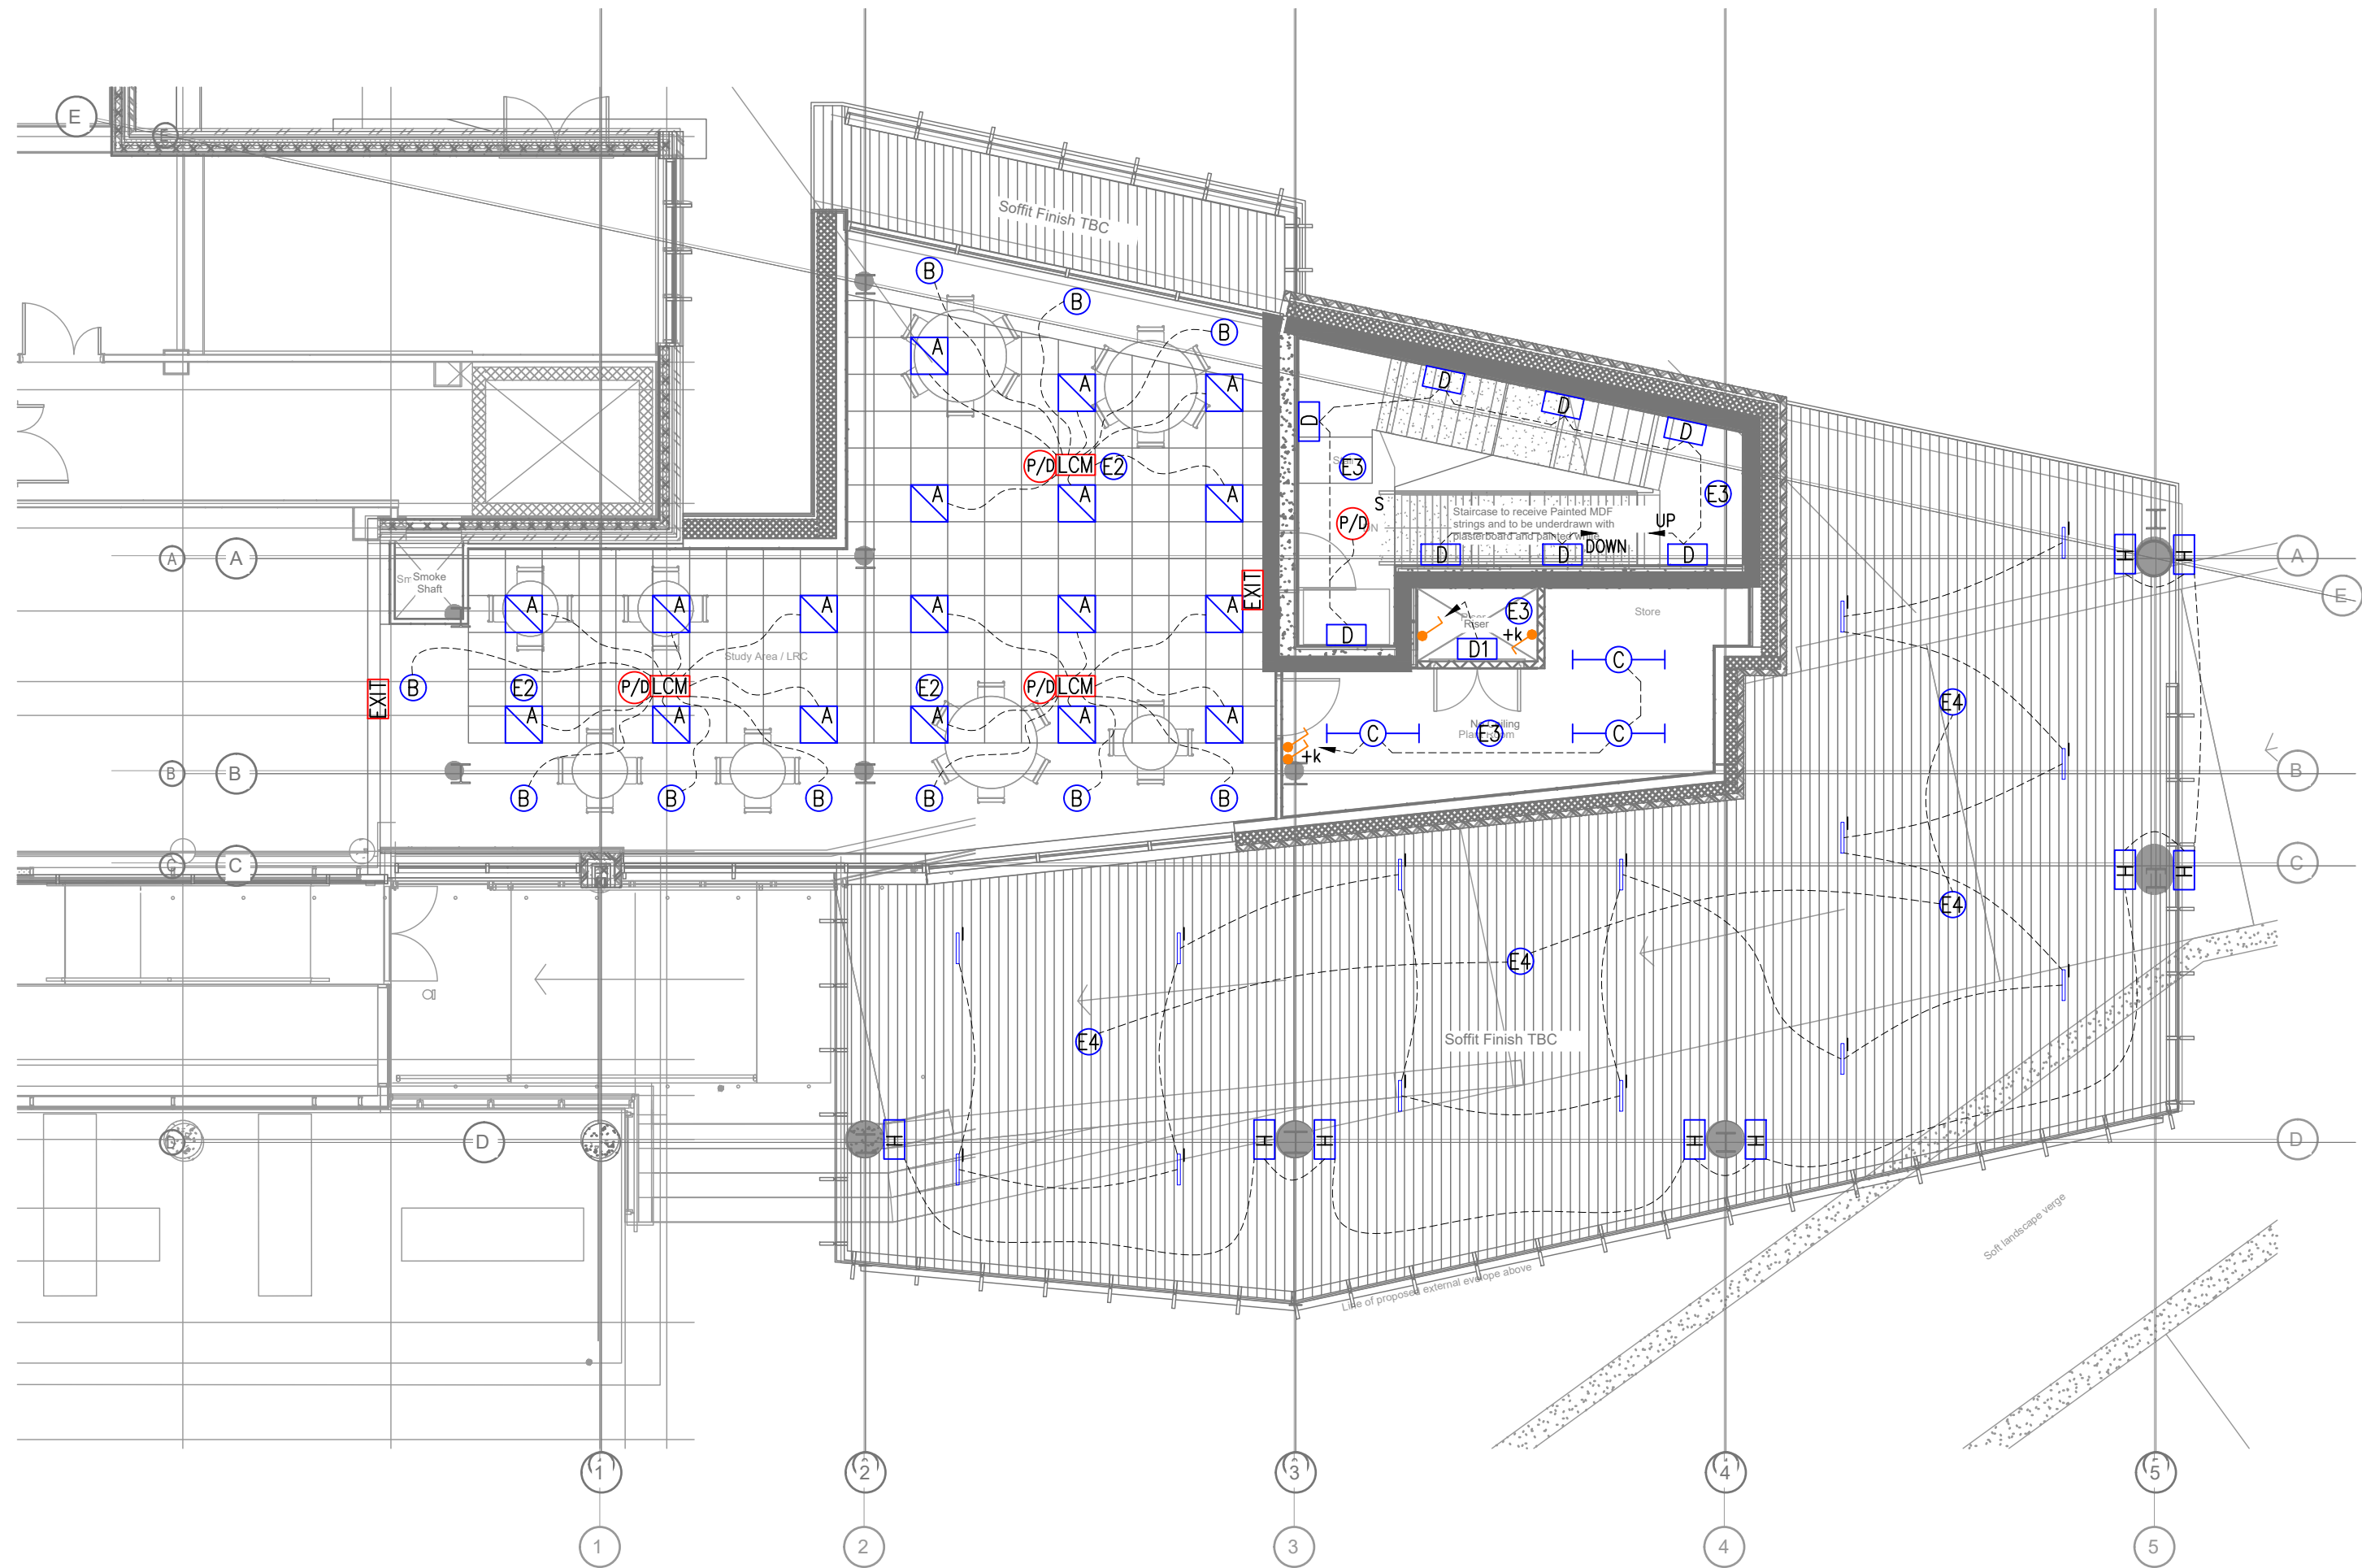

BASE DRAWINGS

USED IN COMPILATION OF THIS DRG:

- ROCH01-ABW-ZZ-00-DR-A-2101-PR2 - Detailed GA Plan - Level 0 (G)
- ROCH01-ABW-ZZ-00-DR-A-2101-PR2 - Detailed GA Plan - Level 0 (G)

NOTES

-	27/06/23	TENDER	REJ	REJ	SJB
Rev	Date	Details	Made	Chk'd	App

Status:

TENDER

Architect:

ABW ARCHITECTS

Client:

ROCHDALE SIXTH FORM COLLEGE

Project:

PROPOSED EXTENSION

Title:

GROUND FLOOR LEVEL LIGHTING & EMERGENCY LIGHTING LAYOUT



Rosiben,
11th Floor, 3 Piccadilly Place,
Manchester, M1 3BN

T: +44 (0) 7743018657
E: contact@rosiben.com

Eng:	REJ	CAD:	DG
Chk'd:	REJ	App'd:	SJB
Date	27/06/2023	Scale:	1:100@A2

Drawing No:	Rev:
RSFC-RSB-EX-00-DR-E-6300	-