


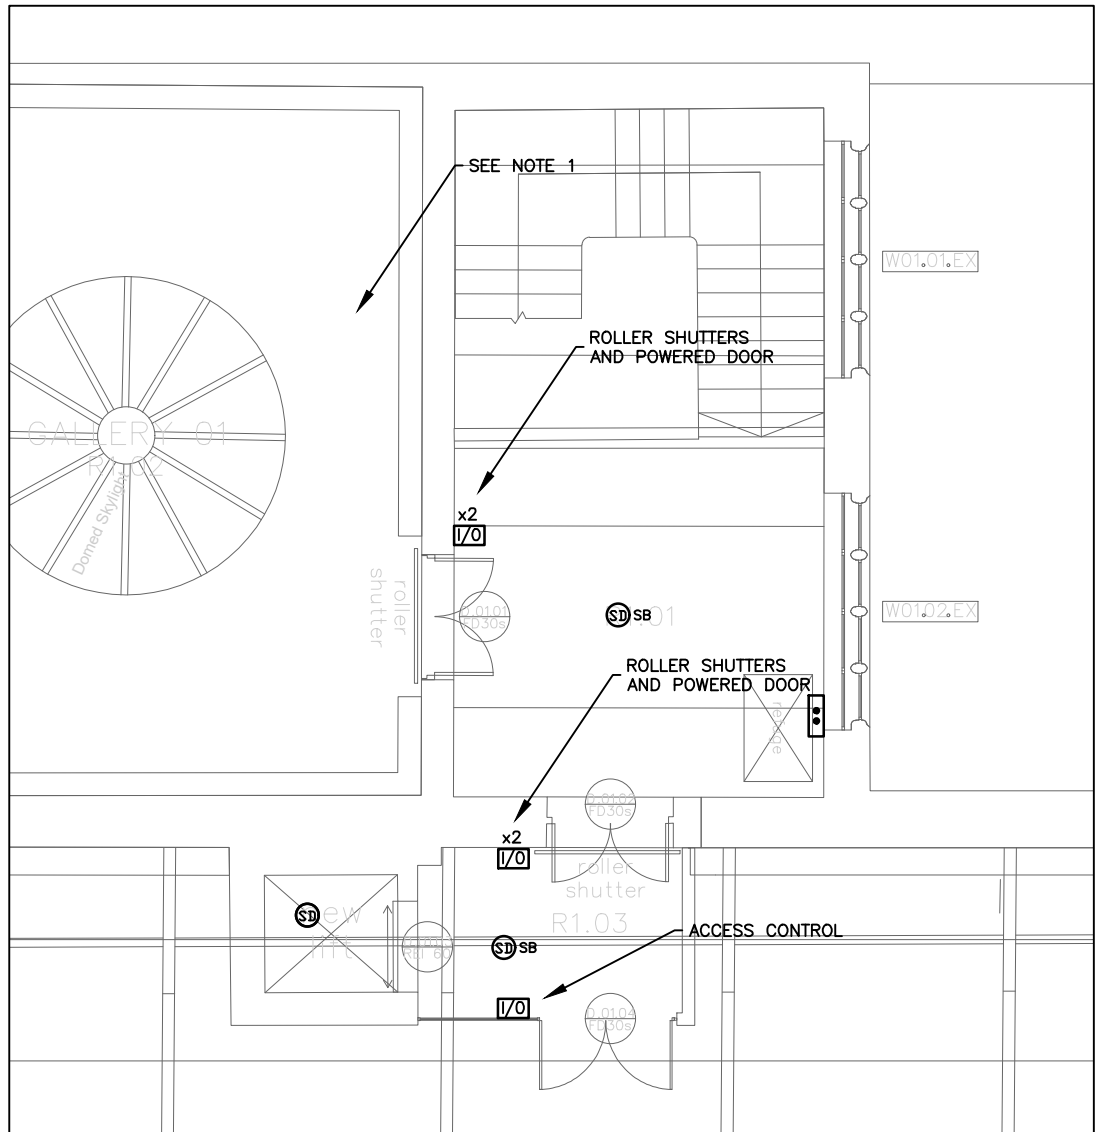


FIRST FLOOR FIRE ALARM

NOTE 1

EXISTING FIRST FLOOR FIRE ALARM DETECTORS AND ASSOCIATED WIRING TO REMAIN WITH EXISTING LOOP TO BE WIRED BACK TO FIRE ALARM PANEL OR CONNECTED ON TO EXISTING IF NOT ON SEPARATE LOOP.

FIRE ALARM SPECIALIST TO ALLOW FOR NEW DETECTORS THROUGHOUT THE BUILDING IF EXISTING FIRST FLOOR DETECTORS NOT FOUND COMPATABLE OR SUITABLE FOR NEW INSTALLATION

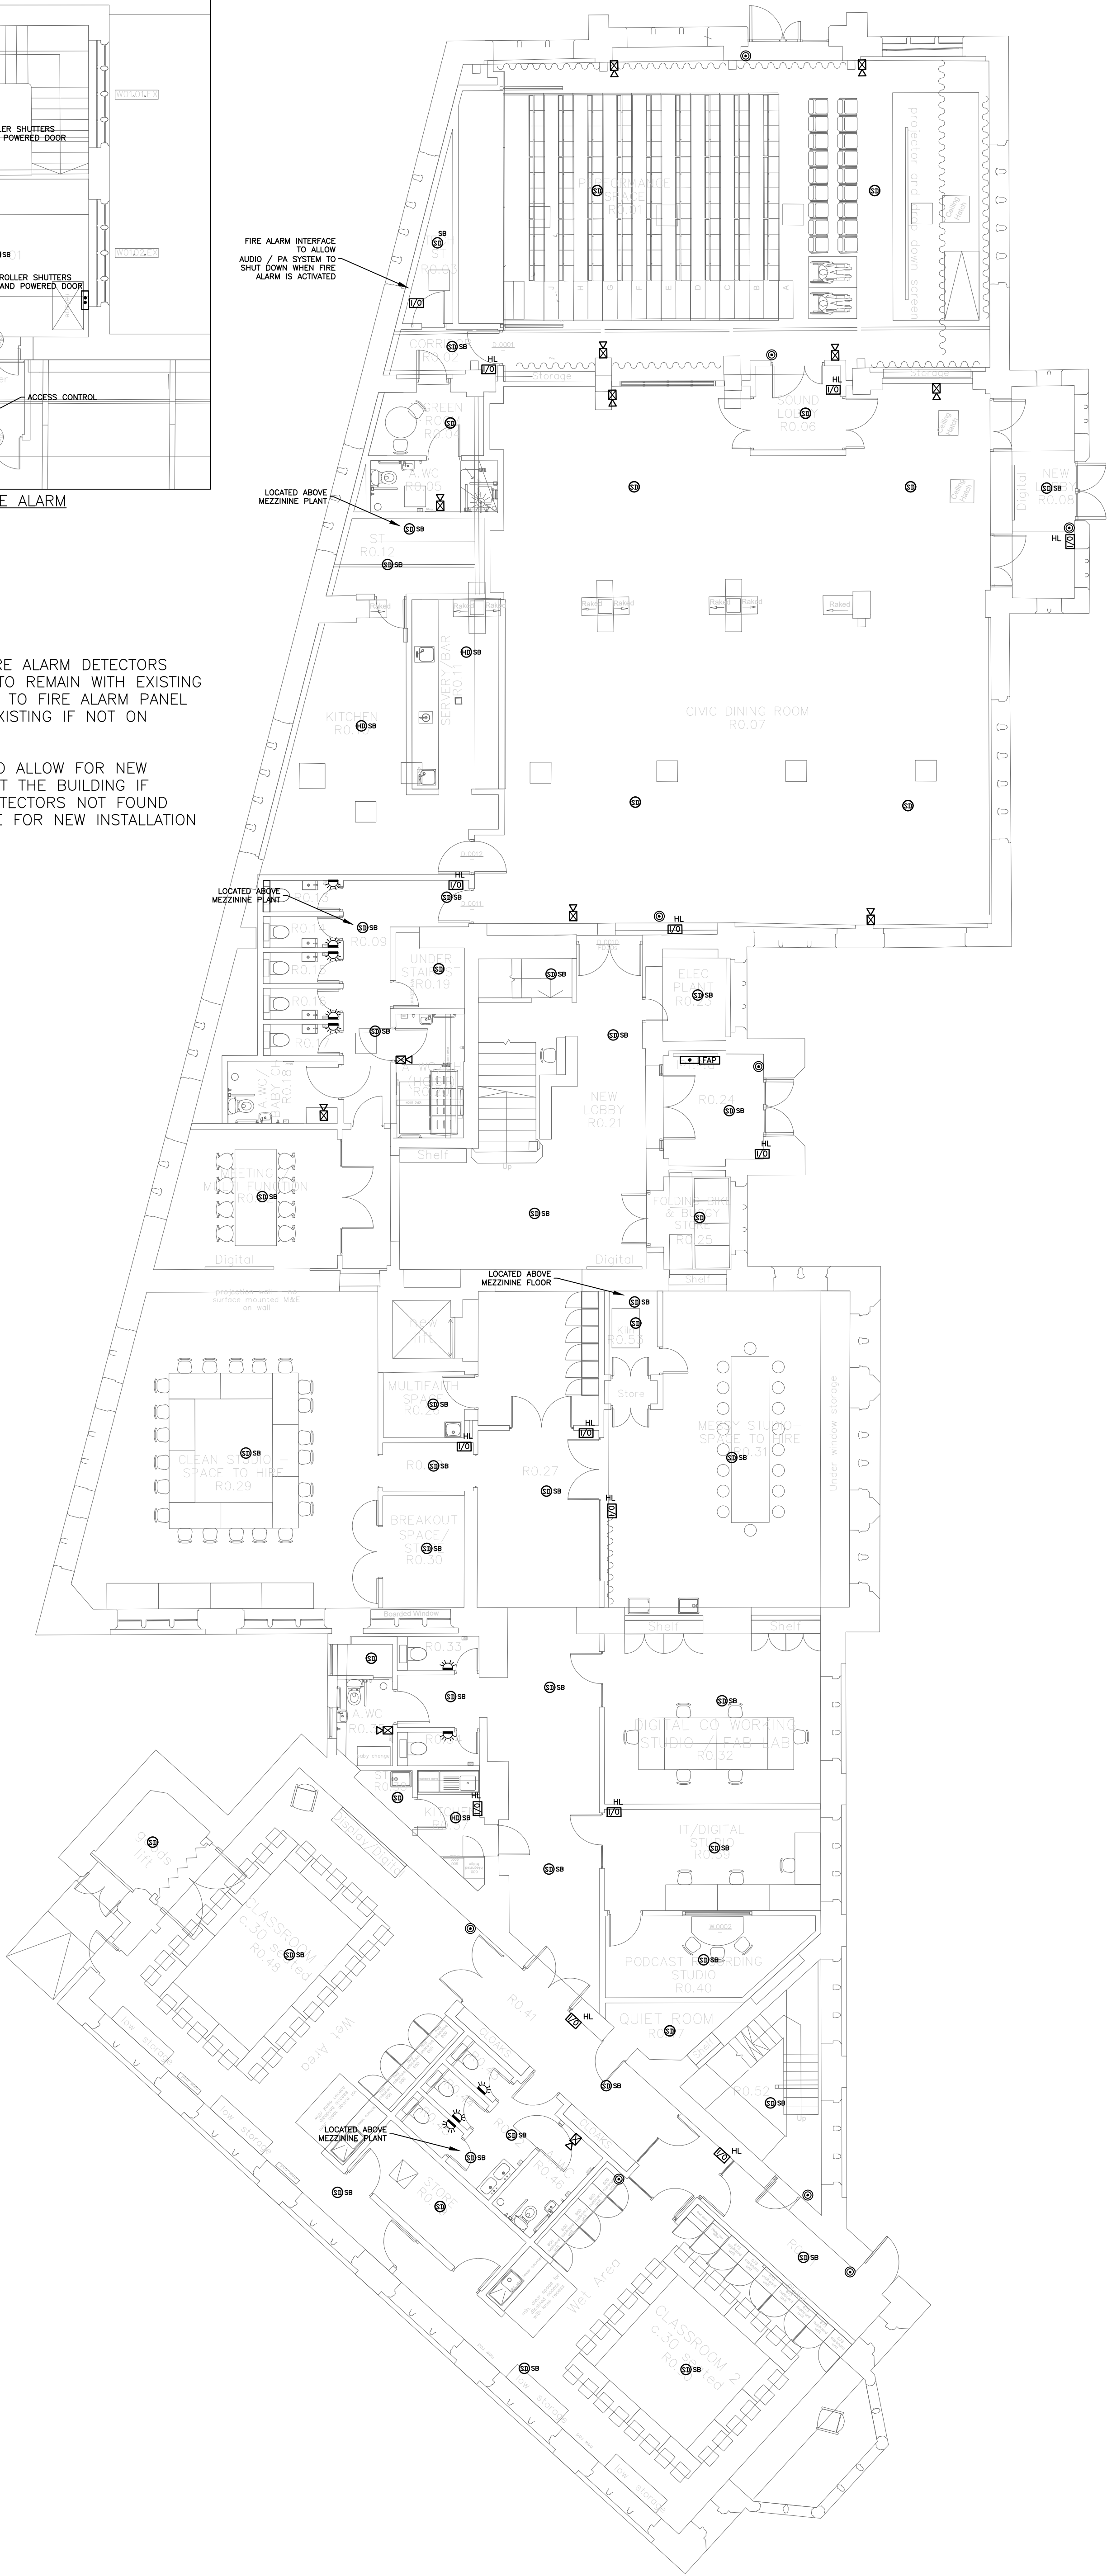

ALL DIMENSIONS ARE IN MILLIMETRES UNLESS OTHERWISE INDICATED.

DO NOT SCALE FROM THIS DRAWING. IF IN DOUBT ASK.

THIS DRAWING SHALL BE READ IN CONJUNCTION WITH THE PROJECT SPECIFICATION AND ALL OTHER PROJECT DOCUMENTATION.

FIRE ALARM AND DETECTION NOTES

- THIS DRAWING IS A DESIGN DRAWING ONLY.
- THE ELECTRICAL SUB-CONTRACTOR SHALL PREPARE HIS OWN CONSTRUCTION/WORKING DRAWINGS BASED UPON THIS AND OTHER ARCHITECTURAL AND STRUCTURAL ENGINEERING DRAWINGS (AVAILABLE FROM OTHERS).
- ALL PLANT AND EQUIPMENT SHALL BE INSTALLED IN ACCORDANCE WITH THE MANUFACTURERS INSTRUCTIONS.
- ALL INSTALLATIONS SHALL COMPLY WITH THE REQUIREMENTS OF BS7671 (IET WIRING REGULATIONS).
- ALL INSTALLATIONS SHALL COMPLY WITH THE REQUIREMENTS OF BS5839 AND THE INSTALLING CONTRACTOR SHALL BE BAFE REGISTERED UNDER SCHEME SP203-1. INSTALLING CONTRACTOR TO BE LPCB/BRE LPS 1014 CERTIFIED (FIRE DETECTION & ALARM SYSTEMS) & BAFE SP201 (LPS 1014) CERTIFIED.
- INSTALLATION TO BE CARRIED OUT USING RED FP200 ENHANCED CABLING AS A FLUSH INSTALLATION. (120 Min)
- INCLUDE FOR LOOP ISOLATORS BETWEEN EACH ZONE/SUB COMPARTMENT EVERY 20 DEVICES.
- LED INDICATORS TO BE MOUNTED ON CEILING TILES BELOW DETECTOR IN VOID.

LEGEND

- FIRE ALARM PANEL
- SMOKE DETECTOR
- SMOKE DETECTOR / SOUNDER BASE
- HEAT DETECTOR
- HEAT DETECTOR / SOUNDER BASE
- SMOKE DETECTOR / SOUNDER BASE BEACON
- MANUAL CALL POINT
- WALL MOUNTED SOUNDER / BEACON
- XENON BEACON WALL MOUNTED
- FIRE ALARM INTERFACE UNIT
- VOID DETECTION
- INDICATOR PLATE
- DOOR ACCESS CONTROLLER EXISTING TO REMAIN
- CV
- DISABLED REFUSE MAIN PANEL
- DISABLED REFUSE CALL POINT

T2	09.11.2023	TENDER ISSUE
T1	29.09.2023	TENDER ISSUE
P1	17.08.2023	STAGE 3 ISSUE
Revision	Date	Description

Client & Site

YOUR TRUST
TOUCHSTONES
ROCHDALE

Title

PROPOSED FIRE ALARM LAYOUT

GROUND FLOOR



Steven A. Hunt & Associates

Hangar 9, De Havilland Drive, Liverpool L24 8RN

T 0151 427 8009

W www.stevenhunt.com E info@stevenhunt.com

Scale: 1:100 Size: A1 Drawn: JH Chkd: SH

Project	Origin	Zone	Level	File Type	Role	Number	Suitability	Rev:
4025-SHA	XX-00	DR	E	3000	S2	T2		

TENDER

CLICK ME