


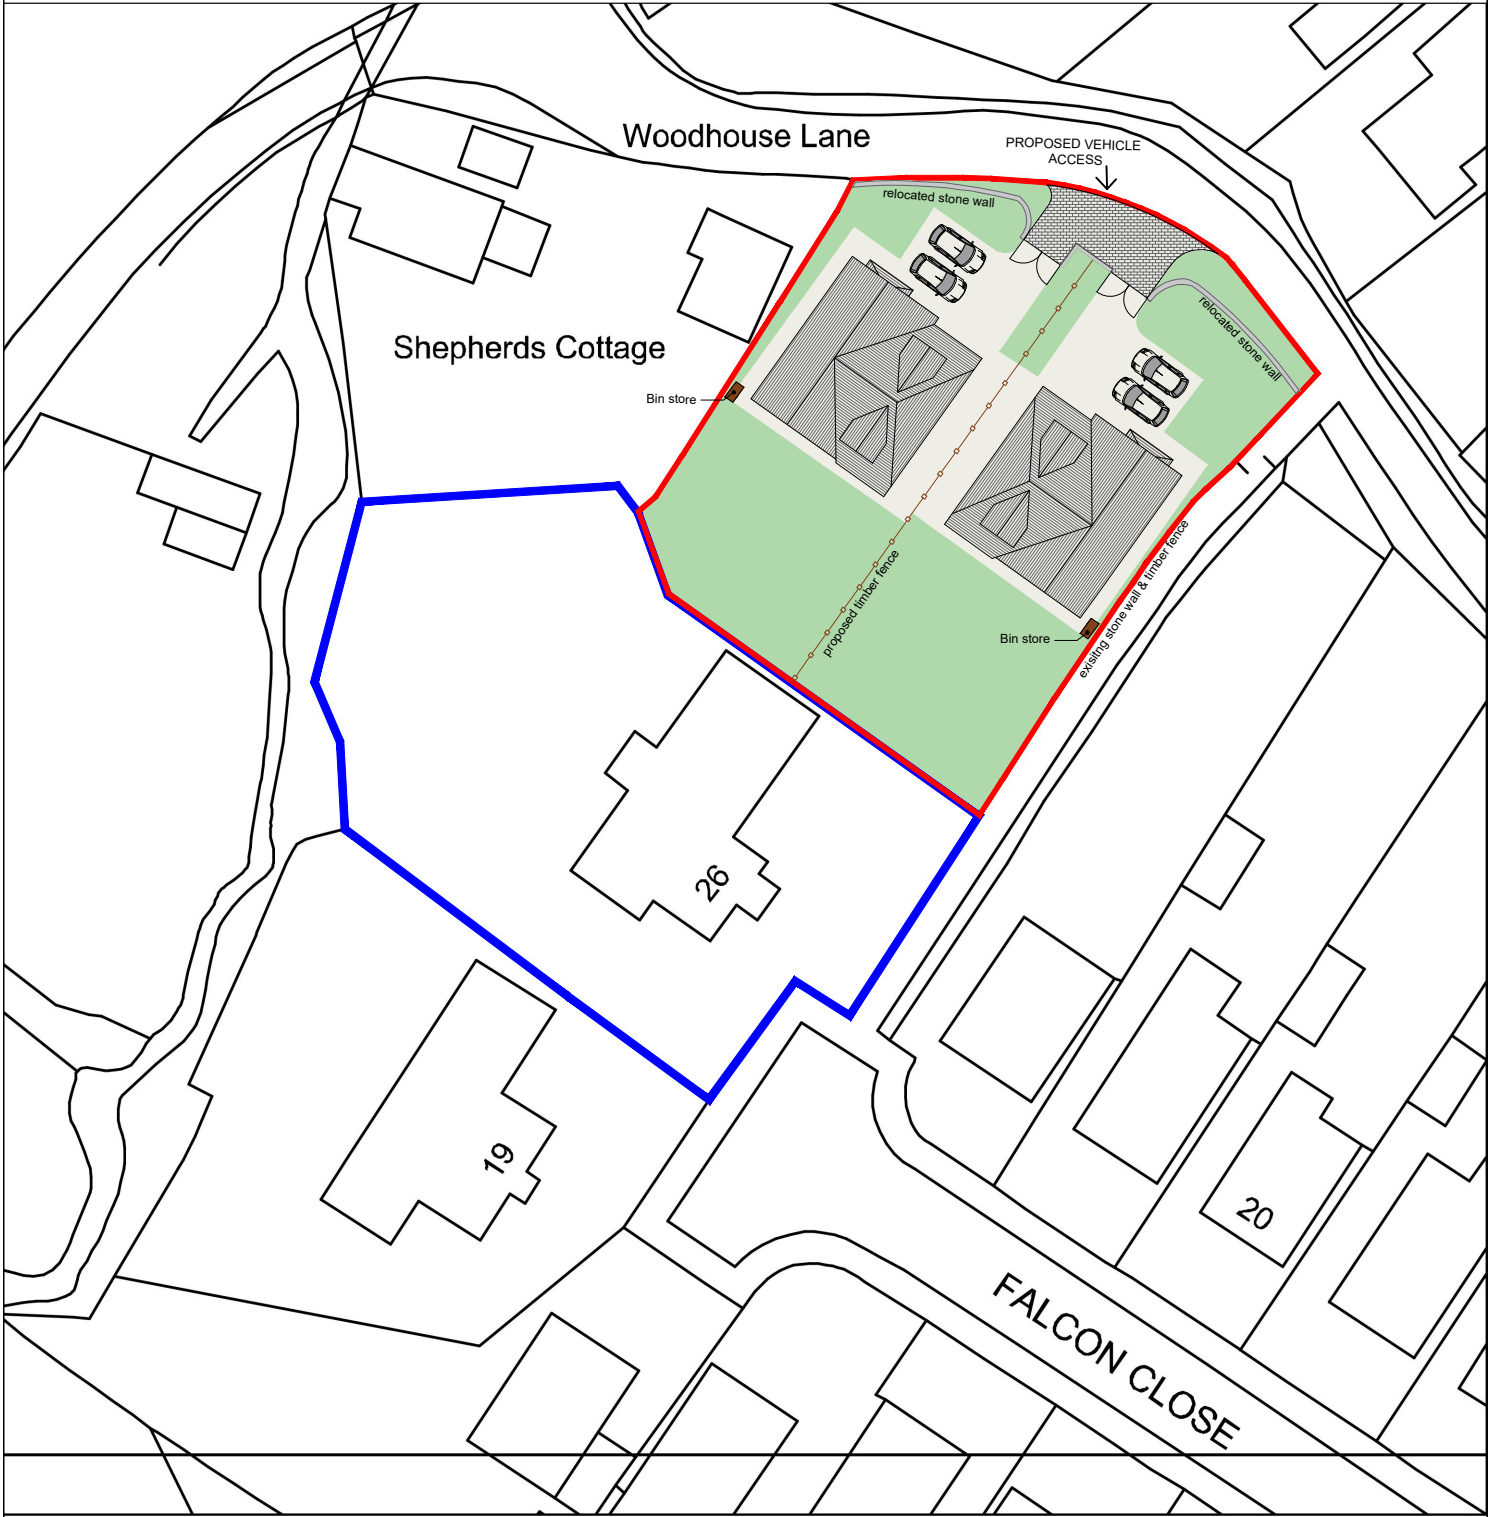

**northern
planners**
A trading name of Energyline Ltd

tel: 01423 799954
www.northernplanners.co.uk

Project Title. Falcon Close, Rochdale			
Title. Proposed Site Plan		Date. April 2024	
Drawing No. 24NP504/01/003		Client.	
Scale. 1:500 @ A4	Format. PDF	Sheet. 1	Rev. A