


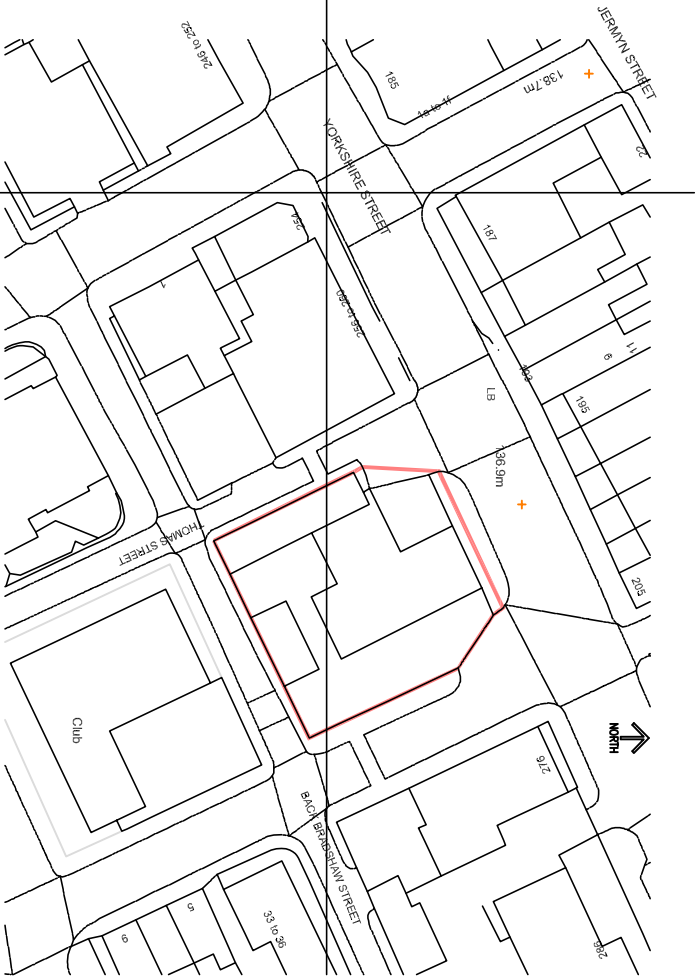

Mapping contents © Crown copyright and database rights 2022

- SITE BOUNDARY TOTAL AREA = 800 m²
- PROPOSED SURFACE WATER DRAINAGE
- PROPOSED SURFACE WATER MANHOLE
- GULLY
- FC FLOW CONTROL MANHOLE
- CP CATCH PIT
- PROPOSED Foul WATER DRAINAGE
- PROPOSED Foul WATER MANHOLE
- FS FORECOURT SEPARATOR
- PROPOSED COMBINED DRAINAGE
- PROPOSED COMBINED DRAINAGE MANHOLE
- EXISTING SEWER

RWP/SPV POSITIONS ARE INDICATIVE ONLY. EXACT POSITIONS TO BE CONFIRMED BY THE ARCHITECT - DRAINAGE RUN TO BE AMENDED TO SUIT.
INVERT LEVELS OF ALL EXISTING MANHOLES TO BE CONNECTED TO, TO BE CONFIRMED BEFORE DRAINAGE CONSTRUCTION.
LINE AND LEVEL OF EXISTING SEWERS TO BE CONFIRMED ON SITE PRIOR TO WORKS COMMENCING.
PIPE DIAMETERS AND GRADIENTS TO BE CONFIRMED AT DETAIL DESIGN STAGE.

Rev B 24.11.23 Final author number added
Rev A 29.08.23 Initial draft

Amendments

ip Ian Pawson Ltd, 26 Essex Street, Barnsley, Yorkshire, BB10 5DT
Tel: 01222 814148
Email: info@ianpawson.com
www.ianpawson.com
Technologist & Building Consultant

Client: A Y & Y PATEL

Project: SHELL SERVICE STATION
YORKSHIRE STREET, ROCHDALE OL16 2DR
SITE PLAN PROPOSED DRAINAGE SCHEME

Scale: 1:100 @ A1 Drawing No. Am.
By: I PAWSON
Date: AUG 2023
Job No. 2722 / 104 B

