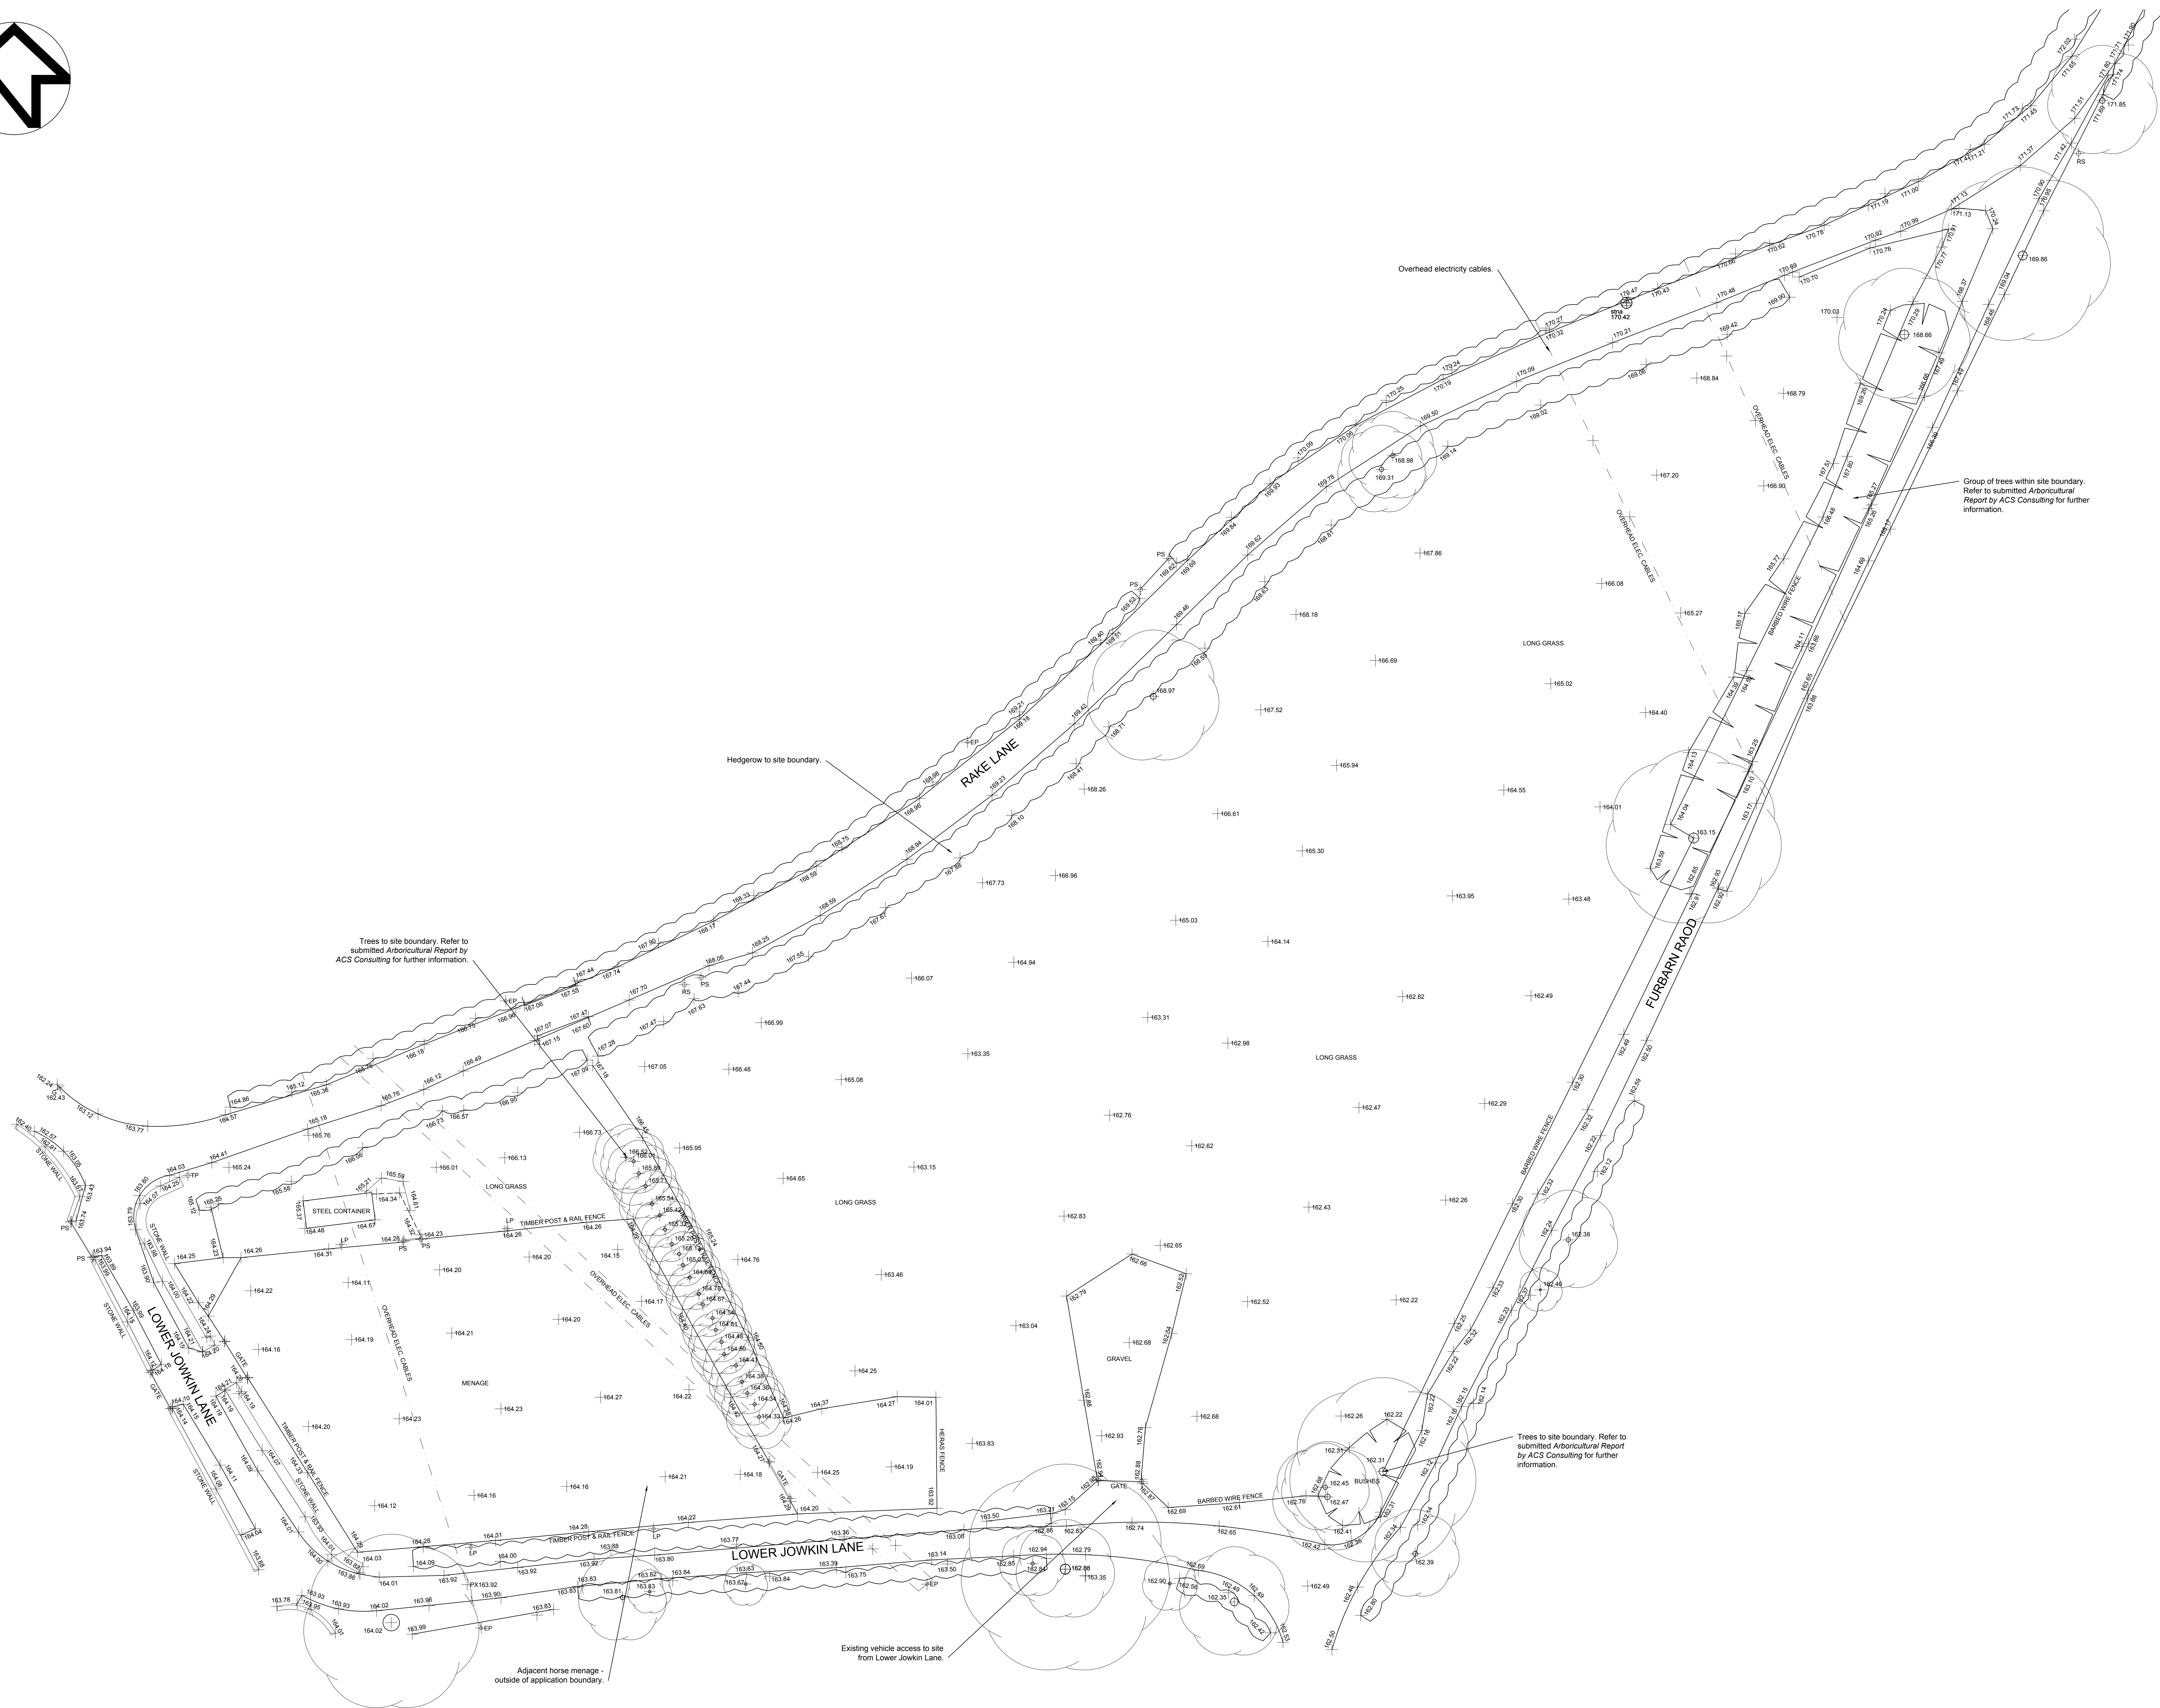
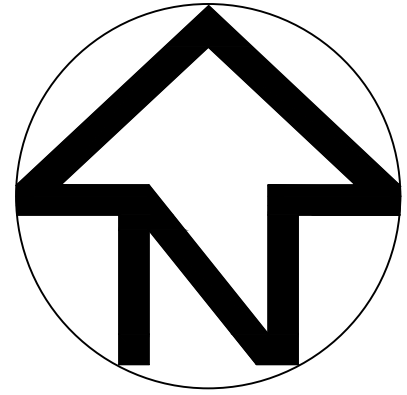


[illegible]

**PYE
DESIGN
ARCHITECTS**
RIBA Chartered Practice

29 Market Street
Hindley
Wigan
WN2 3AE

www.pyedesign.co.uk

LOCATION
CLAY LANE / FURBARN ROAD,
NORDEN,
ROCHDALE,
OL11 5UT

PROJECT
57MW BATTERY ENERGY STORAGE
DEVELOPMENT

CLIENT
SHAW-ENERGI LTD.

DRAWING TITLE
EXISTING SITE PLAN

PURPOSE OF ISSUE

PLANNING APPLICATION

DRAWN BY ARP	CHECKED BY IP	DATE May 2023
-----------------	------------------	------------------

SCALE (@ A0)	PROJECT NUMBER
1:200	4130

DRAWING NUMBER	REV
4130-P-502	