




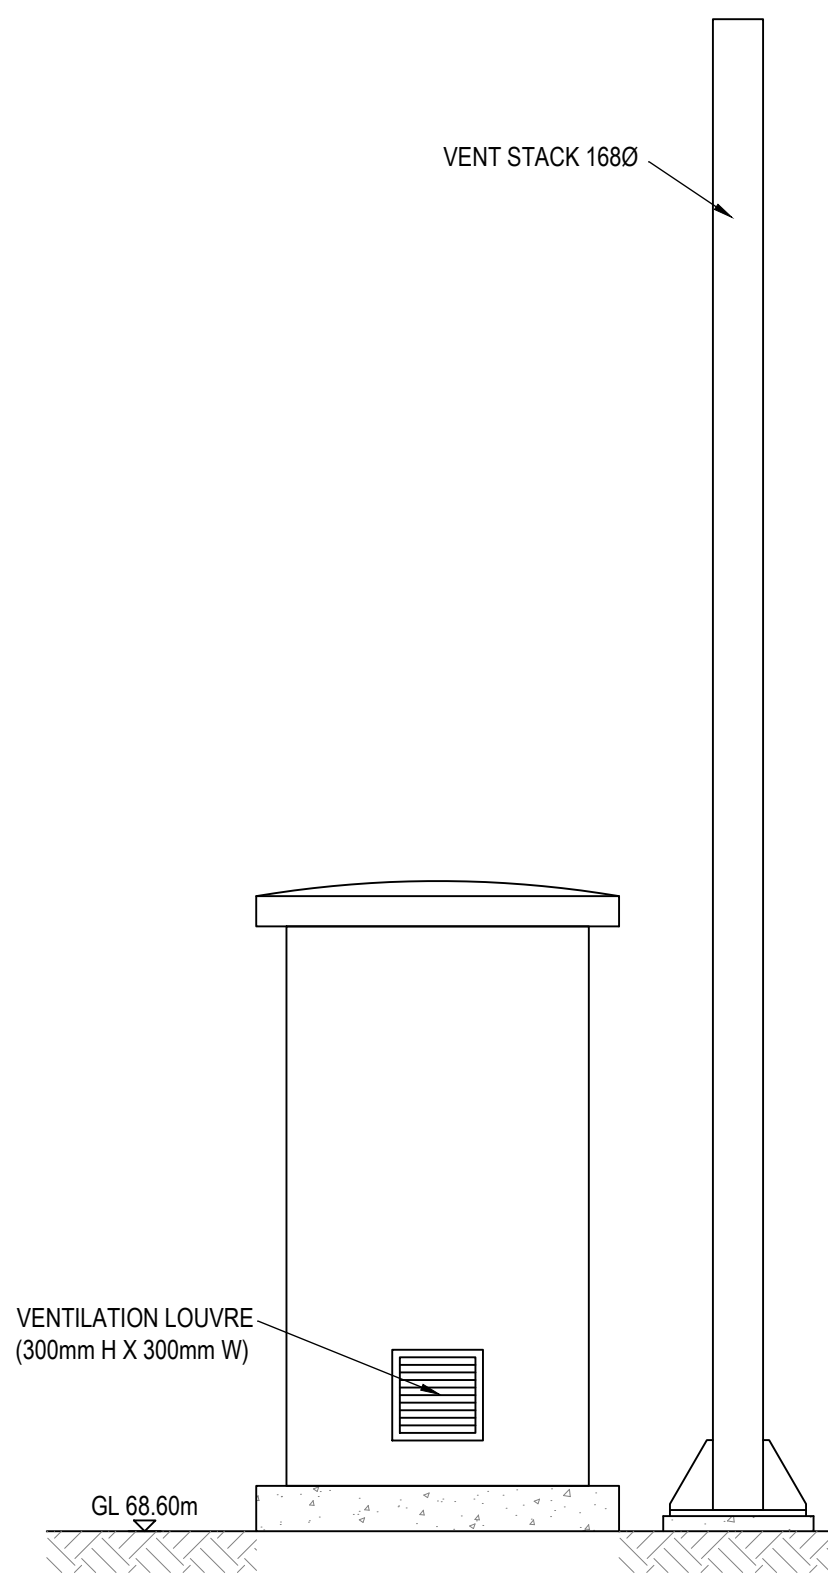


NORTH ELEVATION

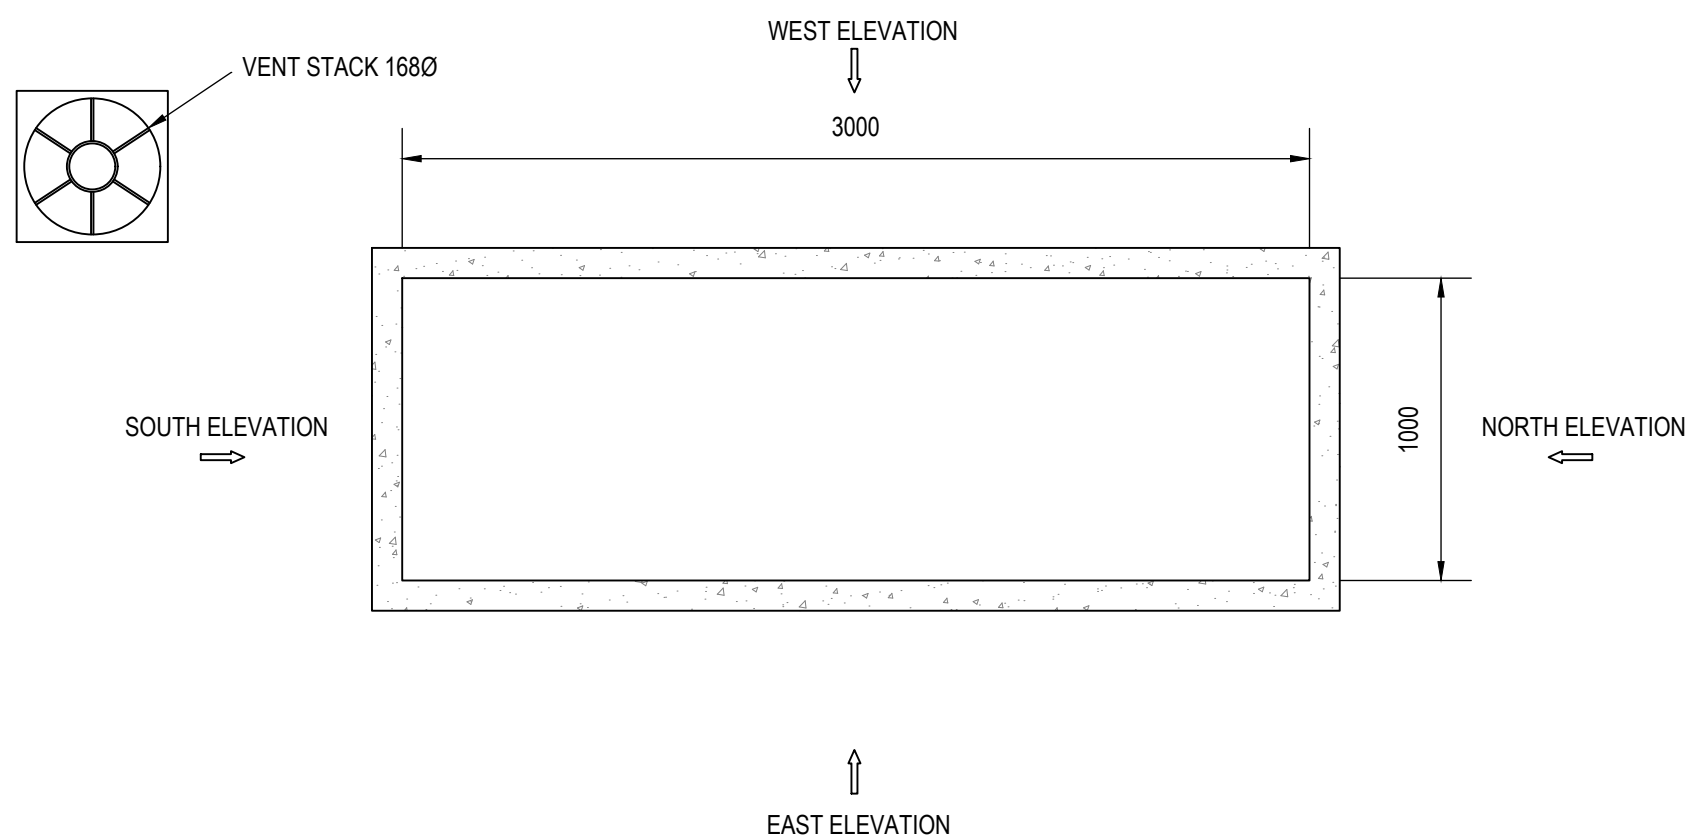


PLAN

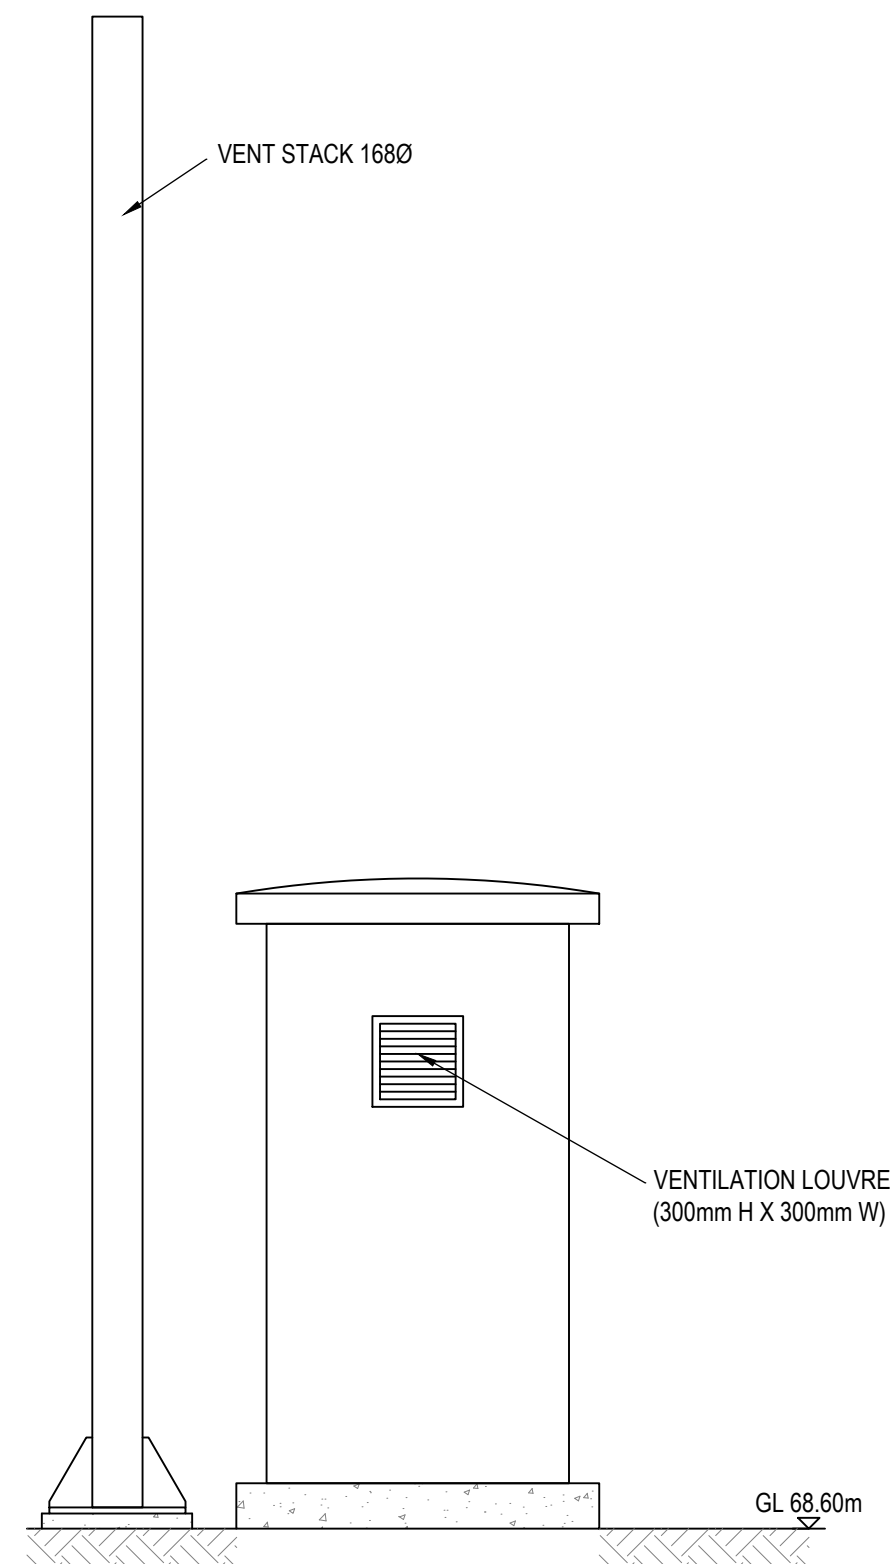

SOUTH ELEVATION

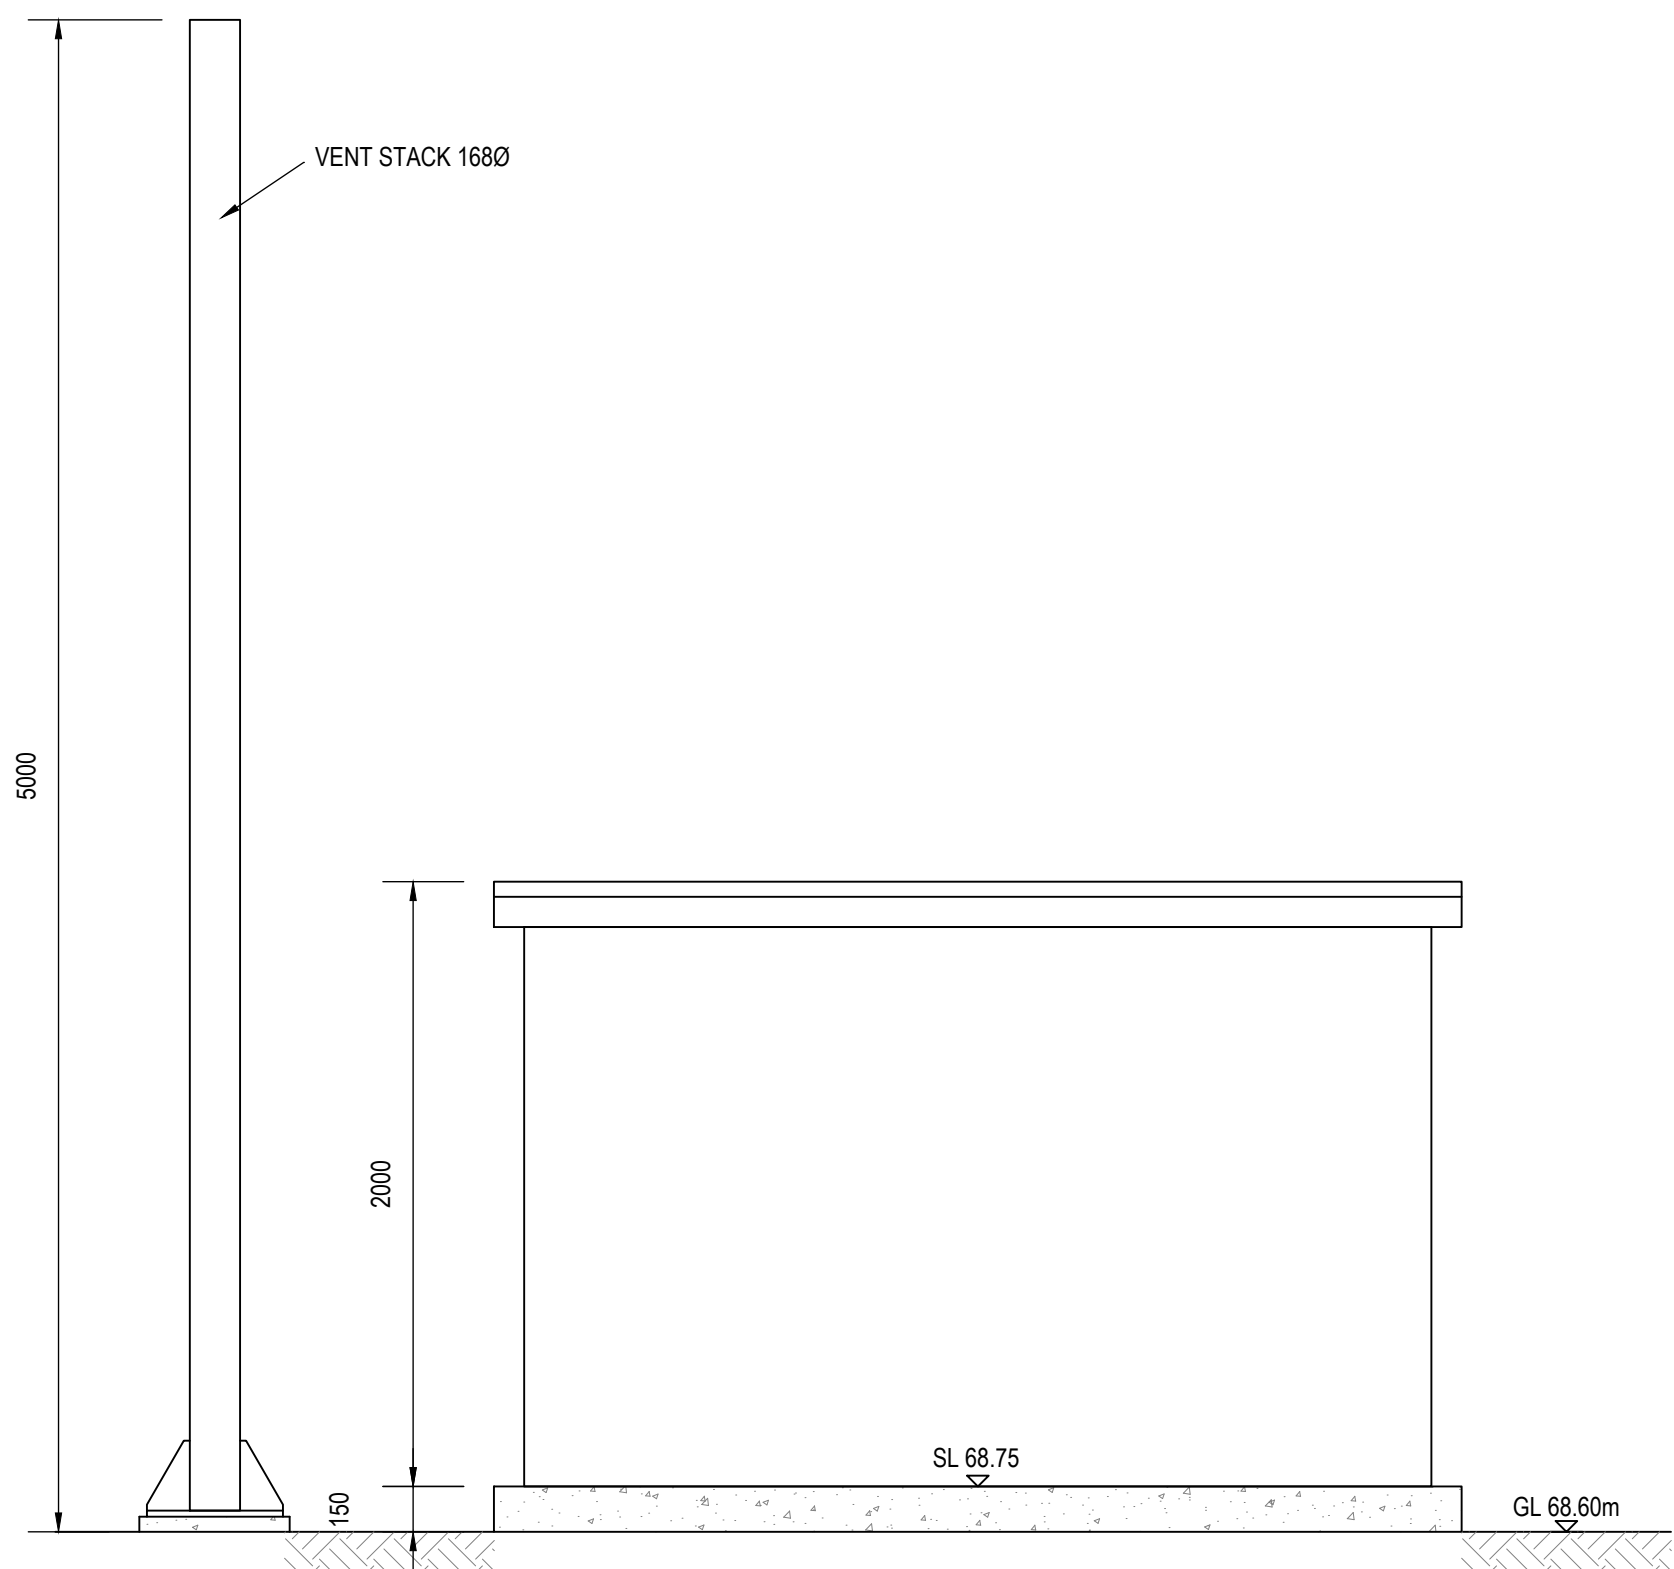

EAST ELEVATION

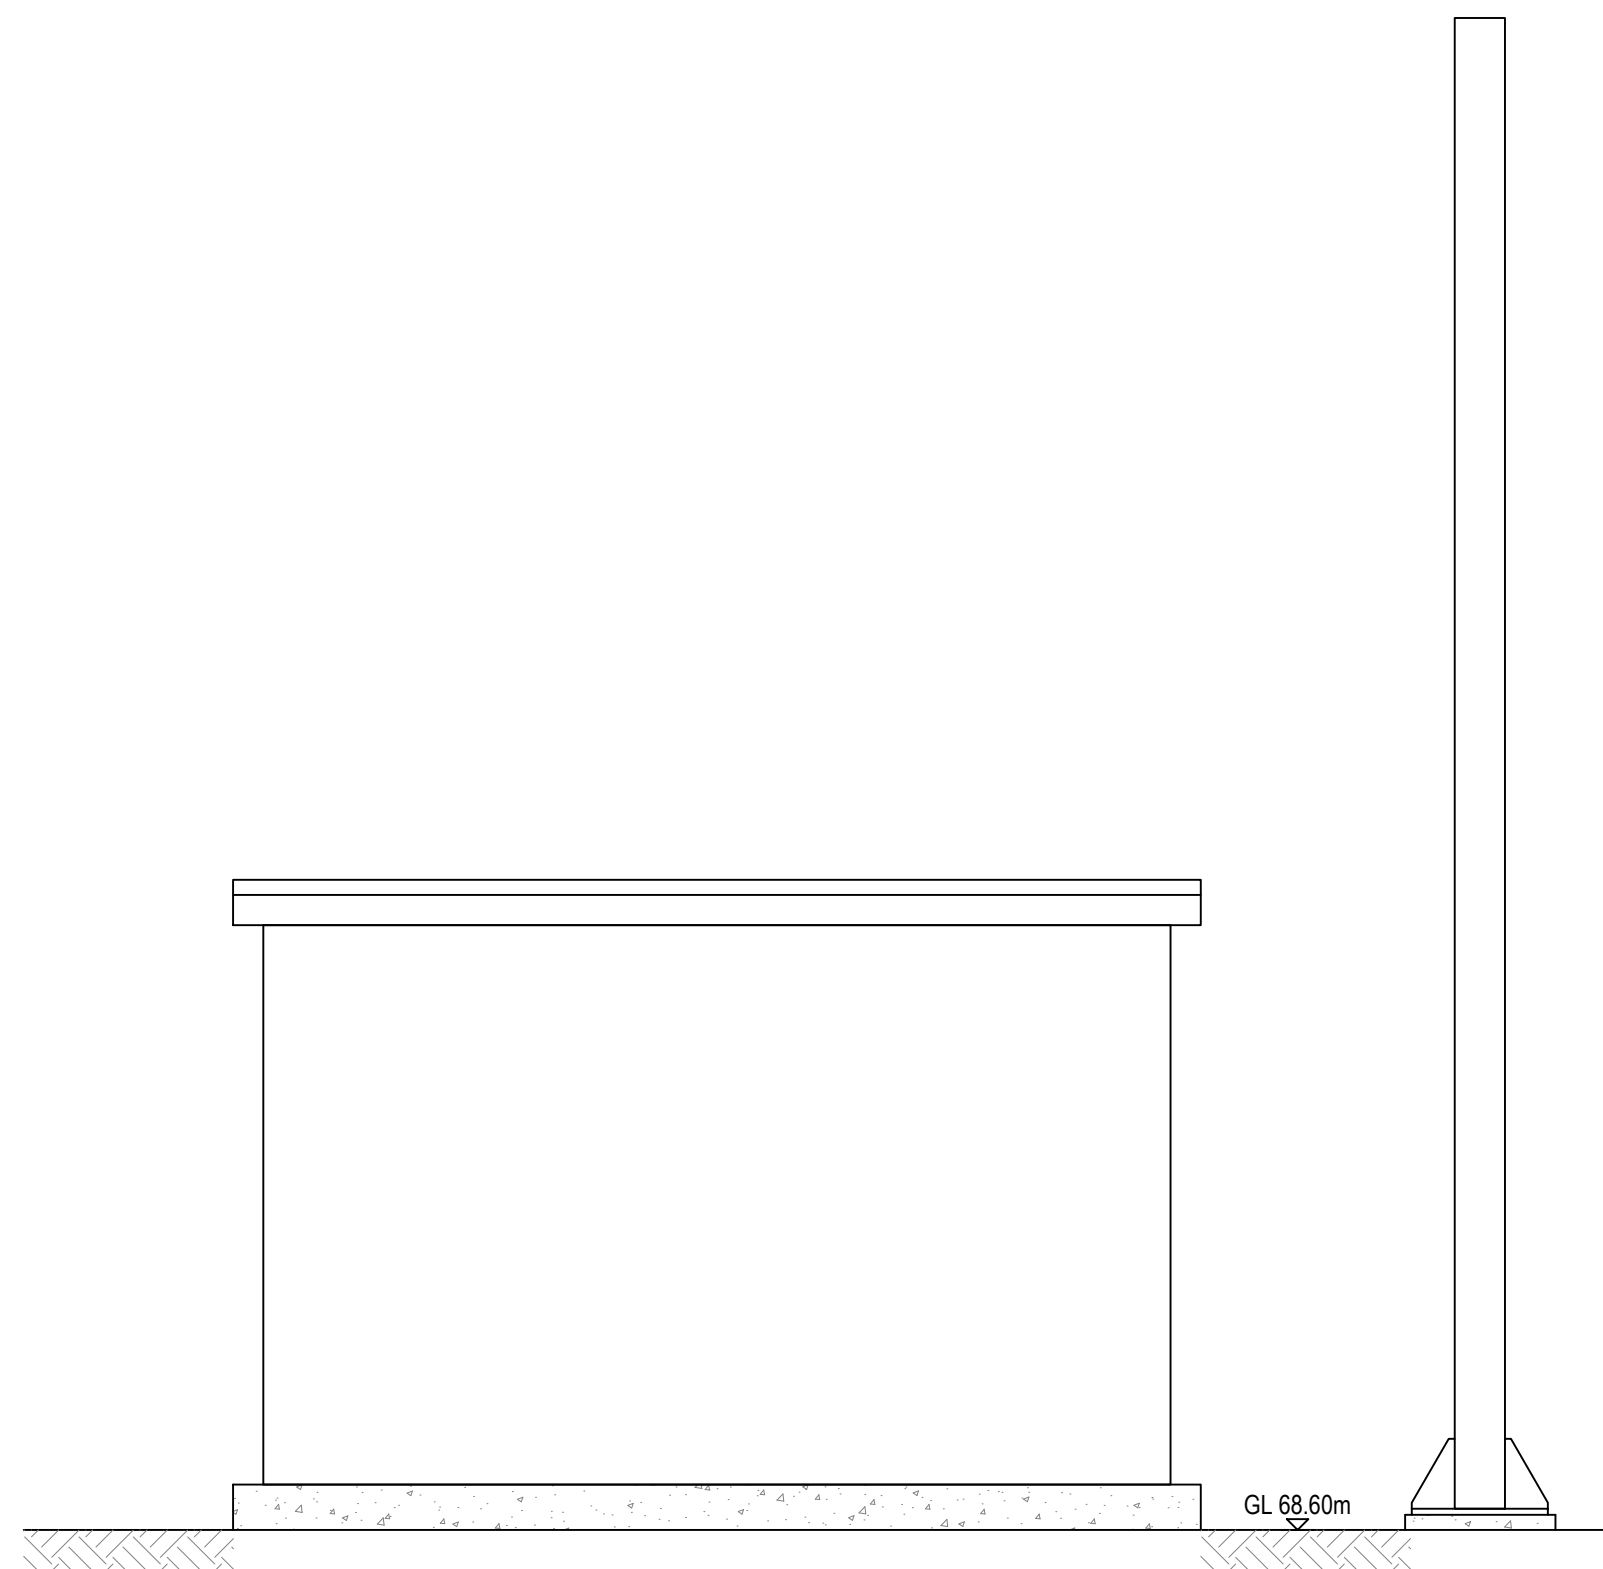

WEST ELEVATION

NOTES:

1. This drawing is to be read in conjunction with other Eastwood Consulting Engineers drawings prefixed 48304.
2. All dimensions are in millimetres unless indicated otherwise. Dimensions shown are the external dimensions to the MCC kiosk.
3. Louvres to be colour matched to kiosk.

PROPOSED MATERIAL:

MCC Kiosk - Glass reinforced plastic
Colour - 14 C 39 Holly Green (BS4800)
Base Construction - Reinforced concrete

Vent Stack - Powder coated steel
Colour - Grey (Matt finish) RAL7047

P01	First issue.	DW	VS	06.03.2024
REV	DESCRIPTION	SIG	CHK	DATE

MORRISON
Water Services
A part of **MGroup**Services

United
Utilities
helping life flow smoothly

BOOTHROYDEN RD CSO

PROPOSED MCC KIOSK AND VENT
STACK PLAN AND ELEVATIONS

Eastwood
CONSULTING ENGINEERS
St Andrew's House
23 Kingfield Road
Sheffield, S11 9AS
T: 0114 255 4554
E: mail@eastwoodce.com
eastwoodce.com

ECE PROJECT No	SCALE AT A1	STATUS	SUITABLE FOR	REV
48304	1:25	S0	Initial	
DRAWING NUMBER				REV
48304 - ECE - XX - XX - DR - C - 0106				P01
Project	Originator	Zone	Level	Type
				Role
				Number