

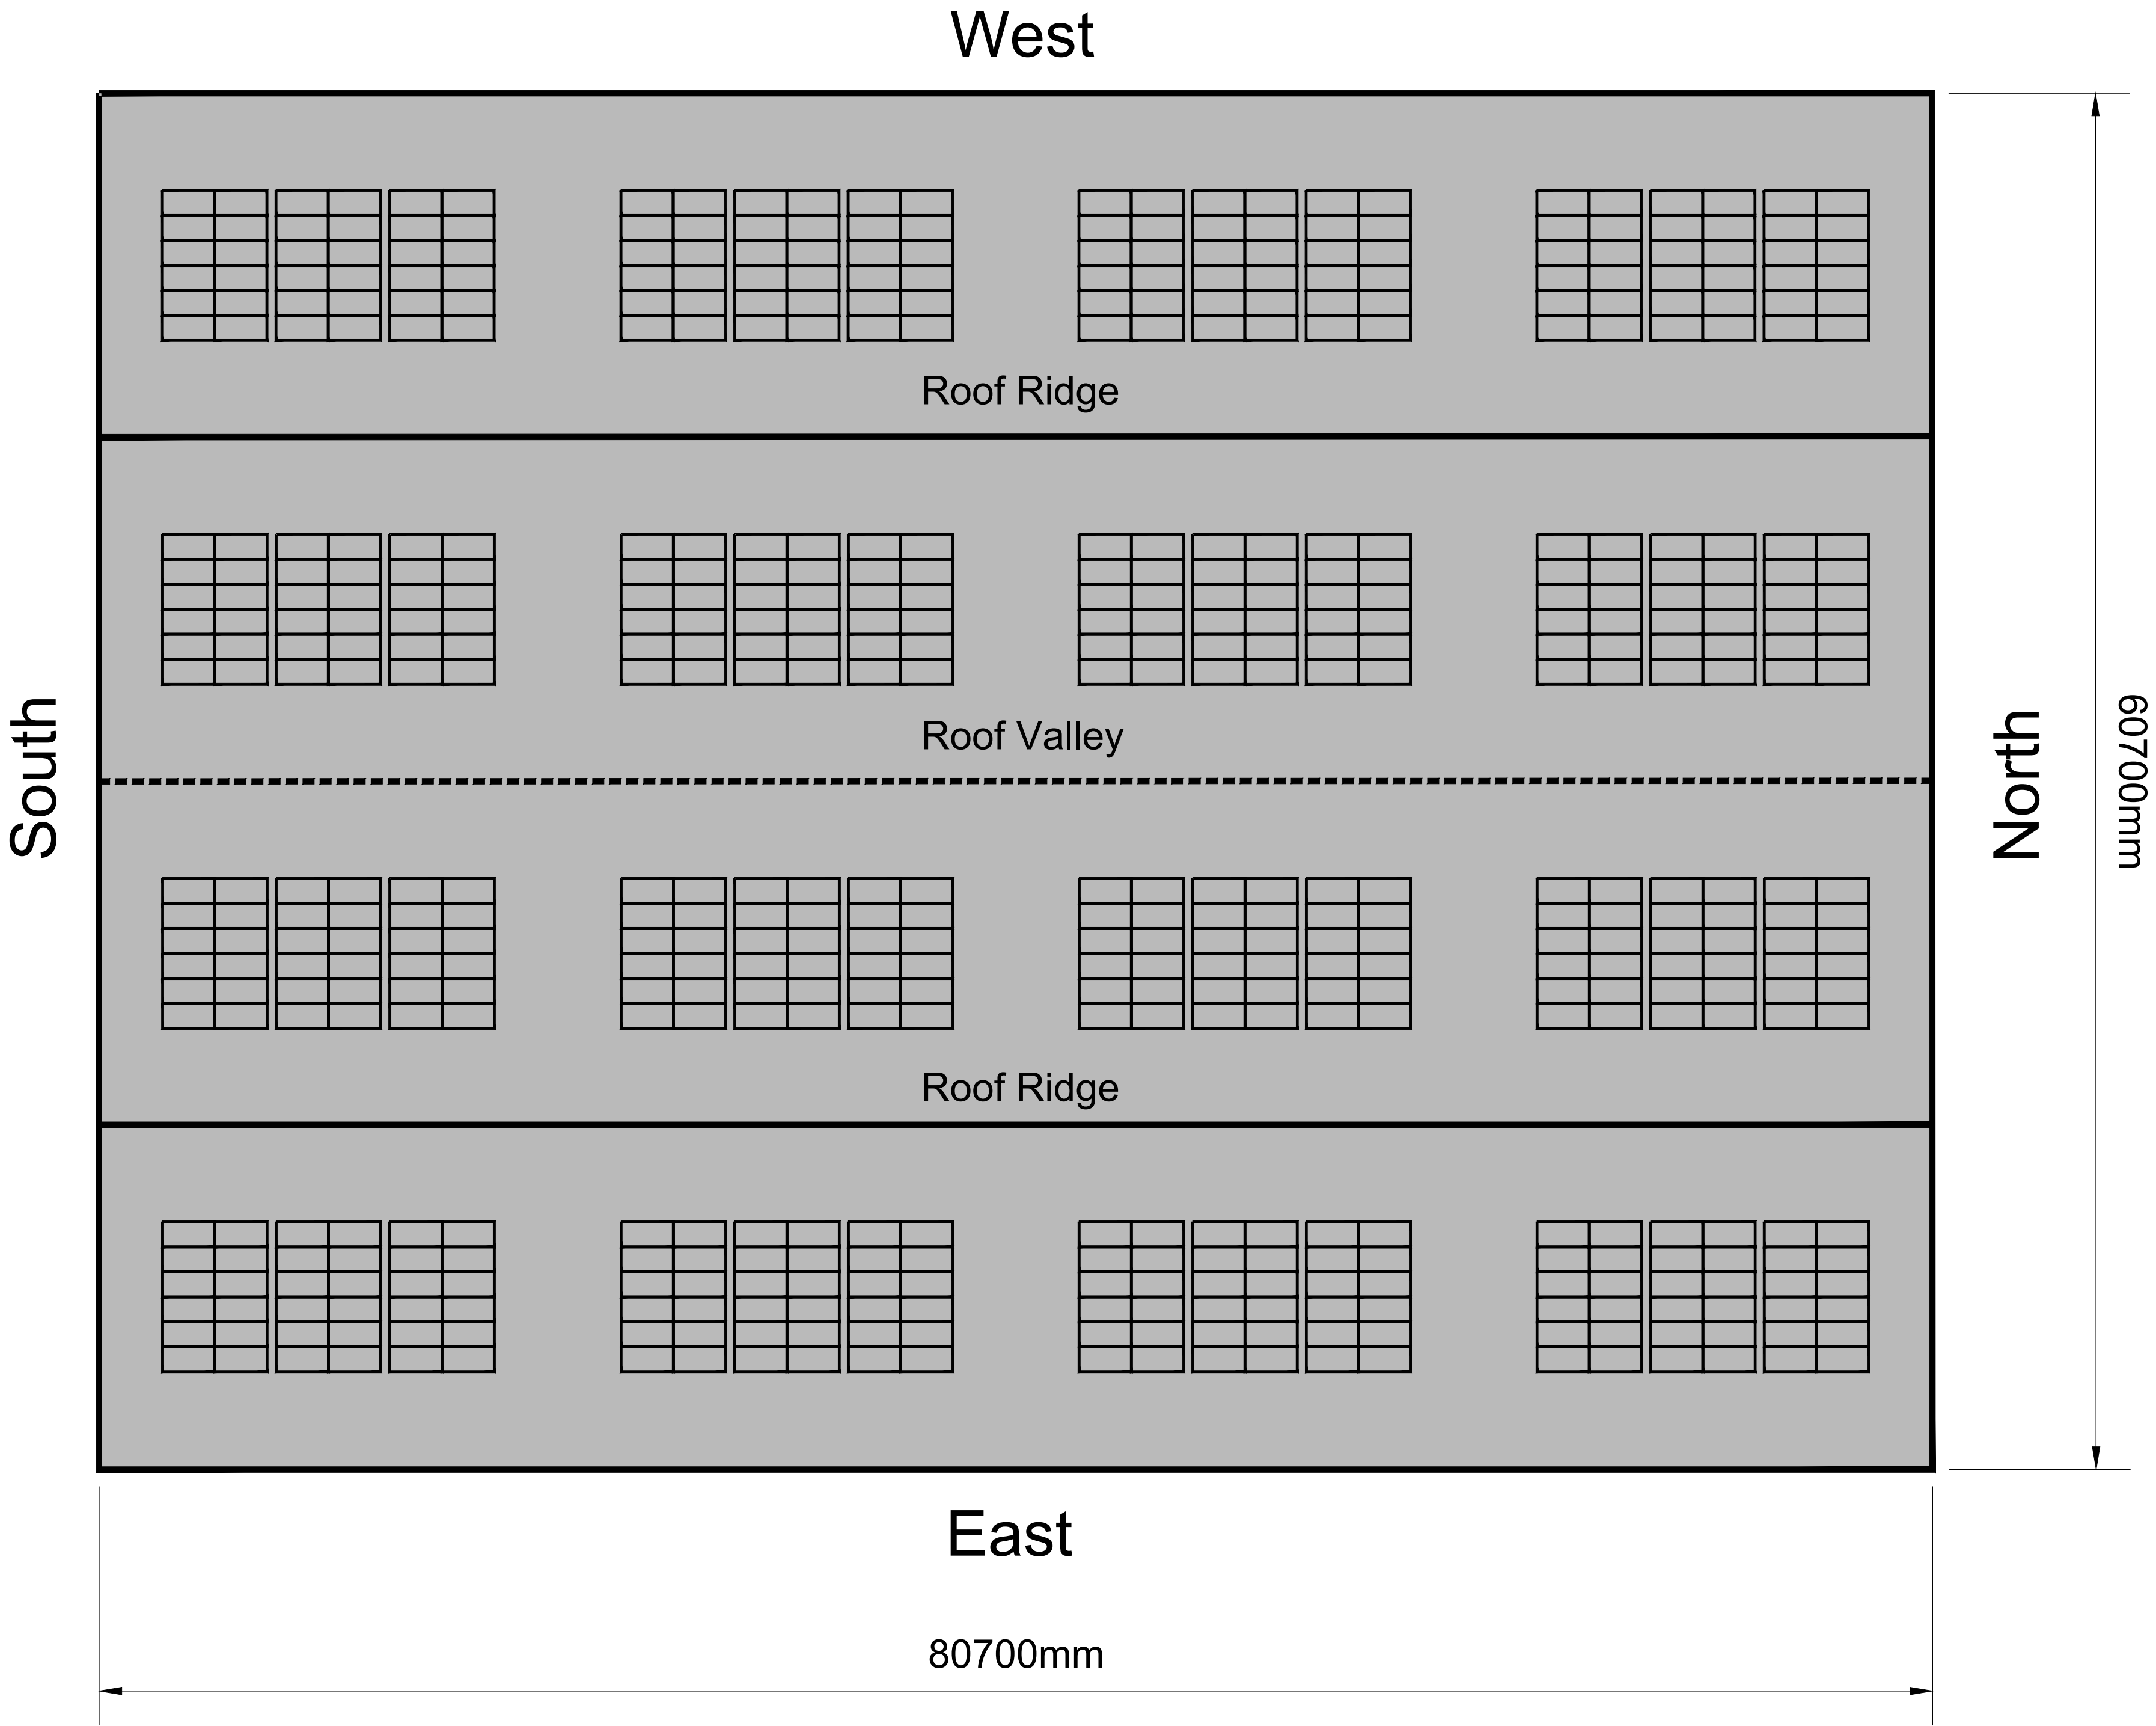


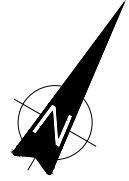

- Notes
1. Survey information provided by Valencia Waste Management Ltd.
 2. All levels in metres Above Ordnance Datum Newlyn.
 3. Do not scale from this drawing.
 4. Any anomalies on this drawing should be brought to the attention of Egniol Consulting Ltd.
 5. MRF Building Paint Code '8512829'.
 6. Standard industrial solar panel size of 2.3m x 1.1m in a indicative 36 cell configuration.

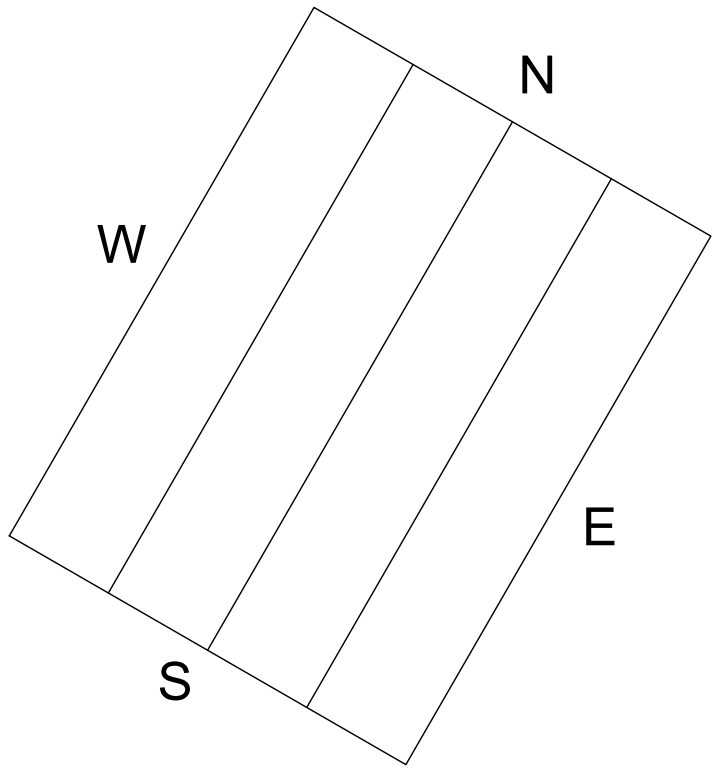

Rev	Modification	By	Chk	App	Date
 Egniol Consulting Limited Unit 7, Llys Onnen, Ffordd y Llyn Parc Menai, Bangor, LL57 4DF Telephone: 01248 355996 Email: info@egniol.com					
Valencia Waste Management Ltd					
Pilsworth Landfill Site					
MRF Building Roof Plan					
Drawn by LE	Checked by GOJR	Approved by PD			
Date 31.10.2024	Date 31.10.2024	Date 31.10.2024			
Status Draft					Scale @ A1 1:200
Drawing Number ECL.9595.D01.010					Revision -