


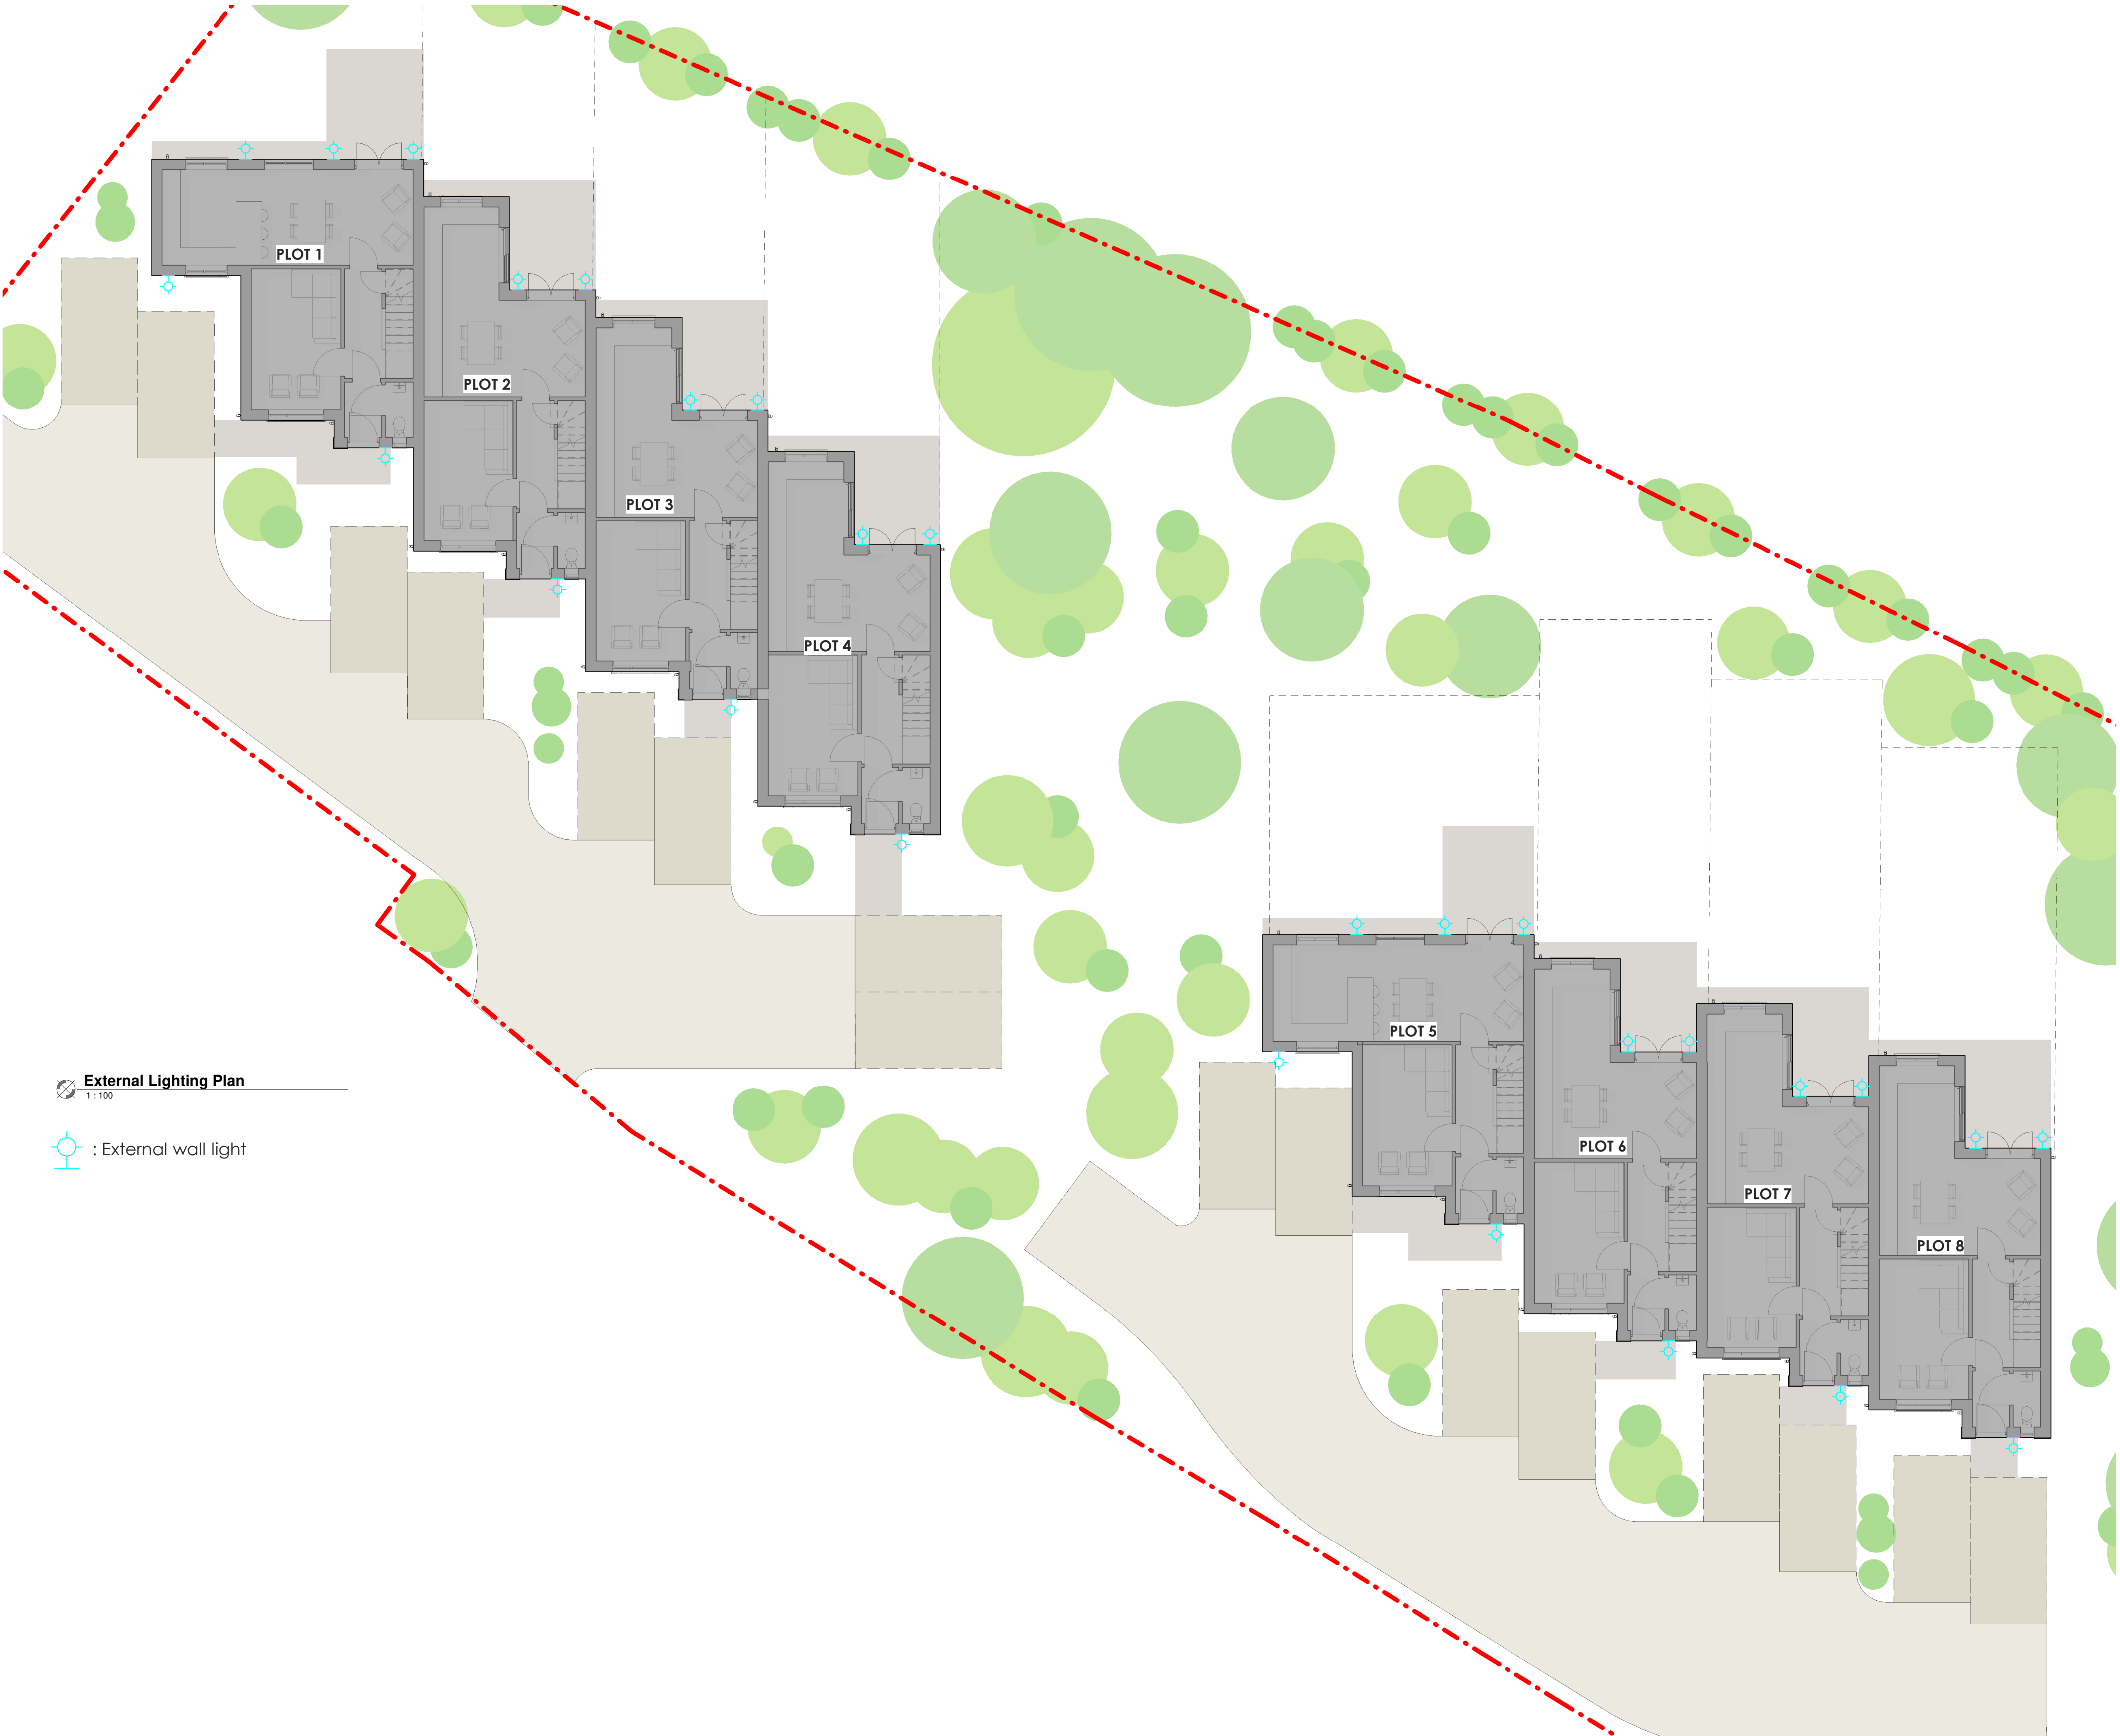

External Lighting Plan
1 : 100

 : External wall light

PLANNING

Do not scale from this drawing

Project
Middleton

Job Number 2693

Revisions			



RIBA Chartered Architects

studio@whiteboxarchitecture.com
www.whiteboxarchitecture.com

Knutsford, Cheshire 01565 754 500

Heswall, Wirral 0151 342 0591

External Lighting Plan

As indicated@A1

Date	Drawn	Checked
02/04/25	JW	IS
Drawing number		Revision