



proposed external lighting layout 1:200

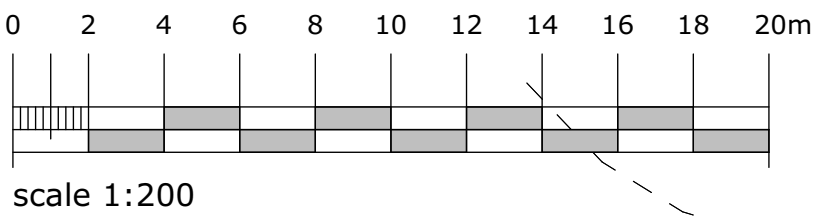

revision notes		
rev	date	description
A:	27.01.25	original issue
B:	27.01.25	building 1&2 repositioned to avoid clash with RPA's

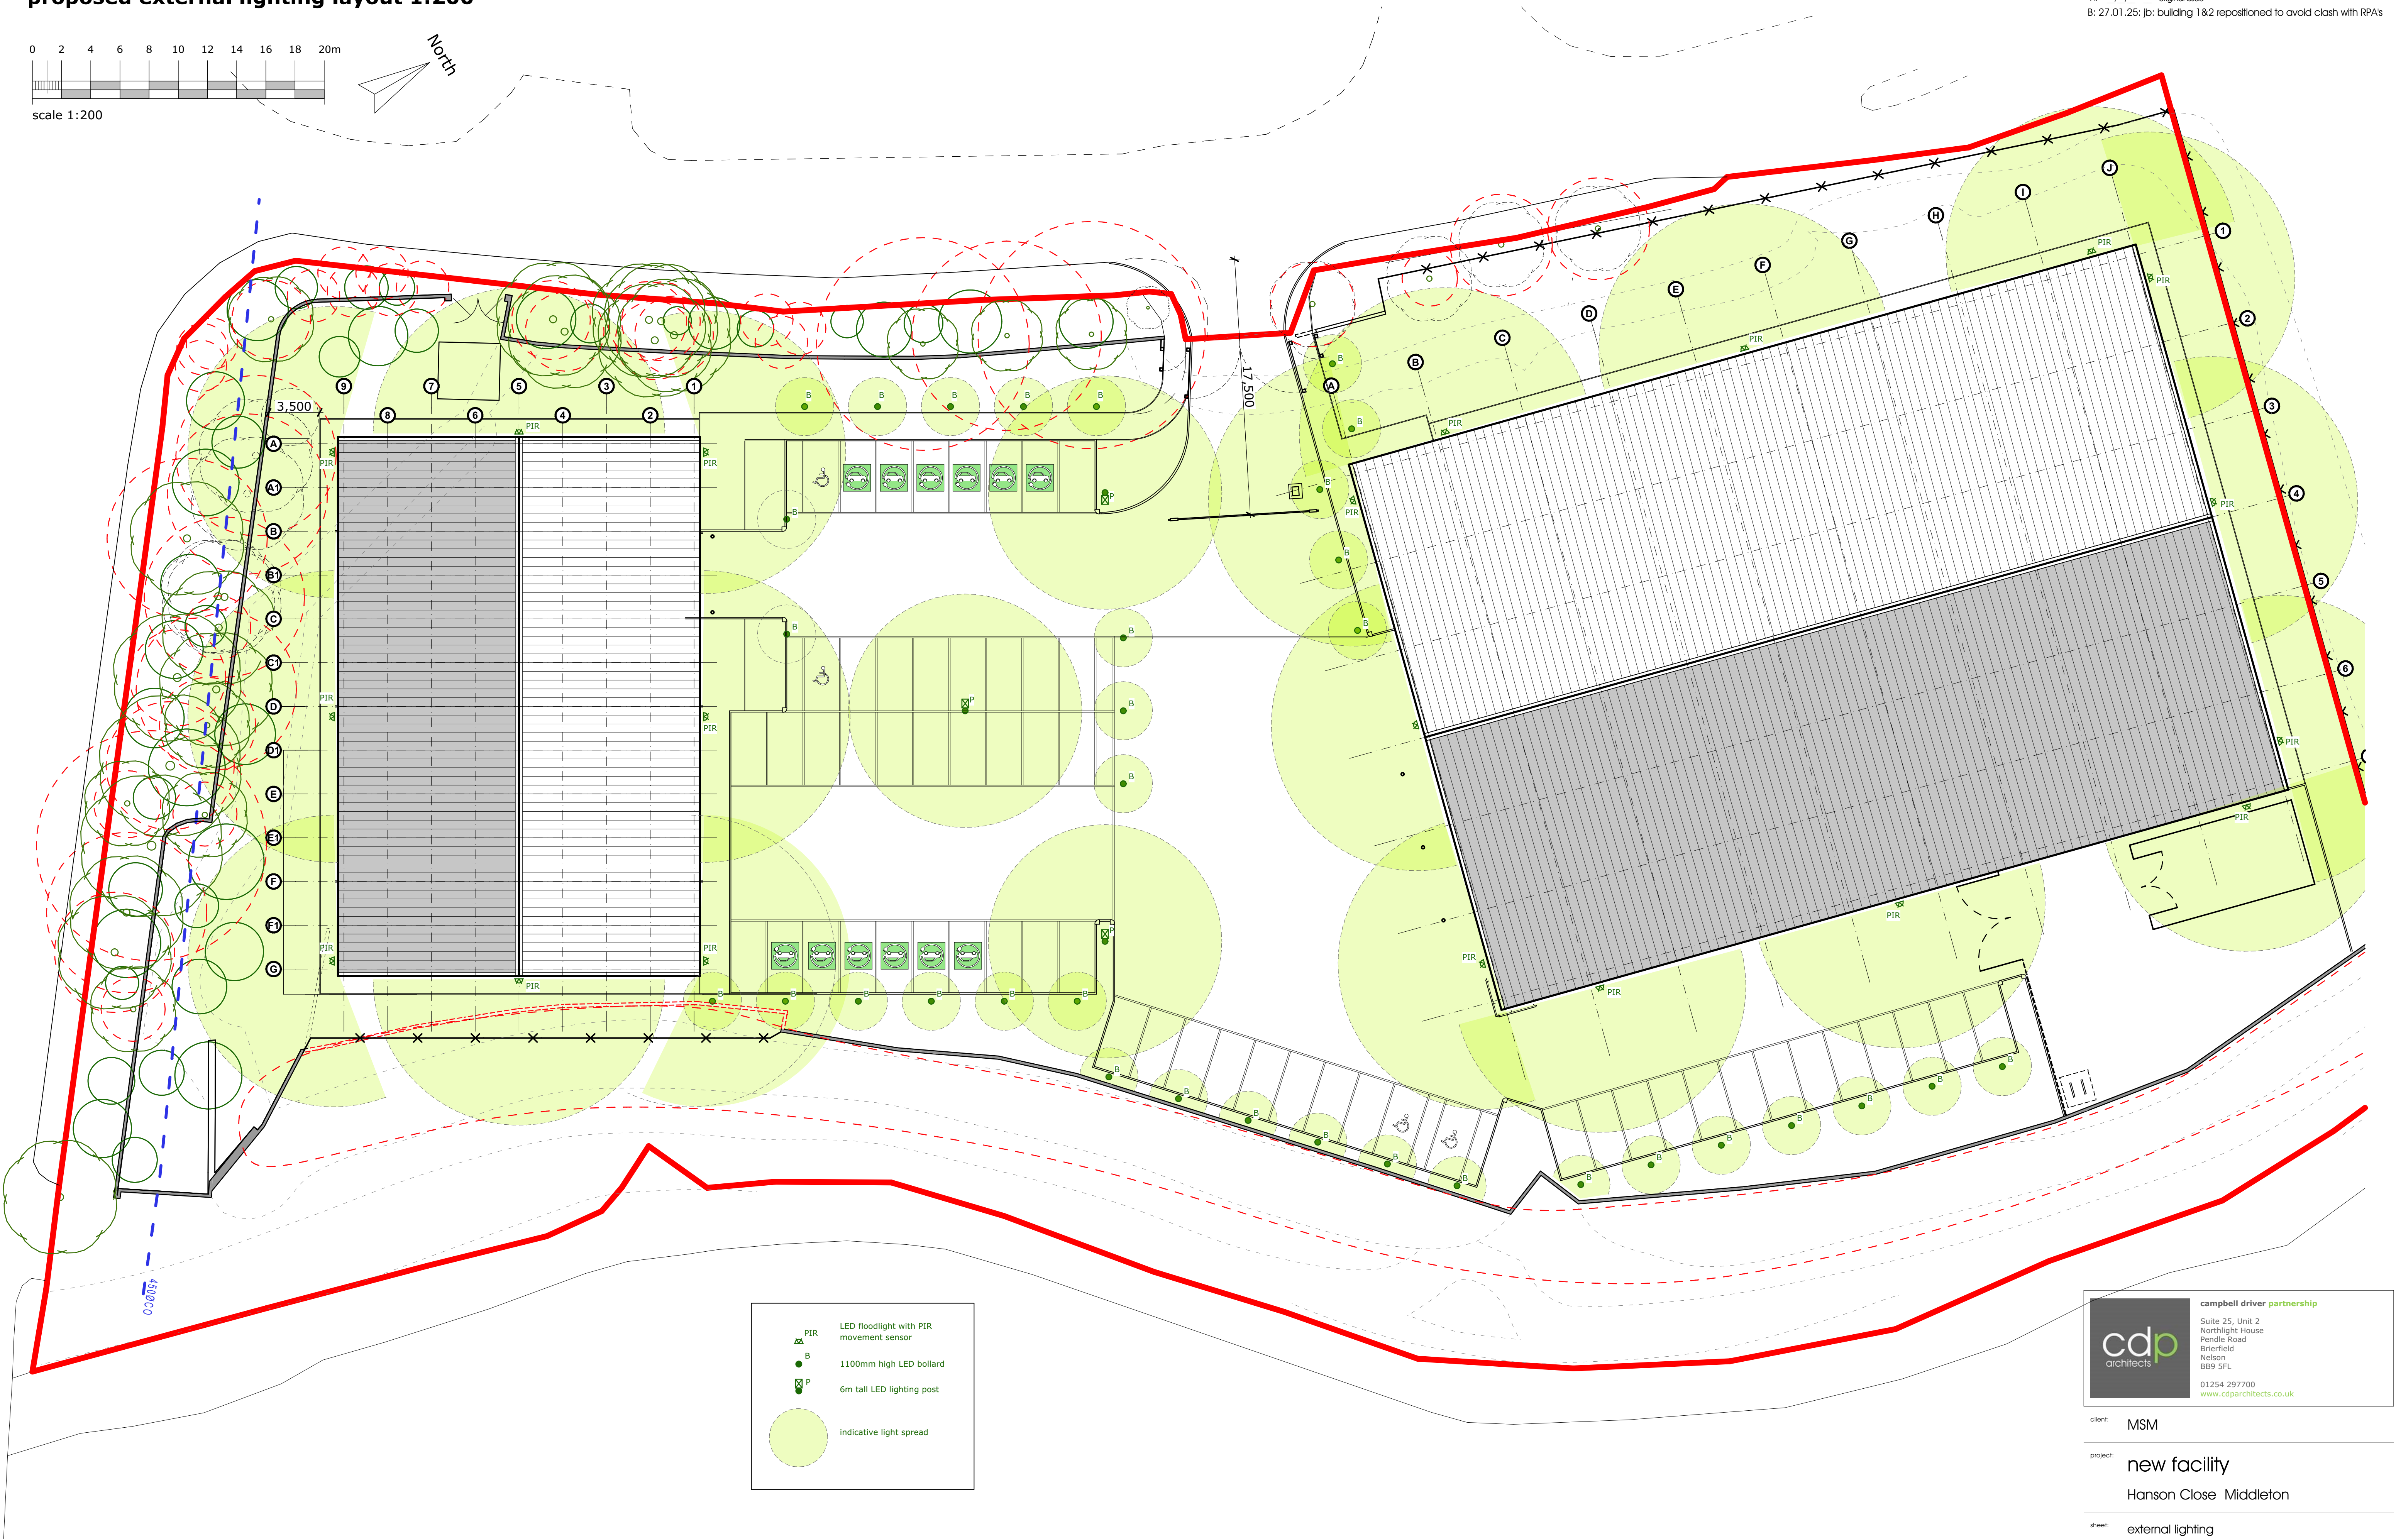

campbell driver partnership

Suite 25, Unit 2
Northlight House
Pendle Road
Brierfield
Nelson
BB9 5PL

01254 297700
www.cdparchitects.co.uk

client:	MSM		
project:	new facility Hanson Close Middleton		
sheet:	external lighting		
drawing no:	22.135_01_011	sheet no:	B
scale:	@ A1		
date:		drawn by:	