


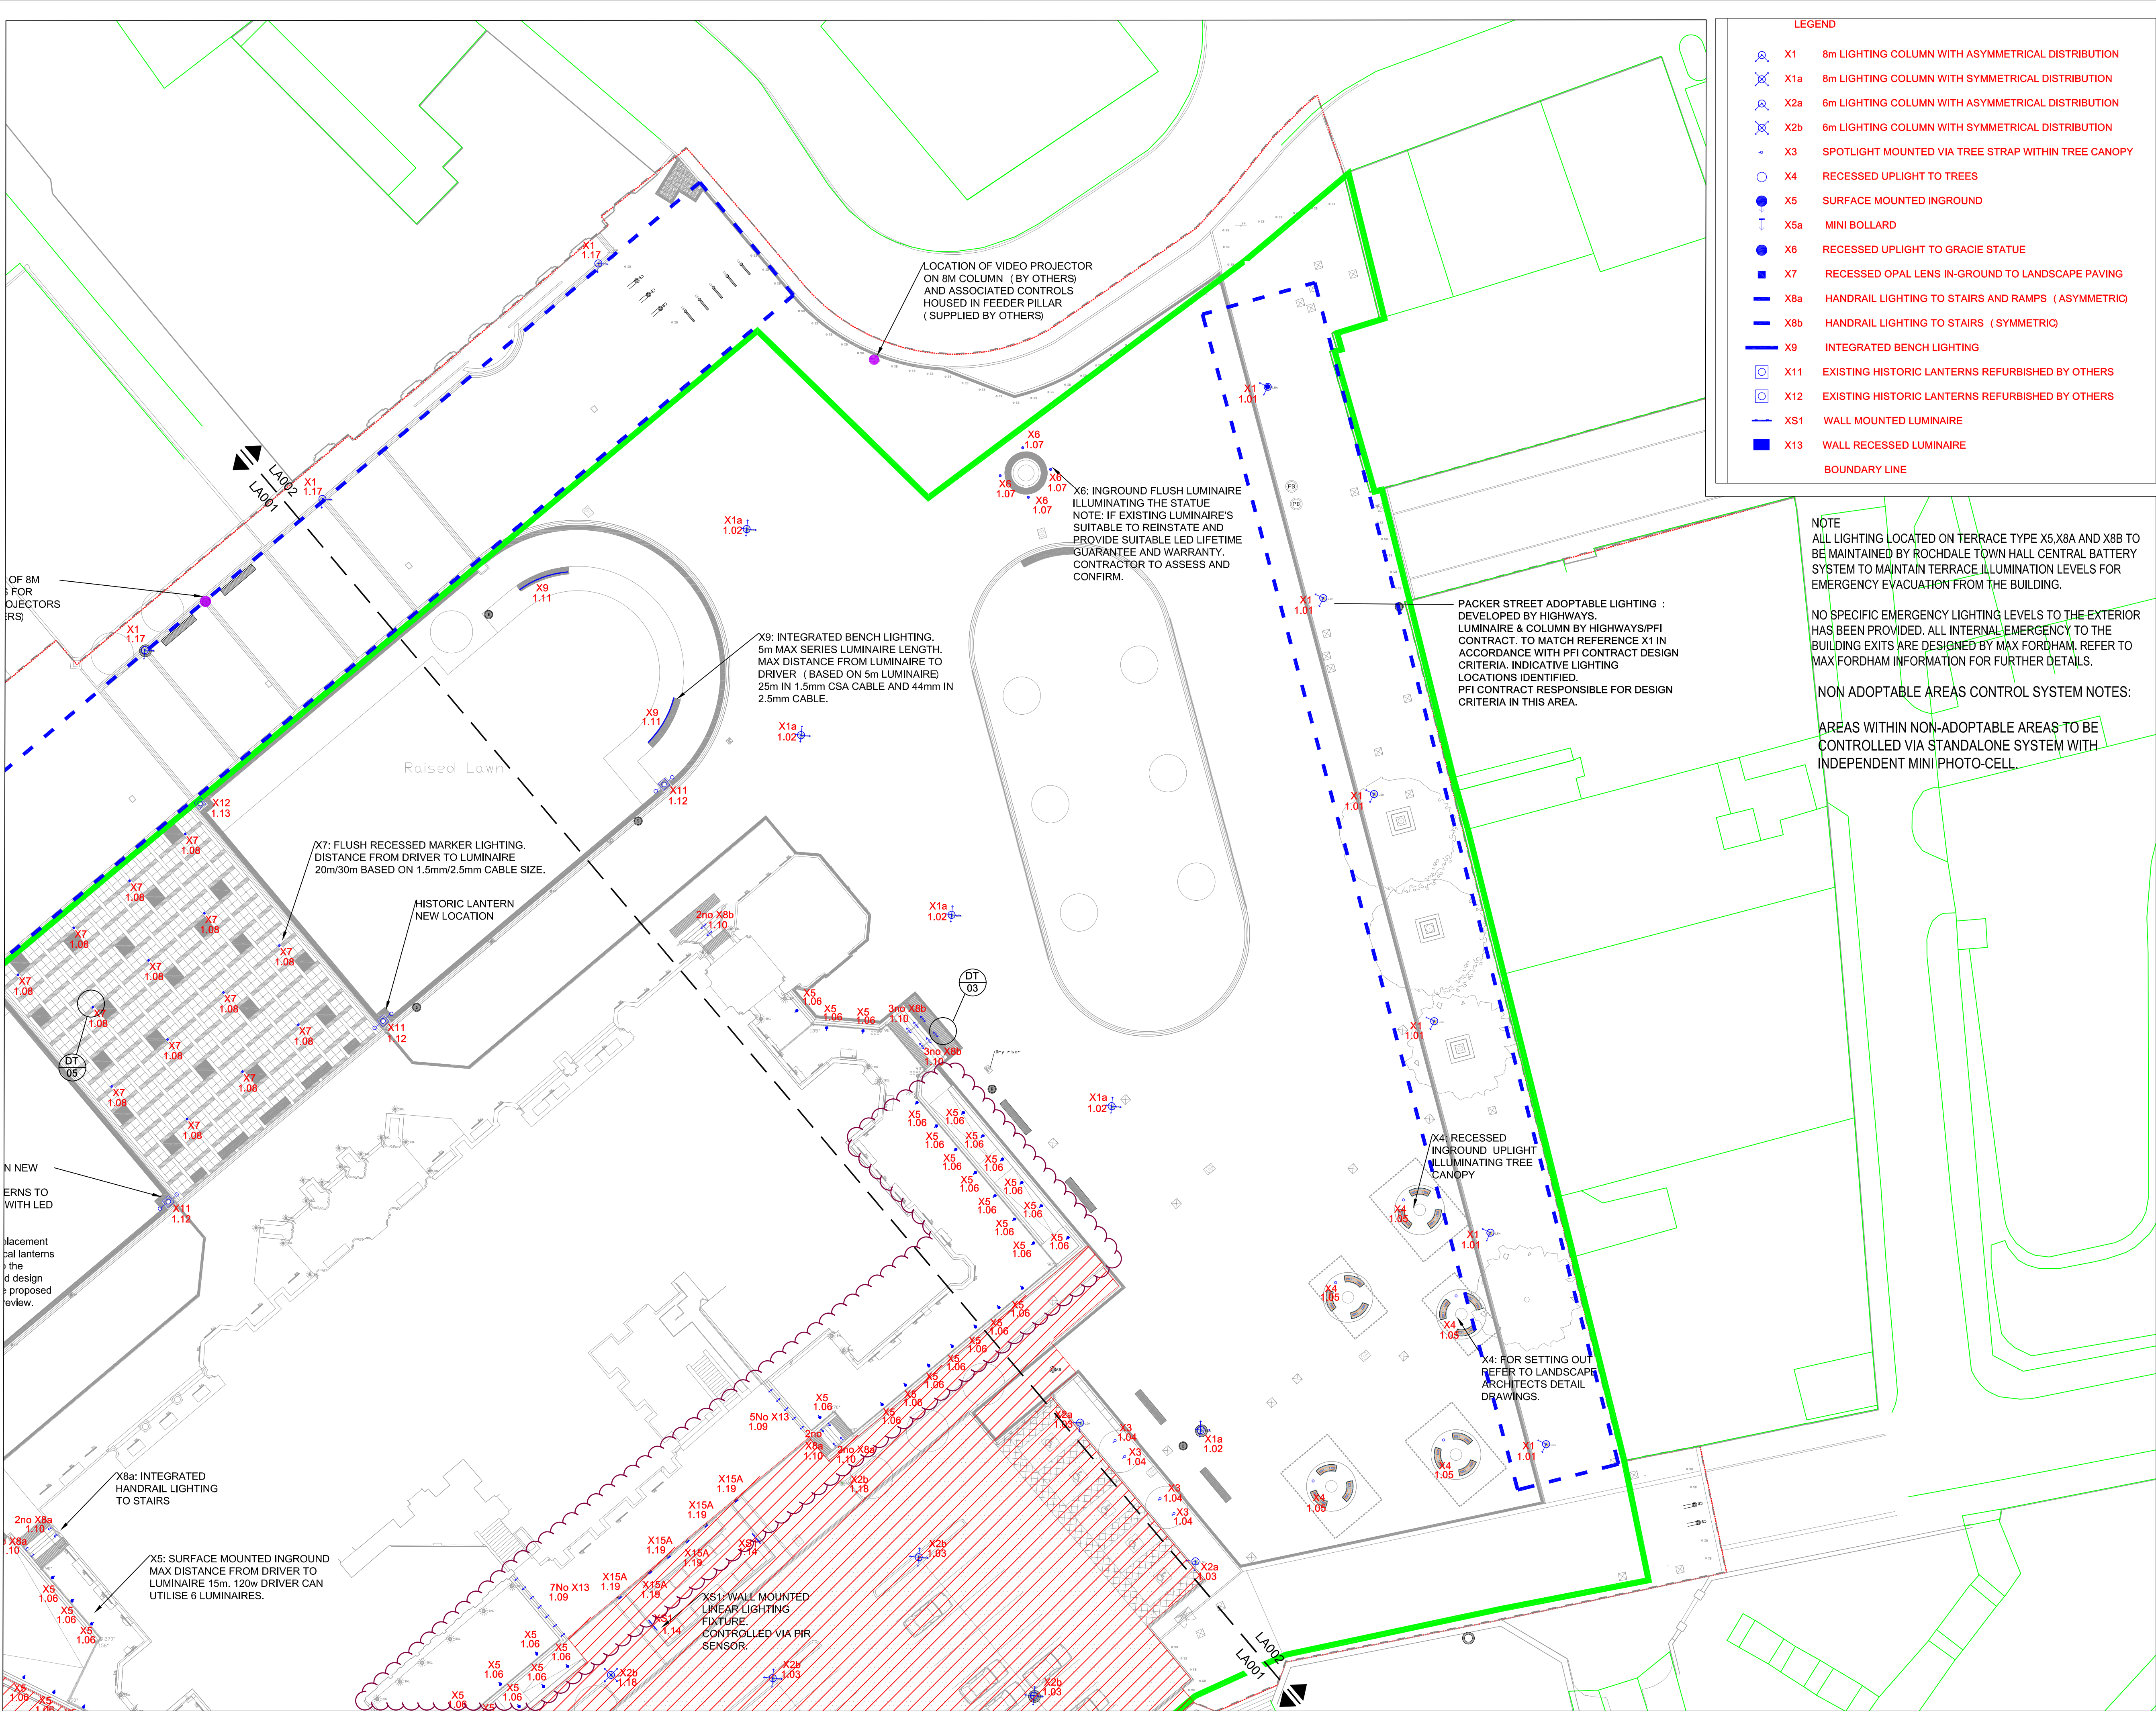

- LEGEND**
- X1 8m LIGHTING COLUMN WITH ASYMMETRICAL DISTRIBUTION
 - X1a 8m LIGHTING COLUMN WITH SYMMETRICAL DISTRIBUTION
 - X2a 6m LIGHTING COLUMN WITH ASYMMETRICAL DISTRIBUTION
 - X2b 6m LIGHTING COLUMN WITH SYMMETRICAL DISTRIBUTION
 - X3 SPOTLIGHT MOUNTED VIA TREE STRAP WITHIN TREE CANOPY
 - X4 RECESSED UPLIGHT TO TREES
 - X5 SURFACE MOUNTED INGROUND
 - X5a MINI BOLLARD
 - X6 RECESSED UPLIGHT TO GRACIE STATUE
 - X7 RECESSED OPAL LENS IN-GROUND TO LANDSCAPE PAVING
 - X8a HANDRAIL LIGHTING TO STAIRS AND RAMPS (ASYMMETRIC)
 - X8b HANDRAIL LIGHTING TO STAIRS (SYMMETRIC)
 - X9 INTEGRATED BENCH LIGHTING
 - X11 EXISTING HISTORIC LANTERNS REFURBISHED BY OTHERS
 - X12 EXISTING HISTORIC LANTERNS REFURBISHED BY OTHERS
 - XS1 WALL MOUNTED LUMINAIRE
 - X13 WALL RECESSED LUMINAIRE
 - BOUNDARY LINE

NOTE
ALL LIGHTING LOCATED ON TERRACE TYPE X5,X8A AND X8B TO BE MAINTAINED BY ROCSDALE TOWN HALL CENTRAL BATTERY SYSTEM TO MAINTAIN TERRACE ILLUMINATION LEVELS FOR EMERGENCY EVACUATION FROM THE BUILDING.

NO SPECIFIC EMERGENCY LIGHTING LEVELS TO THE EXTERIOR HAS BEEN PROVIDED. ALL INTERNAL EMERGENCY TO THE BUILDING EXITS ARE DESIGNED BY MAX FORDHAM. REFER TO MAX FORDHAM INFORMATION FOR FURTHER DETAILS.

NON ADOPTABLE AREAS CONTROL SYSTEM NOTES:

AREAS WITHIN NON-ADOPTABLE AREAS TO BE CONTROLLED VIA STANDALONE SYSTEM WITH INDEPENDENT MINI PHOTO-CELL.

© Buro Happold Limited or its group companies.
All Rights reserved. Buro Happold and its group companies assert (unless otherwise agreed in writing) their rights under s.77 to 84 of the Copyright, Designs and Patents Act 1988.

DO NOT SCALE THIS DRAWING.

HEALTH AND SAFETY INFORMATION

IN ADDITION TO THE HAZARDS/RISKS NORMALLY ASSOCIATED WITH THE TYPES OF WORK DETAILED ON THIS DRAWING, NOTE THE FOLLOWING CONSTRUCTION.

MAINTENANCE/CLEANING/OPERATION

DECOMMISSIONING/DEMOLITION

Notes

- LIGHTING NOTES**
- THIS DRAWING IS TO BE READ IN CONJUNCTION WITH ALL OTHER DISCIPLINES, DRAWINGS, SCHEDULES AND SPECIFICATIONS, LEGENDS AND STANDARD DETAILS.
 - THIS DRAWING IS COPYRIGHT AND SHALL NOT BE REPRODUCED WITHOUT PERMISSION.
 - DIMENSIONS GOVERN ON ALL DRAWINGS AND DETAILS. SHOULD ANY DISCREPANCIES BE FOUND WITH THIS DRAWING AND ANY ASSOCIATED DRAWINGS OR SPECIFICATIONS THIS SHOULD BE BROUGHT TO THE ATTENTION OF THE M&E BUILDING SERVICES CONSULTANT IMMEDIATELY.
 - UNLESS OTHERWISE STATED ALL DIMENSIONS ARE IN MILLIMETRES.
 - DO NOT SCALE FROM THIS DRAWING.
 - DIMENSIONS TO BE CHECKED ON SITE BEFORE ANY WORK IS PUT IN HAND OR PREFABRICATED.
 - THIS DRAWING SHOULD ONLY BE USED FOR THE SPECIFIC SERVICES INTENDED.
 - THIS DRAWING SHOWS THE DESIGN INTENT ONLY. THE CONTRACTOR SHALL BE RESPONSIBLE FOR THE FULL CO-ORDINATION OF THE SERVICES INDICATED ON THIS AND ALL OTHER SERVICES DRAWINGS.
 - FINAL ACCESS AND SETTING OUT OF SERVICES SHALL BE AGREED BETWEEN THE ARCHITECT AND THE CONTRACTOR.
 - THE PROJECT NOTES ARE TO BE READ IN CONJUNCTION WITH ALL RELEVANT TECHNICAL SPECIFICATIONS.
 - FOR THE SPECIFICATION OF ALL LUMINAIRES PLEASE REFER TO THE LUMINAIRE SCHEDULE.

FOR ADOPTABLE HIGHWAY LIGHTING DESIGN LAYOUT AND STANDARD DETAILS FOR ESPLANADE REFER TO ROCSDALE COUNCIL DRAWINGS:

P0067-12-14-1302-01
P0067-12-14-1401-01

THE CONTRACTOR MUST CONSULT AND COMPLY WITH ALL THE REQUIREMENTS OF OLDHAM AND ROCSDALE COUNCIL'S STREET LIGHTING PFI SPECIFICATION AND THE SPECIFICATION OF ROAD LIGHTING.

ANY PROPOSED COLUMN POSITIONS ARE TO BE JOINTLY MARKED OUR ON SITE BY THE ROCSDALE MBC STREET LIGHTING ENGINEER.

C04 Construction - Lighting location update	03/03/23	AR	CH	
C03 Construction - Packer street update	31/10/22	AR	CH	
C02 Construction - Packer street update	04/08/22	AR	CH	
C01 Construction	06/07/22	AR	CH	
10 Tree lighting omitted - Clouded	07/06/22	AR	CH	
09 Bench light omitted - Clouded	04/05/22	LK	AR	
08 Design change	29/03/22	LK	AR	
07 Terrace update	25/11/21	AR	CH	
06 Terrace update	01/10/21	AR	CH	
05 Stage 4 - For Tender	26/05/21	AR	CH	
04 Stage 4 - PFI Approval	03/05/21	AR	CH	
03 Stage 4	26/01/21	LK	AR	
02 Stage 4	11/12/20	LK	AR	
01 For information	16/04/20	LK	AR	
Rev	Description	Date	Drawn By	Approved

CONSTRUCTION

Status/Suitability of drawing

**BUROHAPPOLD
ENGINEERING**

17 Newman Street
London
W1T 3EQ
UK

Tel: +44 (0)20 7927 9700
Fax: +44 (0)20 787 4145
Web: www.burohappold.com

Architect **GILLESPIES**
Project **ROCHDALE TOWN HALL SQUARE**
Drg Title **Lighting layout Sheet 2**

Scales@A1	1:250	Job No.	0042509
Drawing No.	042509_LA002	Revision	C04