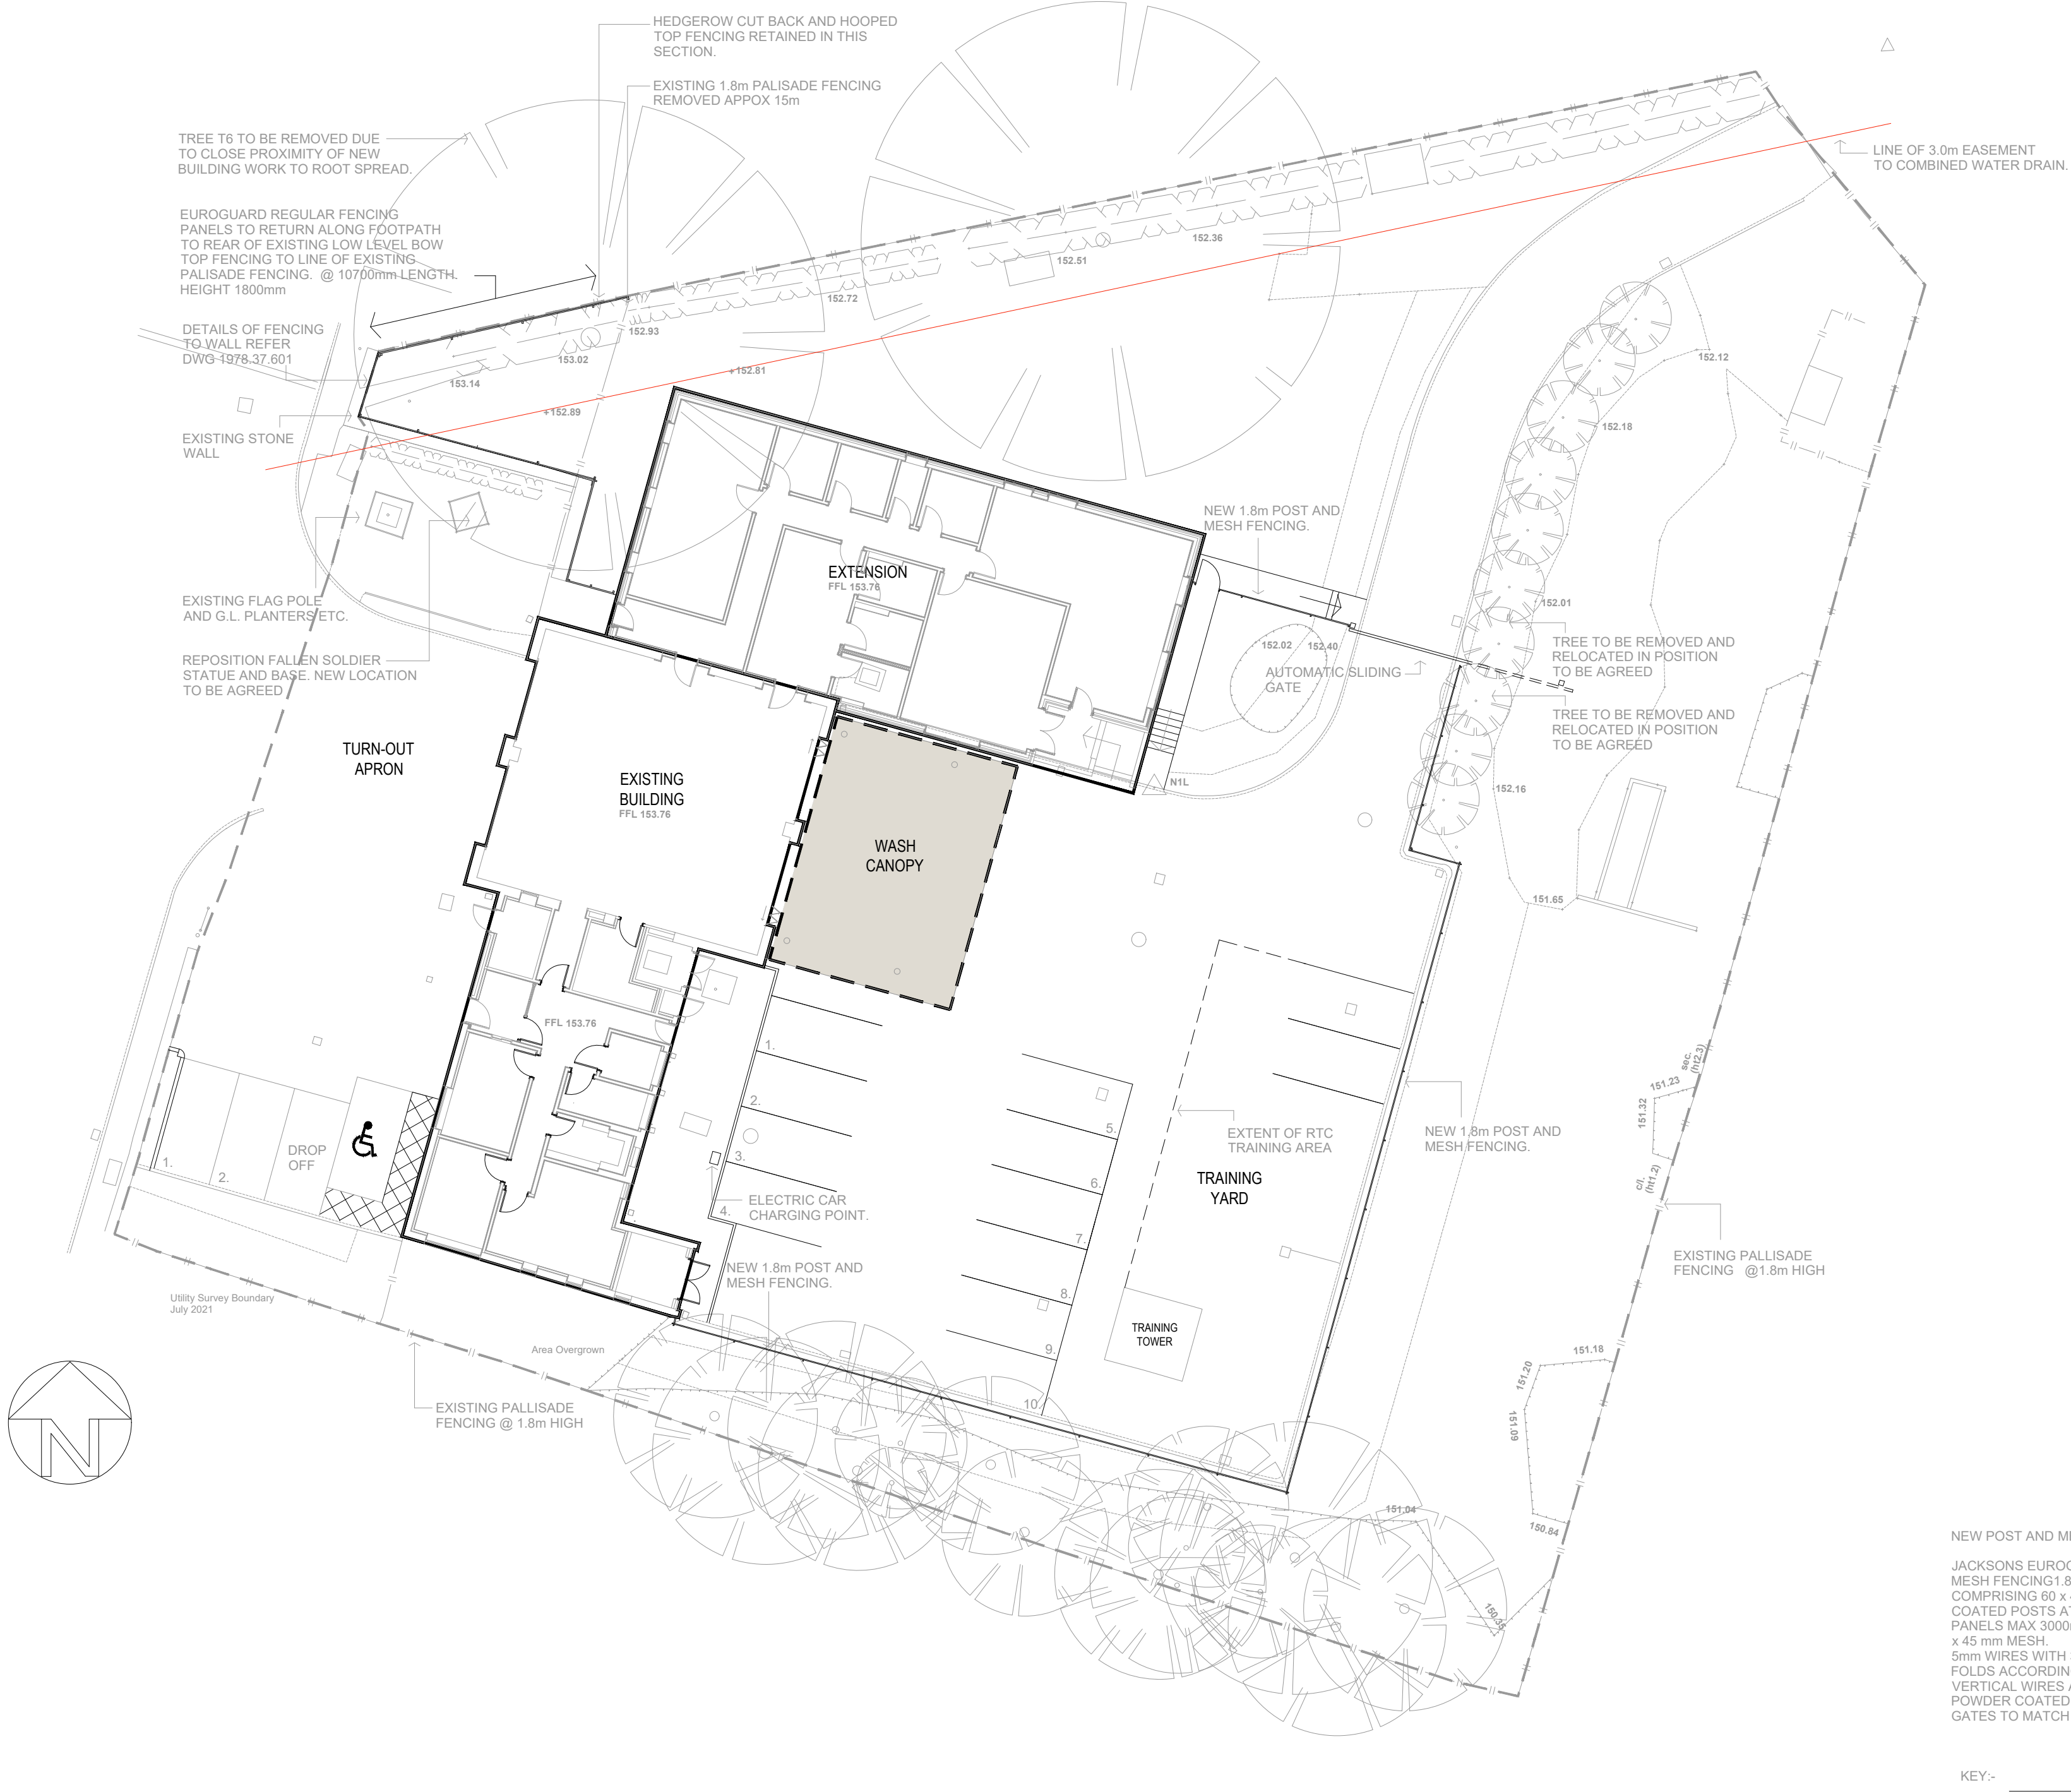


status			TENDER
This drawing is ©Bradshaw Gass & Hope LLP and is not to be copied, reproduced or re-distributed either in whole or in part without the prior written permission of the originator.			
The originator shall have no responsibility for any liability, loss, cost, damage or expense arising from or relating to any use of this document other than for its intended purpose on this project.			
This drawing shall be read in conjunction with all other relevant drawings, specifications and associated documentation. Any discrepancies, errors or omissions are to be reported to the originator before proceeding with work.			
All dimensions are to be checked on site by the contractor prior to proceeding with any work.			
Hazard Identification			
ref	hazard	date	

T1	TENDER ISSUE	PAB	31.8.22
P3	PLAN 1978.37.303 P4 UPLOADED	PAB	18.7.22
P2	HARD STANDING REVISED	PAB	14.6.22
P1	OPTION 4 PLAN DATED 26.5.2022	PAB	30.5.22
ref	revision	by	date

Architects
Consulting Engineers
Quantity Surveyors

21 Silvenwell Street
Bolton
BL1 1PR
t: 01204 525321
email@bghbolton.co.uk
www.bghbolton.co.uk

Bradshaw Gass & Hope LLP

client	GREATER MANCHESTER FIRE AND RESUE SERVICE.		
project	LITTLEBOROUGH FIRE STATION EXTENSION AND REFURBISHMENT.		
drawing	PROPOSED SITE PLAN		
drawn by	PAB	date	MAY 22
checked by		date	
scale	1:200	A1	
dwg no	1978.37.201	rev	T1