
 

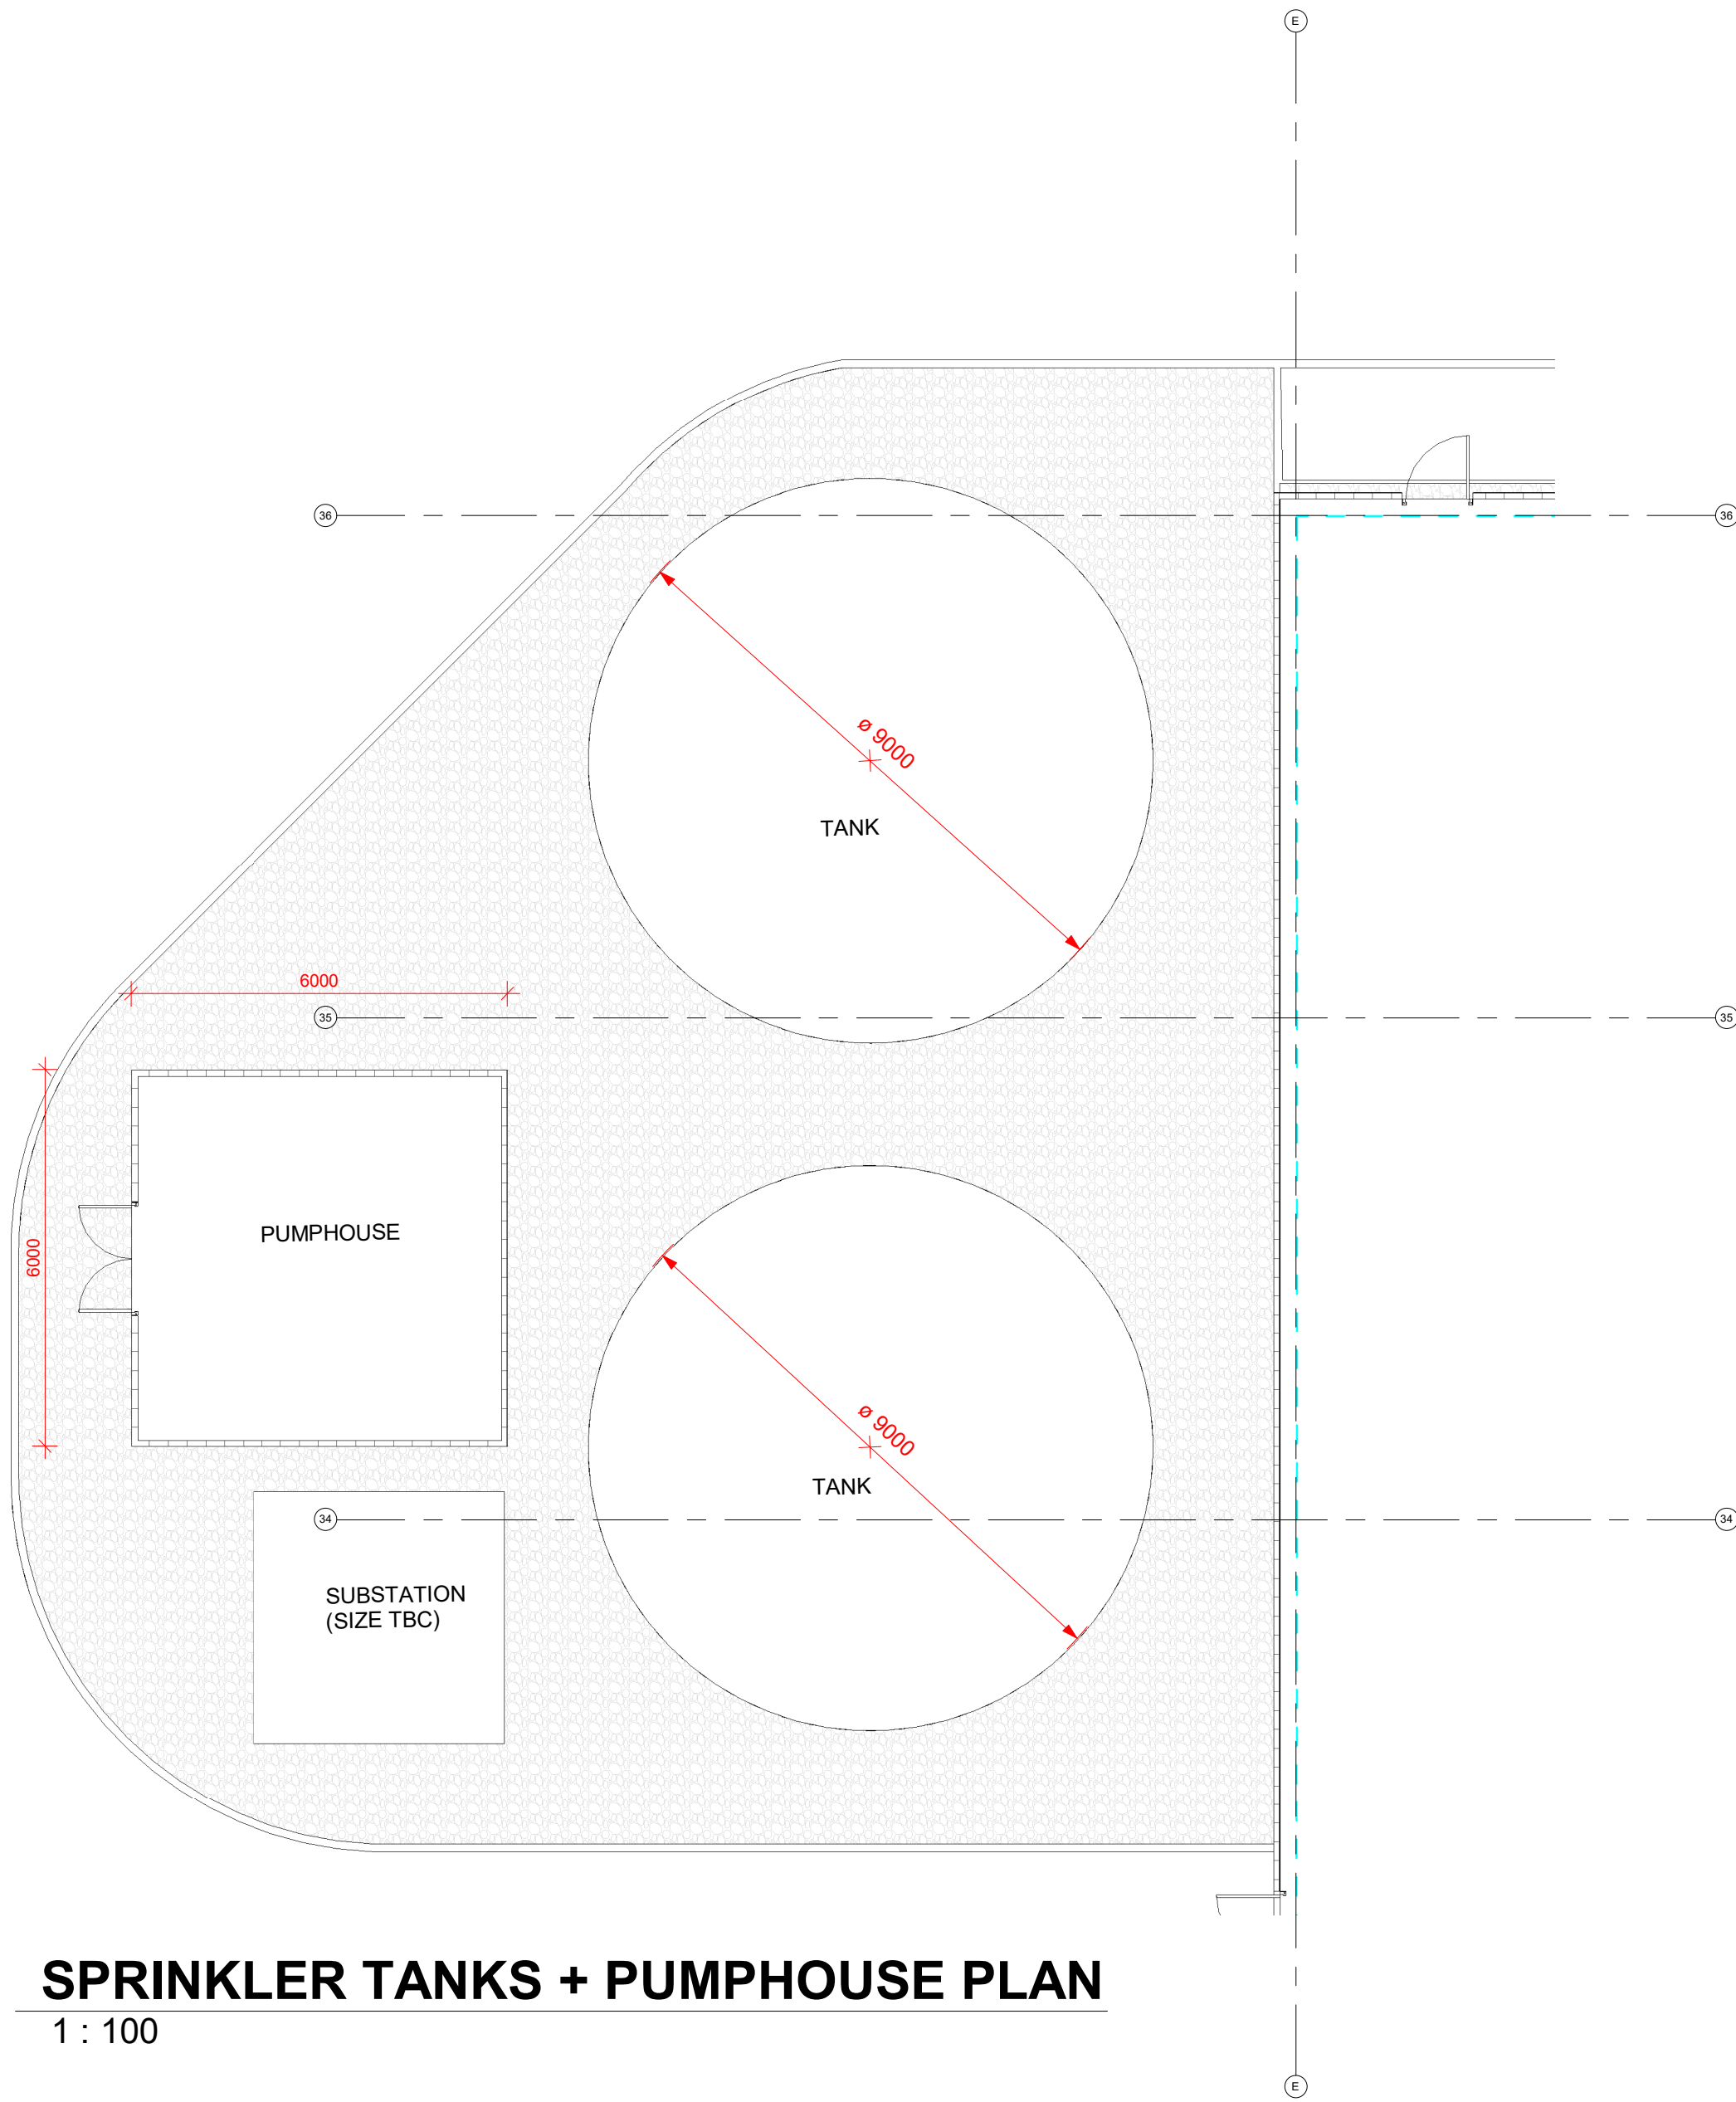



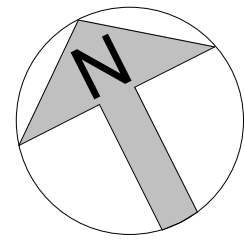


1 **SPRINKLER TANKS + PUMPHOUSE PLAN**
1 : 100

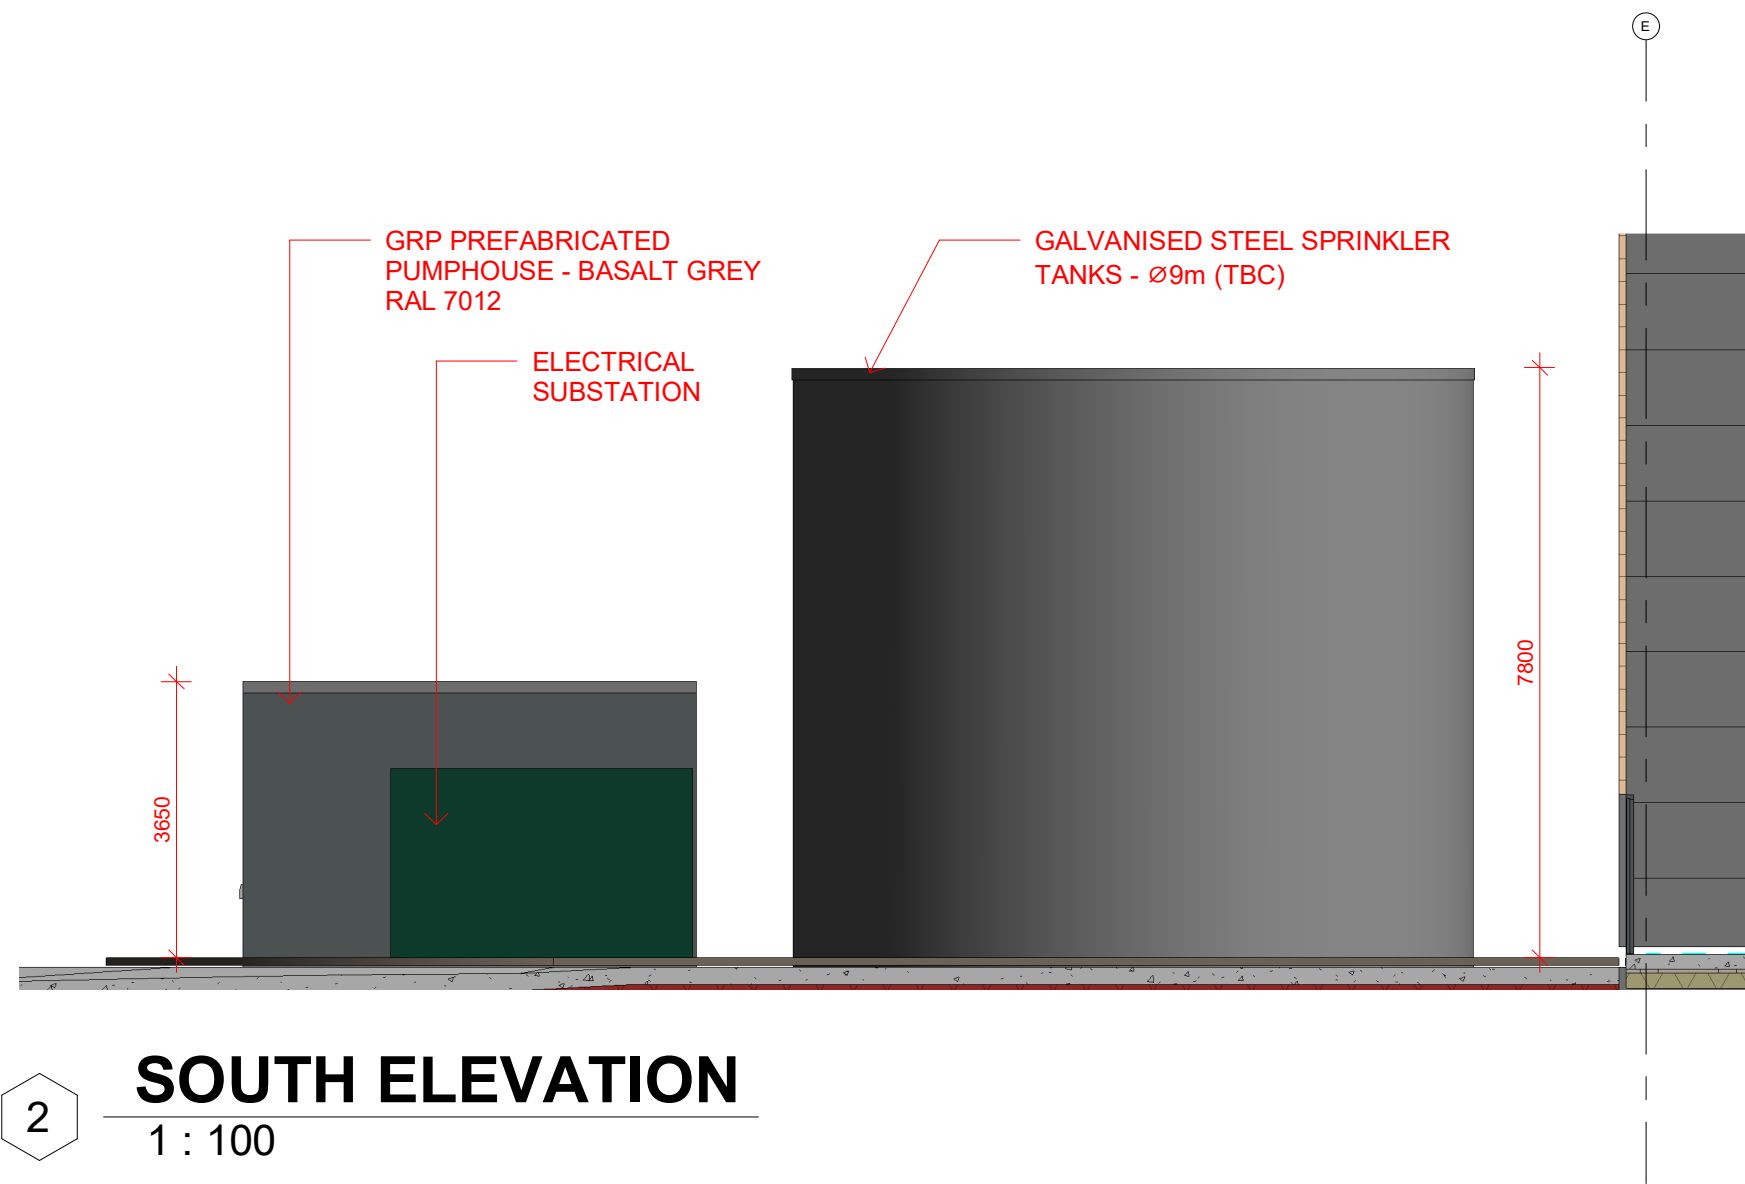


2 **SOUTH ELEVATION**
1 : 100

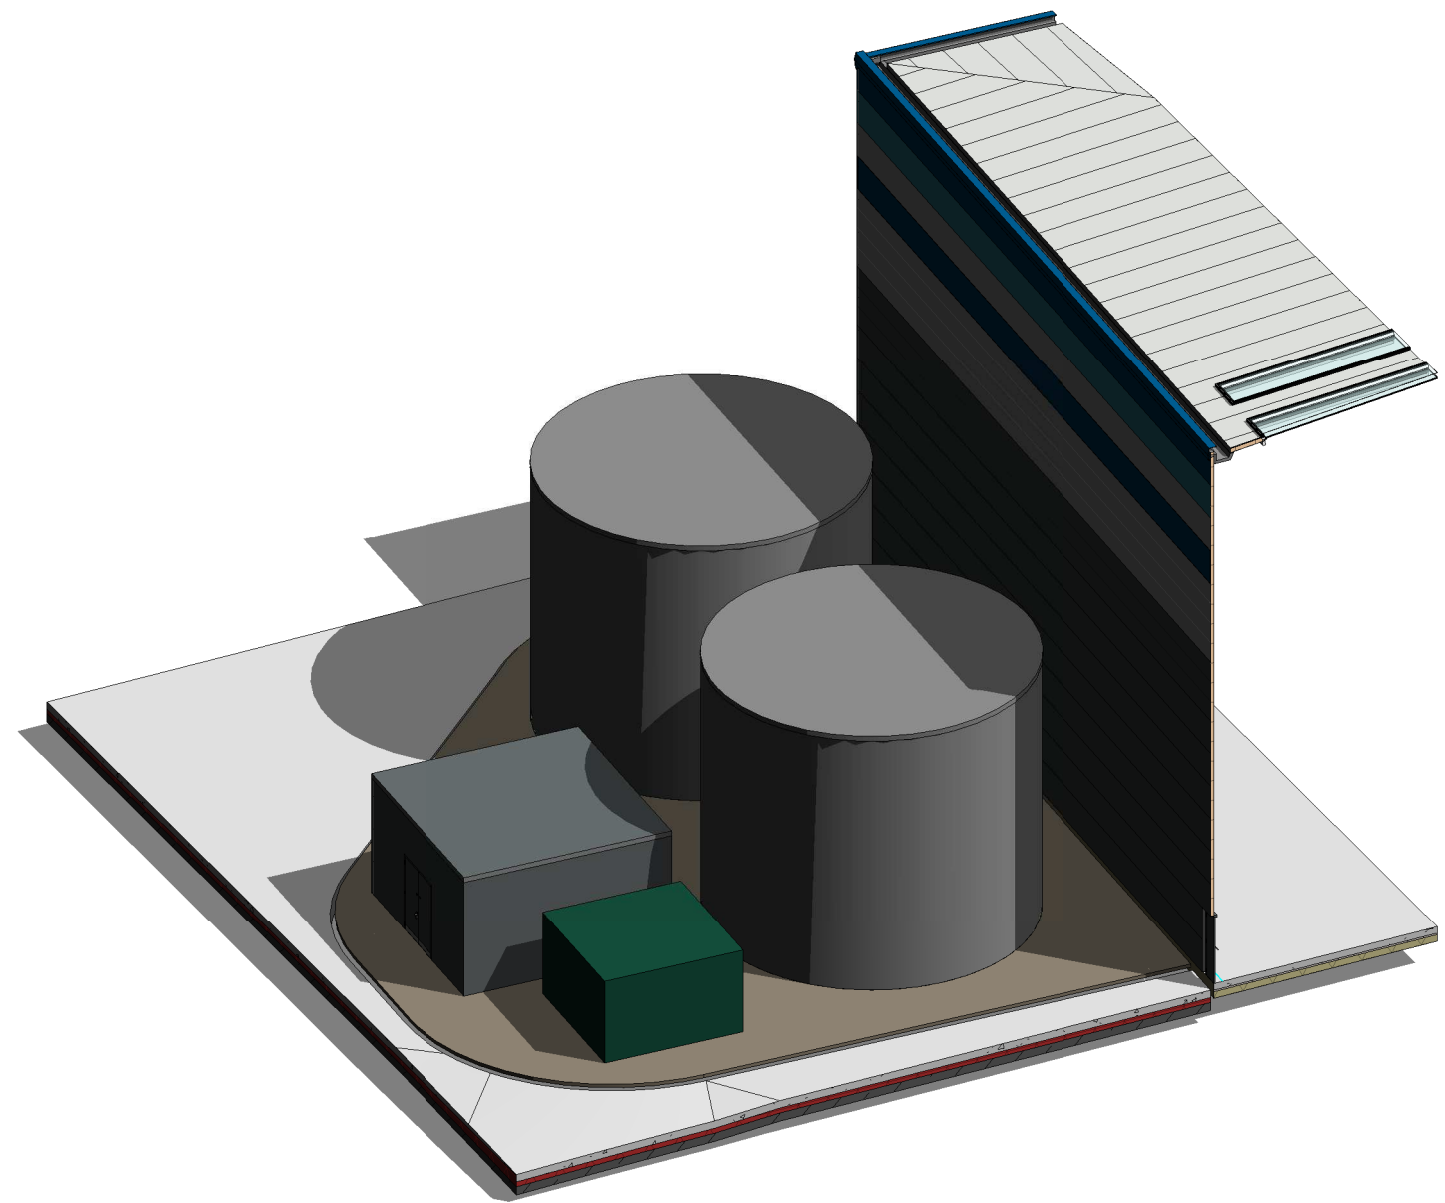

4 **3D VIEW**

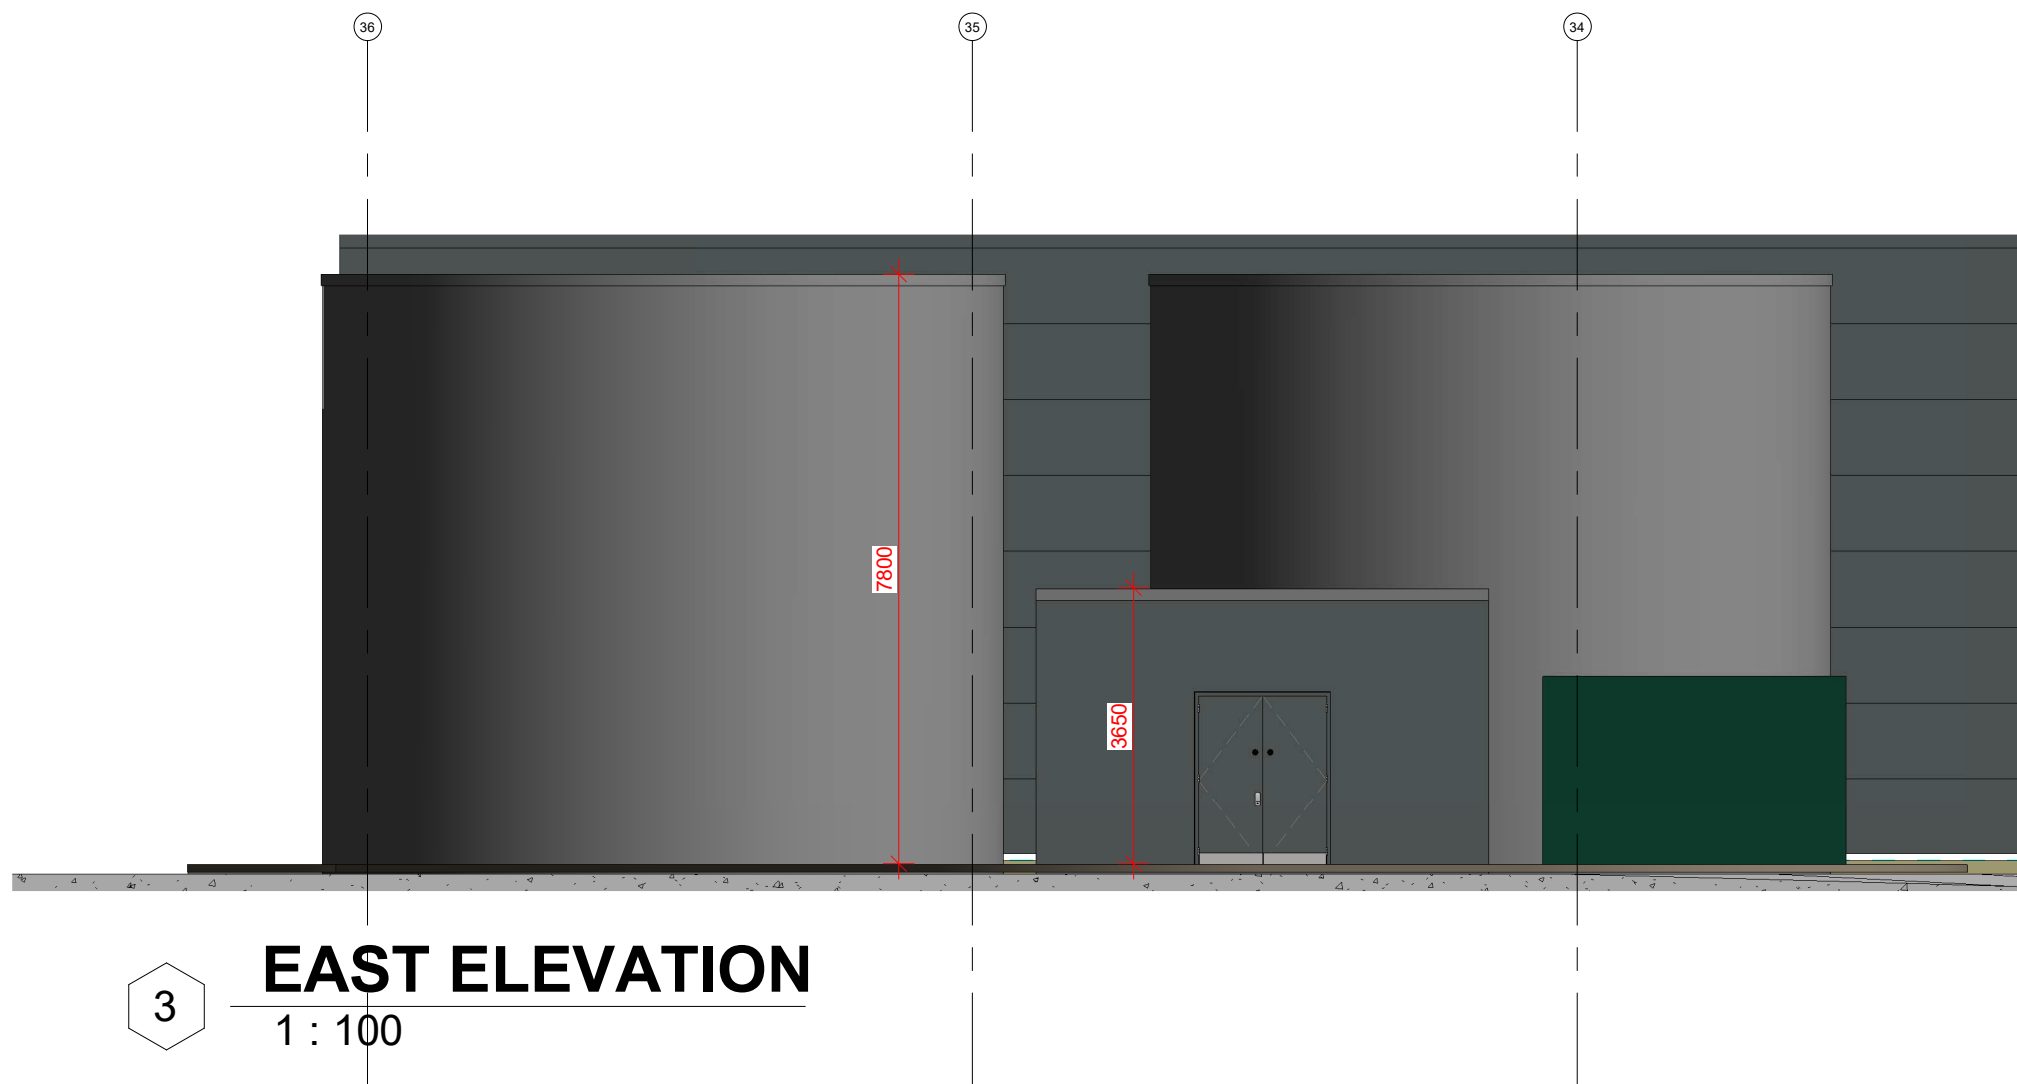

3 **EAST ELEVATION**
1 : 100

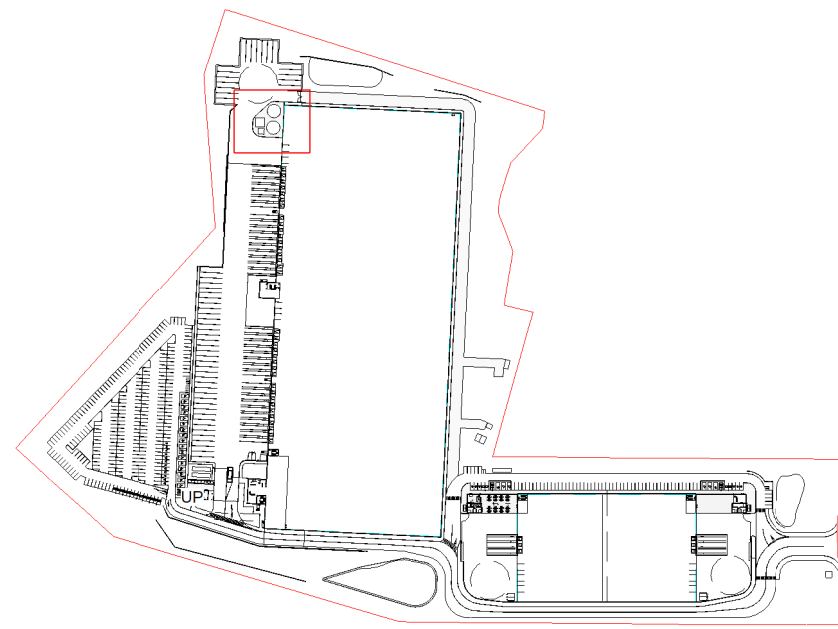

5 **LOCATION PLAN**
1 : 5000

Do not scale this drawing
ashton smith to be notified of discrepancies in figured dimensions
Contractors must check all dimensions from site
This drawing is copyright and is for use on this site only
This drawing is to be used solely for information as entitled
For other information refer to the latest revision of any cross referenced drawing



LOCATION PLAN:

NOTES:

REV	DATE	DESCRIPTION	DRAWN BY	CHECK BY
P2	06.06.23	Location Plan updated (South bund and ponds)	JA	RR
P1		Initial Drawing Issue	JA	RR

PROJECT TITLE MANCHESTER ROAD, HEYWOOD			
DRAWING TITLE PROPOSED SPRINKLER TANKS AND PUMPHOUSE UNIT 3			
RIBA STAGE	STATUS	DRAWN BY	CHECKED BY
P2	PLANNING	JA	RR
SHEET	SCALE	DATE	SUITABILITY
A1	As indicated	06/10/22	S3
DRAWING NO. 21157-ASA-00-EX.00-D-A-0029_(S3-P2)			
BIM MODEL NUMBER: 21157-ASA-ZZ-ZZ-M3-A-0001_(S3-P10)			

CLIENT Trammell Crow Company	
Ashton Smith Beyond Design	
Ashton Smith, Belvedere House, 2 Victoria Avenue, Harrogate, North Yorkshire, HG1 1EL Tel: 01423 522882 Fax: 01423 565104 www.ashtonsmith.co.uk	

JOB NO.
21157