




ABB CHARGE POST FOUNDATION PLAN
SCALE 1:50

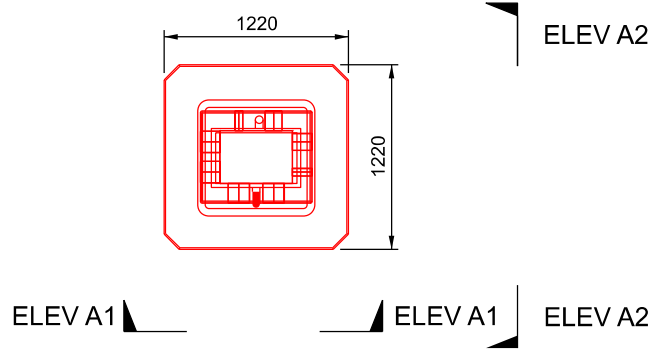


HP CABINET FOUNDATION PLAN
SCALE 1:50

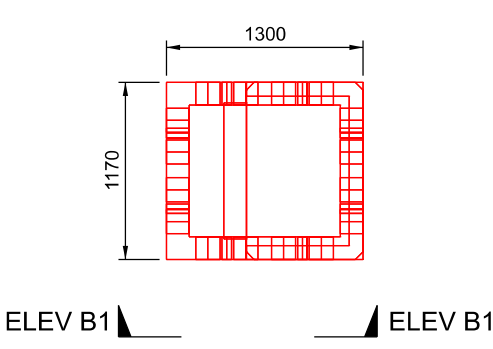


ALPITRONIC HYC 50 CHARGER FOUNDATION
SCALE 1:50

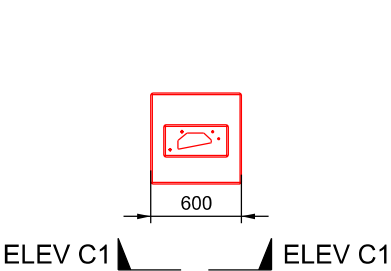


ELEVATION A1
SCALE 1:50

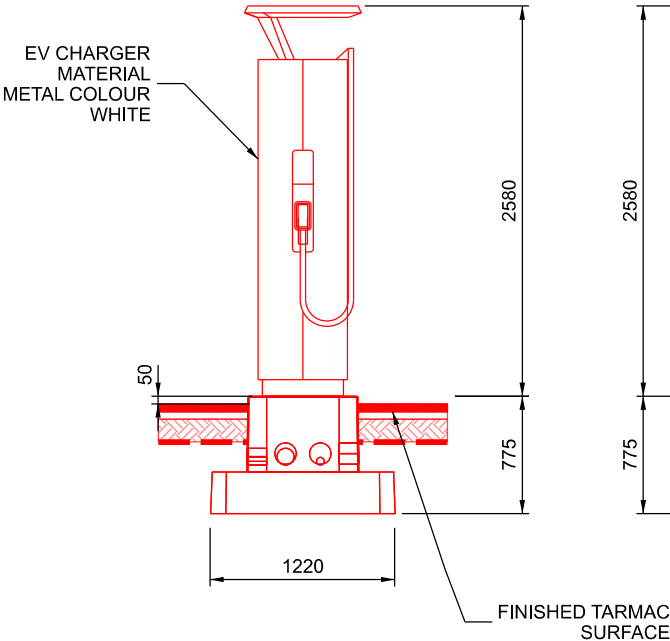


ELEVATION A2
SCALE 1:50

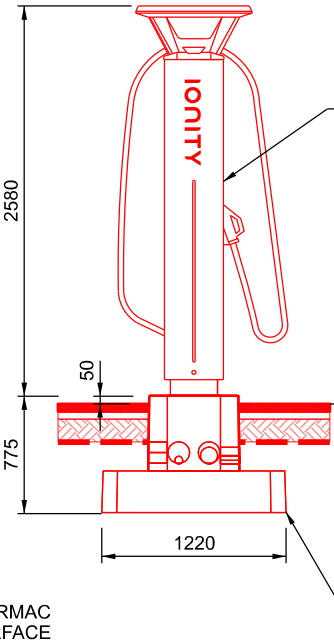


ELEVATION B1
SCALE 1:50

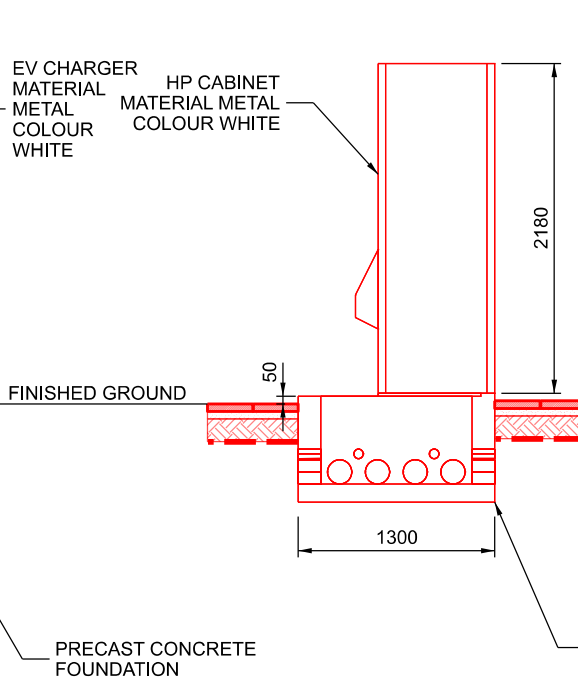


ELEVATION C1
SCALE 1:50

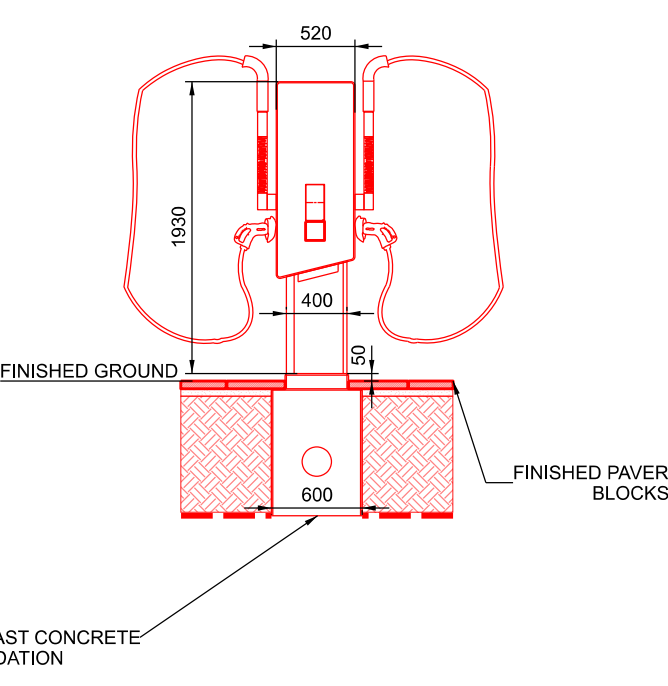



LV PANEL ELEVATION
SCALE 1:50

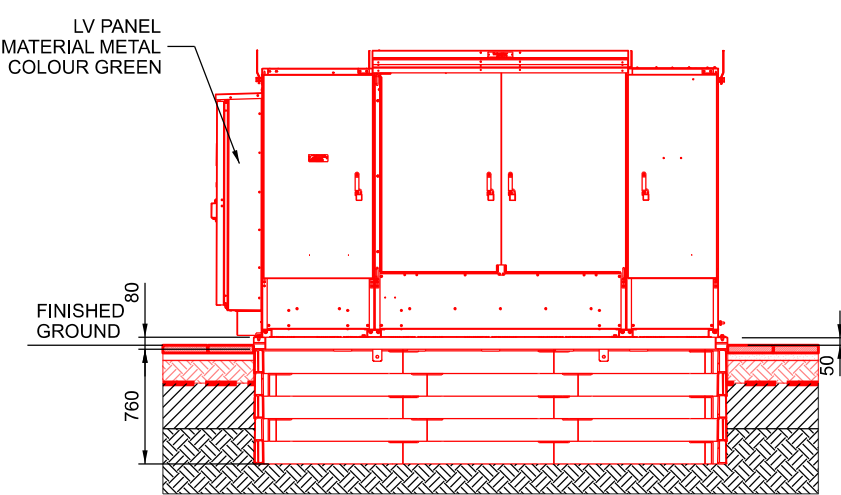

ALPITRONIC HYC 400 CHARGER FOUNDATION
SCALE 1:50

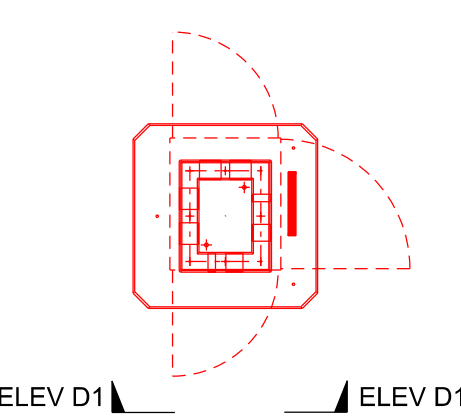

ELEVATION D1
SCALE 1:50

 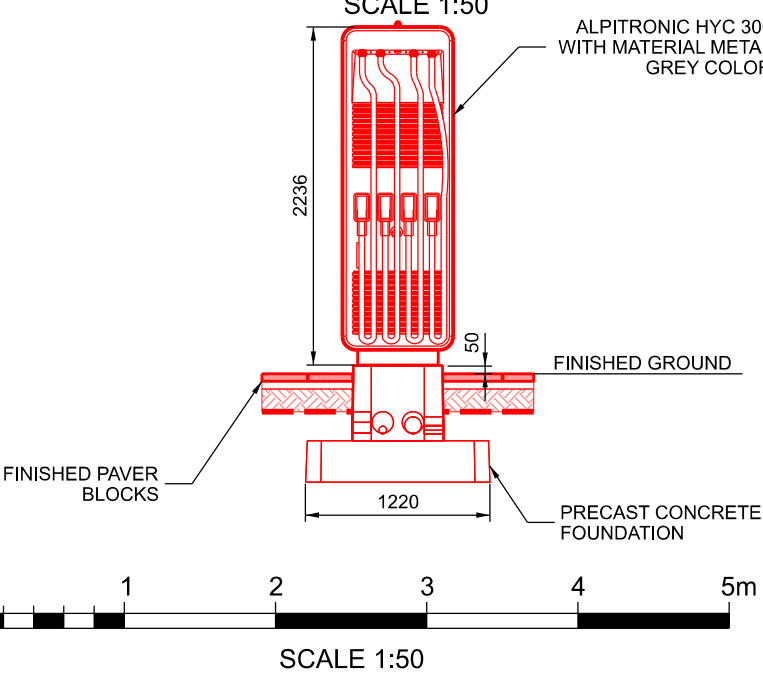

NOTES:

COLOUR CONVENTIONS				
BLACK	-	EXISTING OR UNCHANGED		
BLUE	-	MODIFIED OR TO BE MOVED		
GREEN	-	REDUNDANT OR TO BE REMOVED		
RED	-	PROPOSED OR ADDITIONAL		
PURPLE	-	WORKS BY OTHERS/FUTURE WORKS		

P01	10/11/23	ISSUED FOR REVIEW	ADI	Chk	App
Rev	Date	Description of Revisions	Drawn	Chkd	Appr

S0 - WORK IN PROGRESS



Poise Group Ltd
124 City Road
London
EC1V 2NX

Contractor(s)
IONITY
Ionity GmbH
Moosacher Strasse 84,
D-80809 Munich
Germany

Project
**IONITY
MANCHESTER BURY**

Drawing Title
**IONITY MANCHESTER BURY
ELECTRIC VEHICLE CHARGING
TYPICAL PLANNING DETAILS**

Designed	ADITYA	Signed		Date	08/11/23
Drawn	ADITYA	Signed		Date	08/11/23
Checked	Chk	Signed		Date	Date
Approved	App	Signed		Date	Date
Scale(s)		ELR & Mileage			
1:50		ELR&Mileage			
Alternative Reference					Sheet
-					01 of 01
Drawing Number					Revision
8312-POI-DRG-CIV-200016					P01