


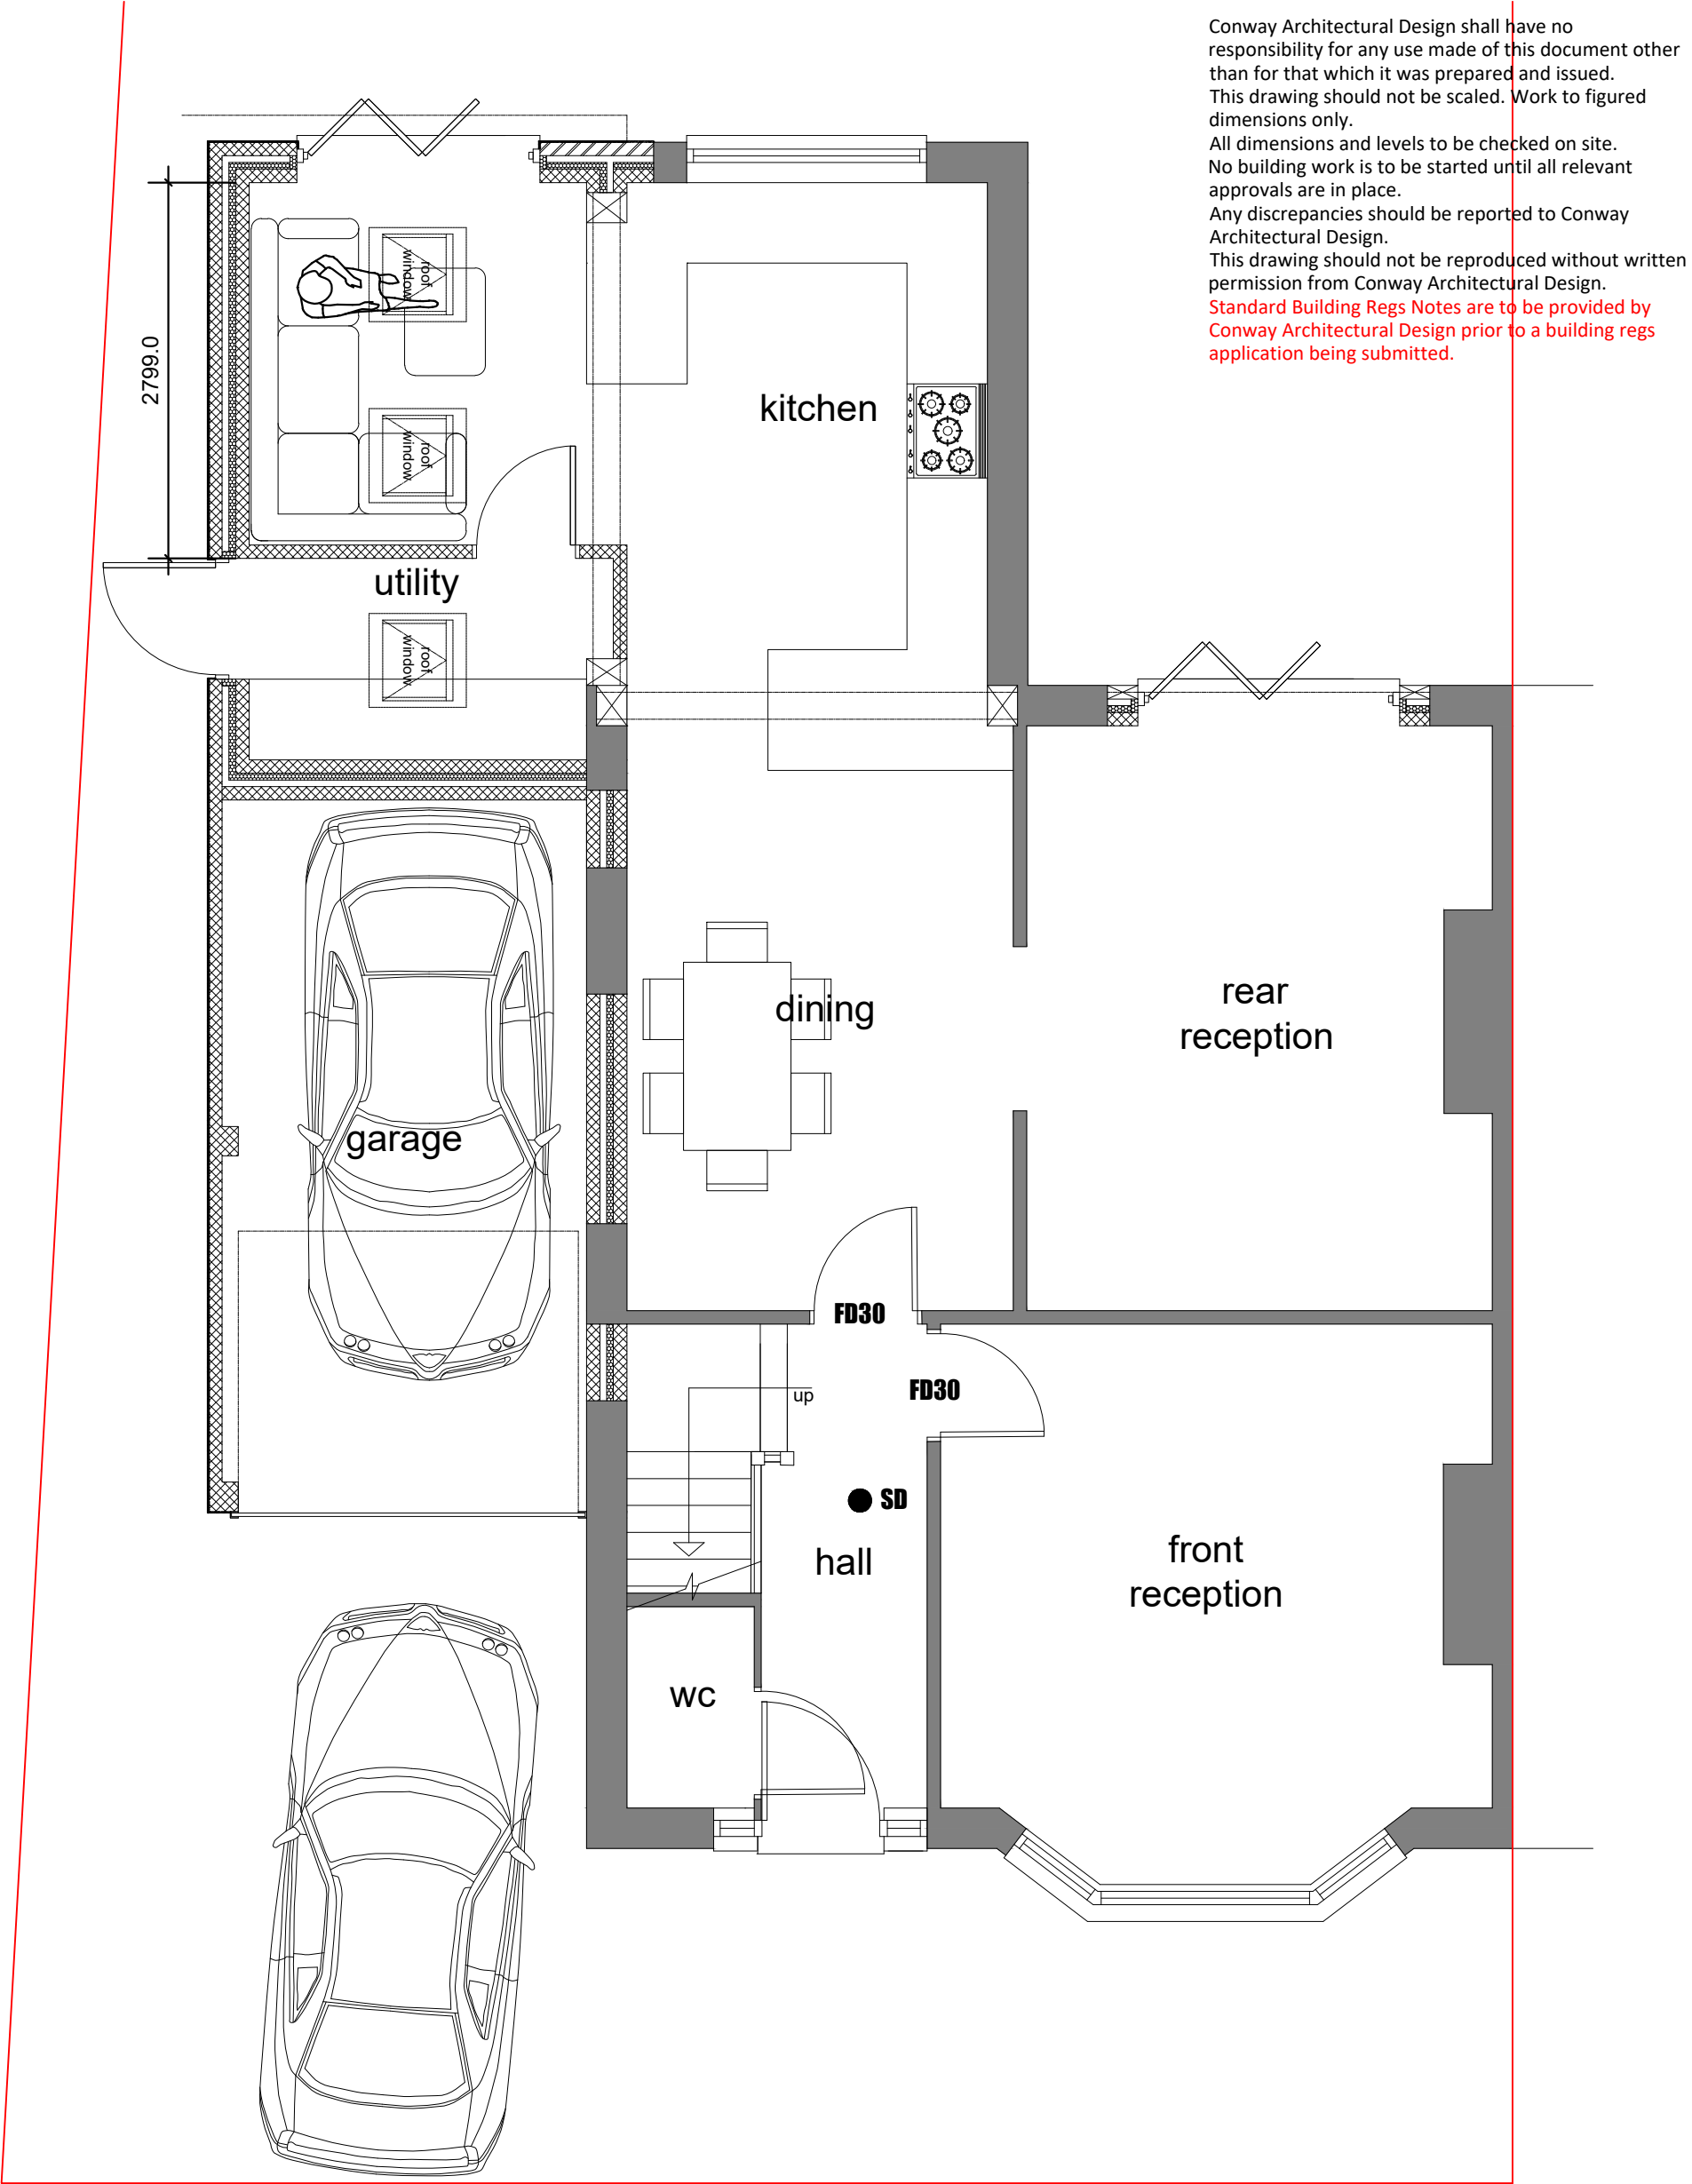

● **HD** Indicates heat detector.

● **SD** Indicates smoke detector.

FD30 30min fire door.



6 Conway Close
Alkrington
Middleton
Manchester, M24 1EW
E: conway-design@outlook.com

JOB TITLE : Dormer Loft Conversion
ADDRESS : 44 Mount Road, Alkrington
DRAWING TITLE : Proposed Ground Floor Plan
SCALE : 1:50 @ A3
DRAWN : xxx DATE : 24.03.25

JOB NO./ DWG NO. 665-07