


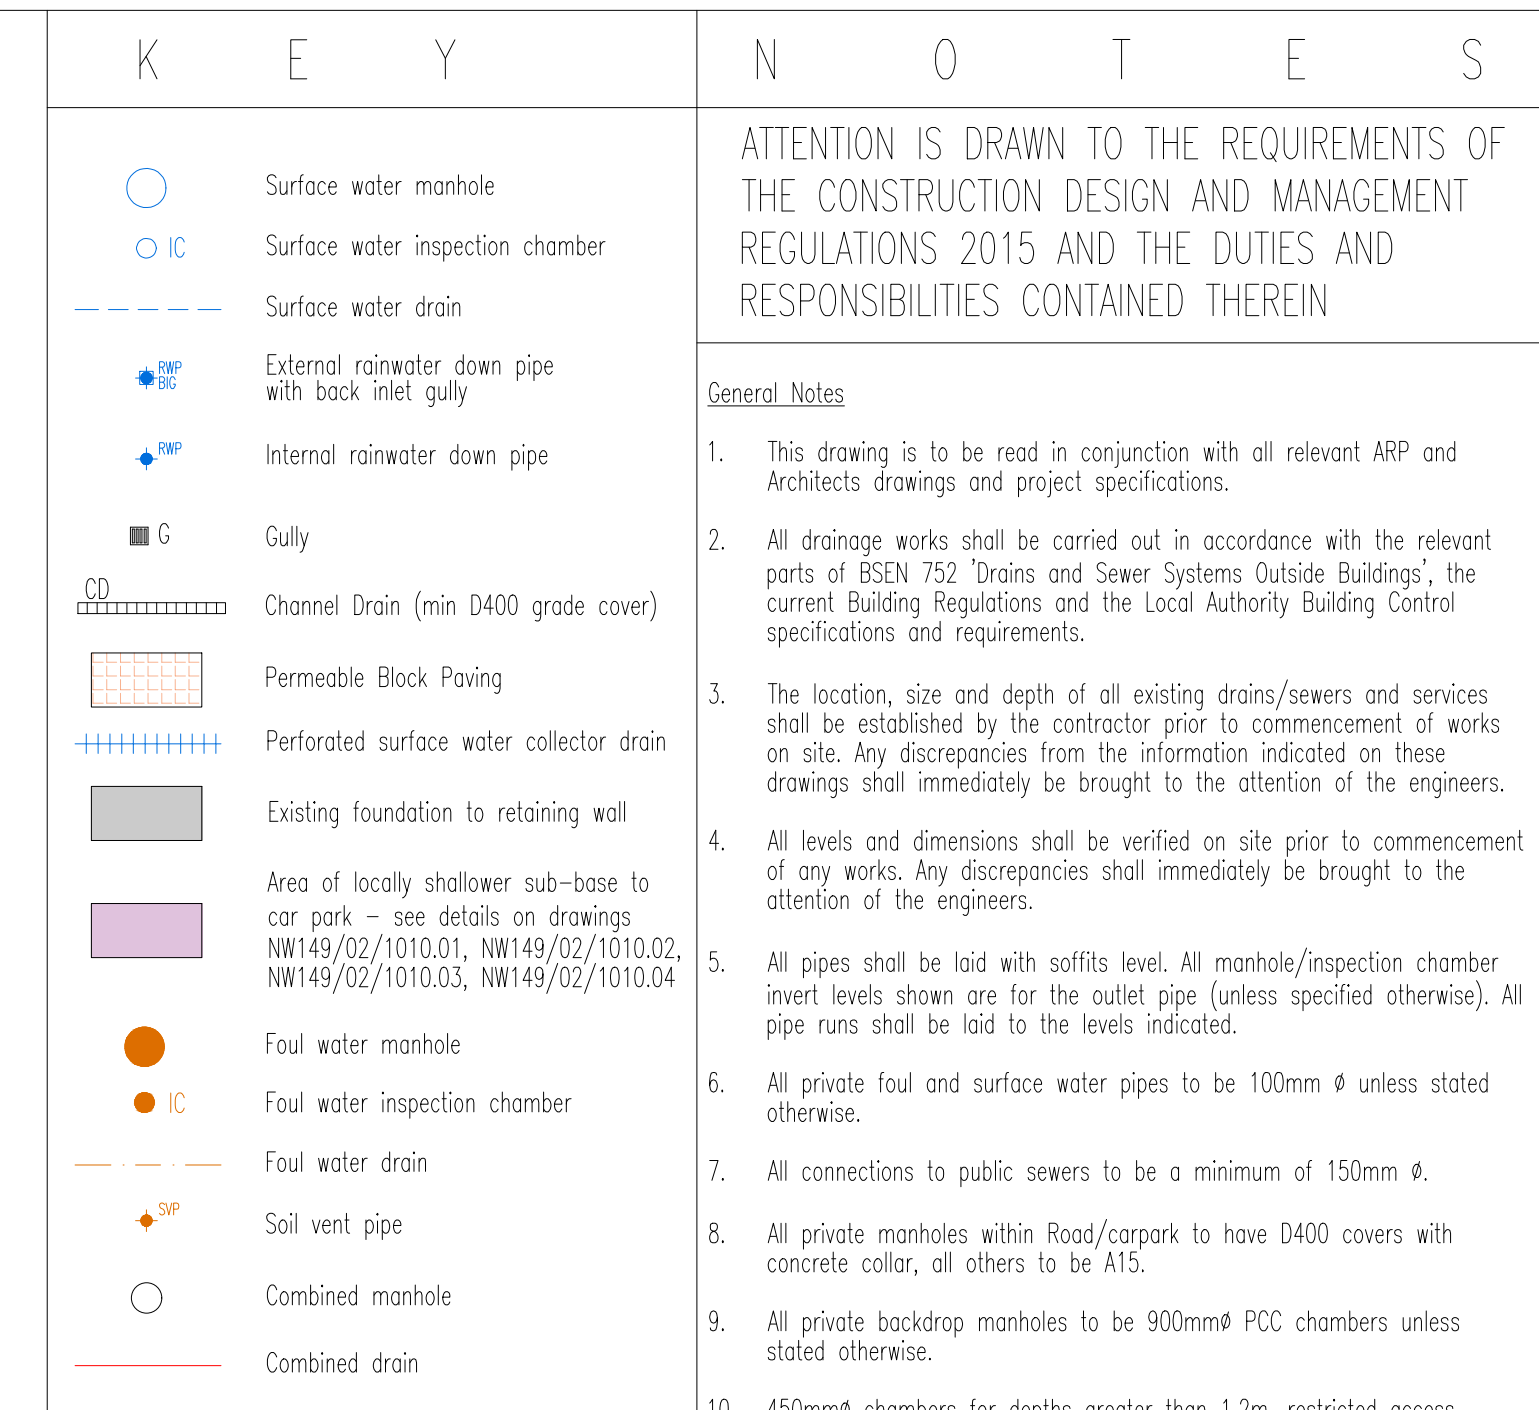

MANUFACTURER	HYDRO INTERNATIONAL
TELEPHONE	01275 878371
TYPE	Optimum
FLOW/HEAD	5.5 l/s 1.2m Head
HYDRO REF	CTL-SHE-0107-5500-1200-5500
To be installed in accordance with manufacturers specifications and recommendations before the manhole cover slab is installed	

K	MW	13.12.24	Revised for consistency with external works	MW	MI
J	MW	15.08.24	Ground floor plan updated	MW	MI
H	MW	23.04.24	Reissued for clarity	MW	MI
G	MW	04.03.24	General updates	MW	MI
F	MW	12.02.24	Architect's site Plan updated	MW	MI
E	MW	26.04.23	General updates	MW	MI
D	MW	18.01.22	Minor amendments for consistency	MW	MI
C	AT	06.12.21	Architects layout updated	MW	MI
B	AT	05.07.21	Architects layout B, RWP, SVP & extg MH	MW	MI
A	AT	01.06.21	Permeable parking boys amended	MW	MI
/	AT	03.05.21	Issued for approval		
Rev	By	Date	Revision	Chk	Appd

ARP ARP ASSOCIATES
Chartered Consulting Engineers

Northwest House • 5 & 6 Northwest Business Park • Servia Hill, Leeds • LS6 2QH
T 0113 245 8498 (R) 0113 244 3864 • leeds@arpassociates.co.uk • www.arpassociates.co.uk

ARP Associates is a trading division of ARP Geotechnical Ltd, a company registered in England and Wales with company number 3771811, whose registered office is at 5/6 Northwest Business Park, Servia Hill, Leeds LS6 2QH

TITLE			
PRIVATE DRAINAGE LAYOUT			
PROJECT			
SMITHYBRIDGE PUB LITTLEBOROUGH			
CLIENT			
ARMSTRONG PROJECTS LTD			
DRAWING STATUS			
CONSTRUCTION			
Scale	Date	Drawn	AT
1:125 @ A1	MAY 21	Chk.	MW
Drg. No. NW149-02-03			Rev K