


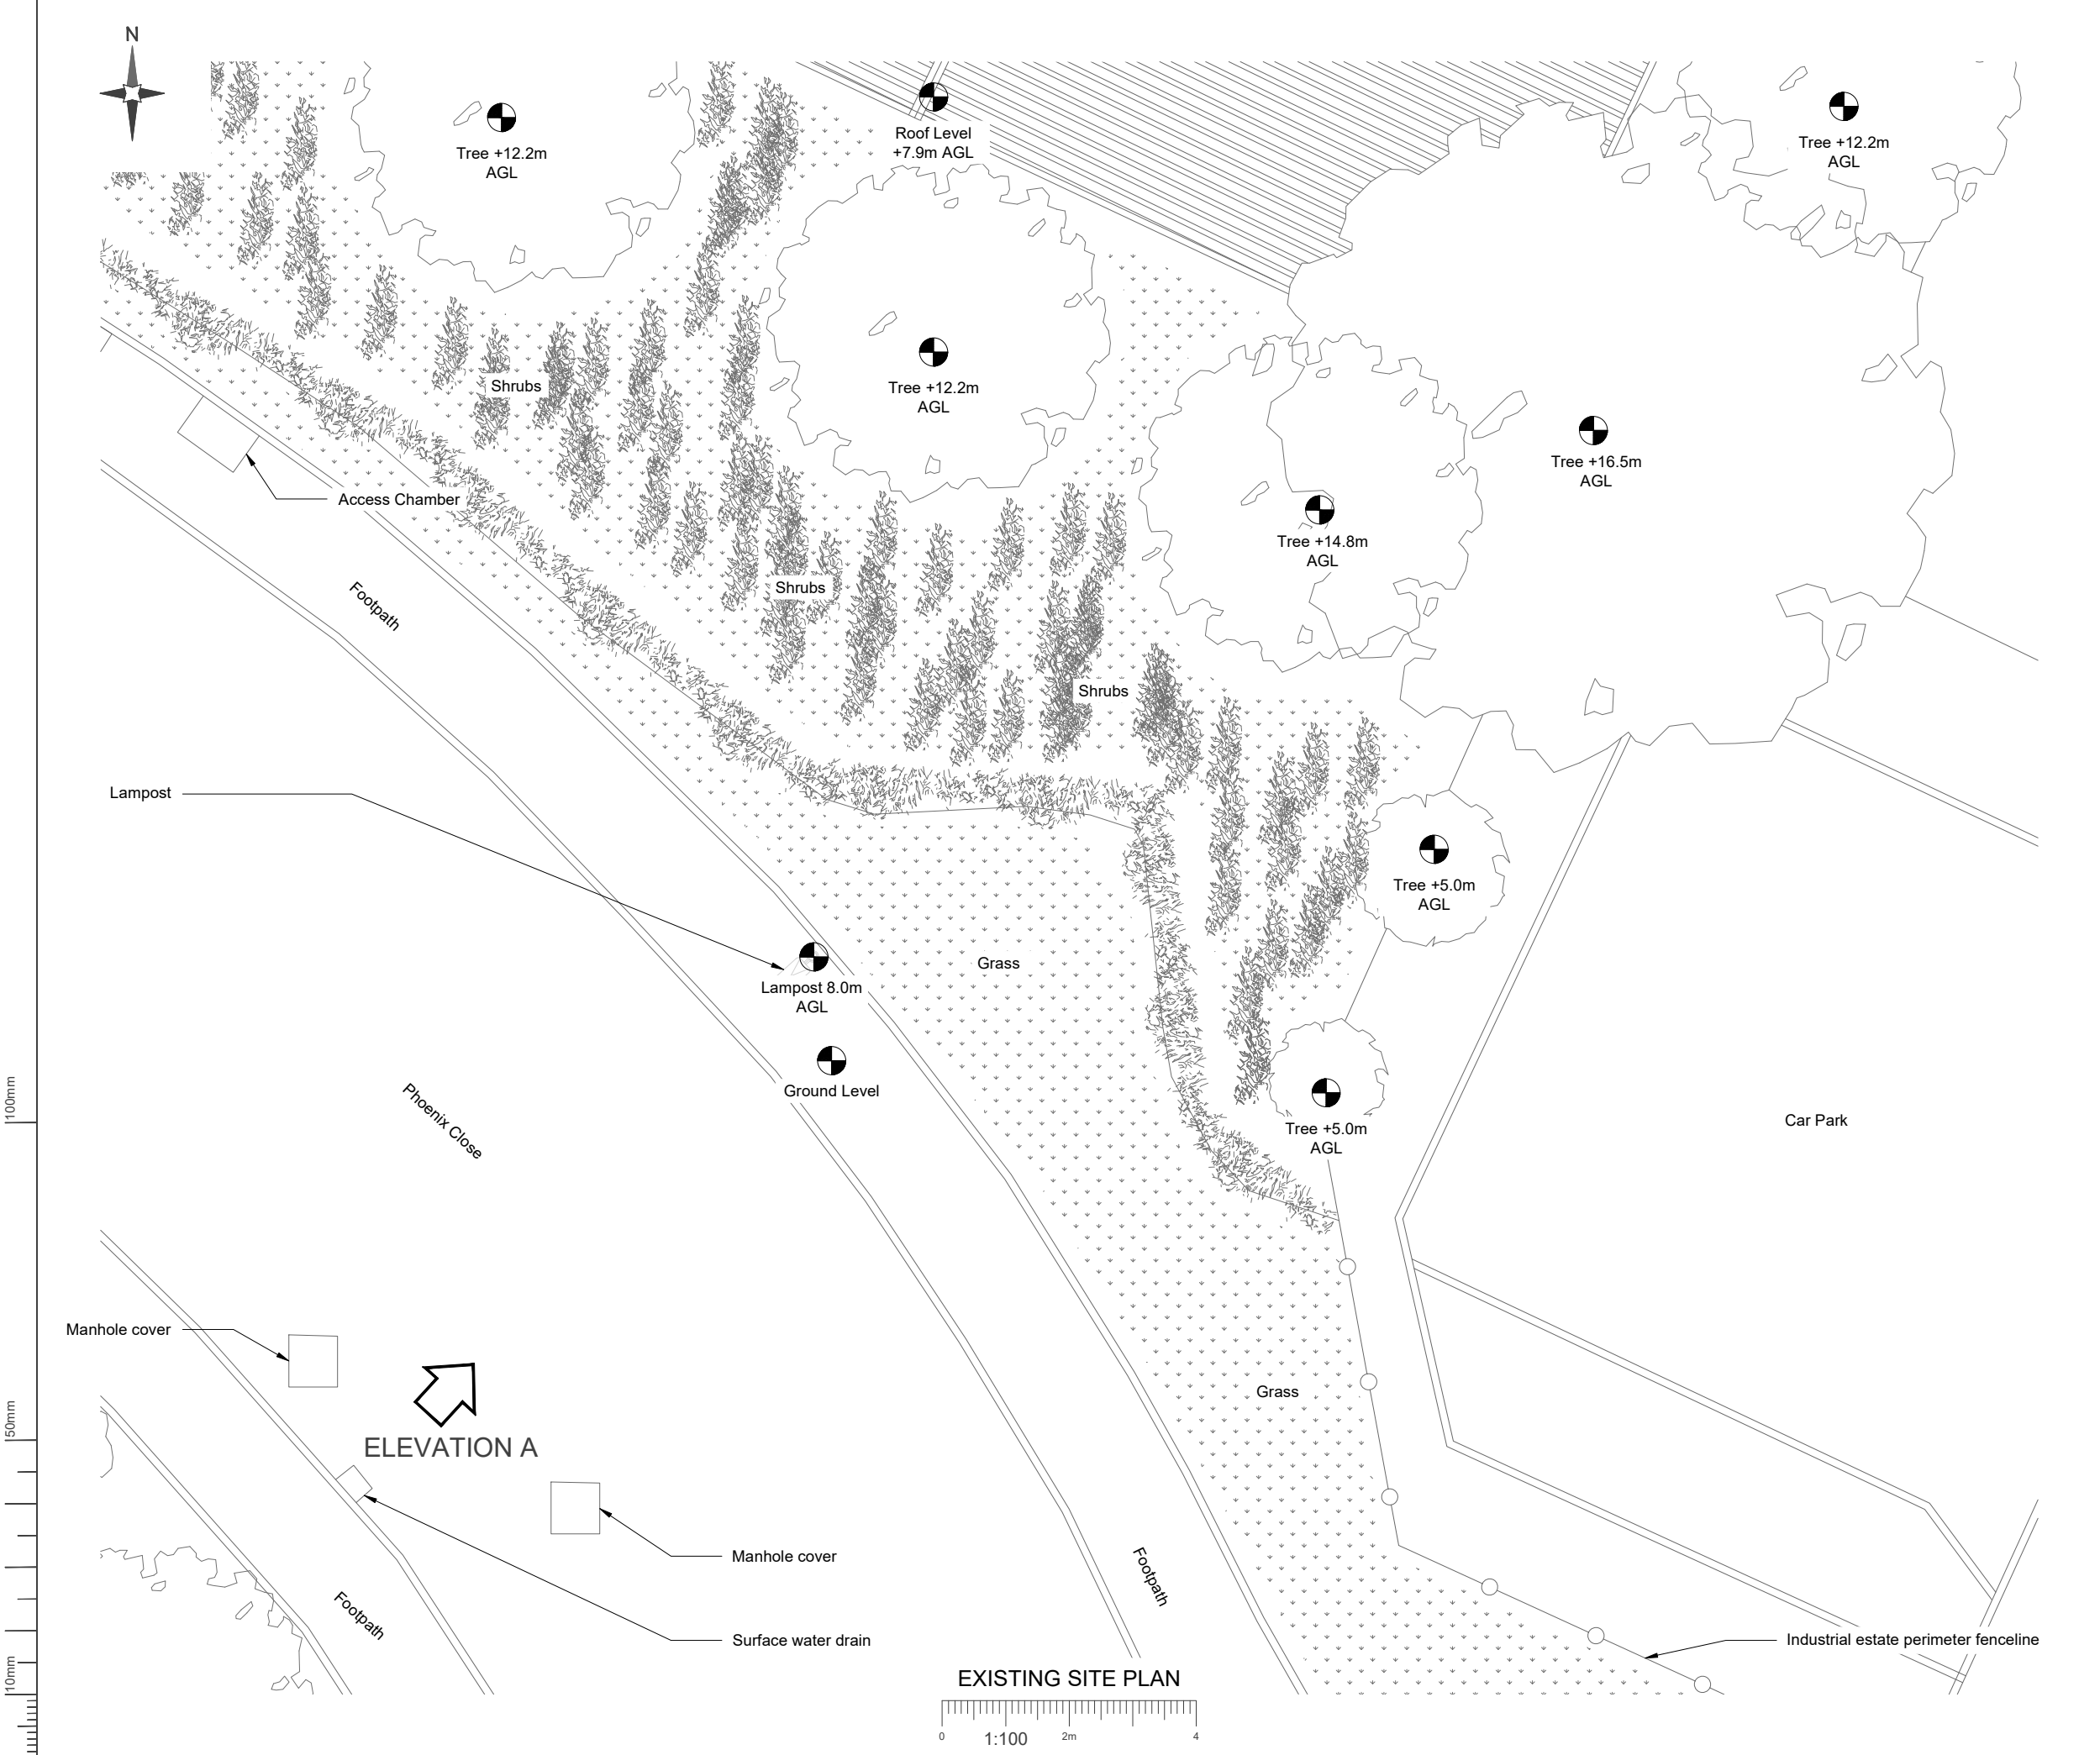

NOTES:

1. ALL DIMENSIONS IN MM UNLESS OTHERWISE NOTED.

Master:	Project:	Purpose of Issue:	Issue:
M001	MBNL NTQR	GA Drawings	A
Date:	04/03/2025	Revision / Upgrade Description:	
Drawn:	J.Halloran	GA Drawings - First Issue	
Checked:	T.Clifford		
Approved:	M.Venner		



Hutchison 3G UK Limited
Green Park, 450 Longwater Avenue
Reading, RG30 3UR
Tel: 01628 785 000
Fax: 01628 785 001
H3G Base Station Information line:
0845 6043000
Available 8am-8pm Monday to Friday



Everything Everywhere
One Braham Street
London
E1 6EE
Tel: 020 7356 5000



Mobile Broadband Network Limited
Sixth Floor, Thames Tower, Station Road, Reading, RG1 1LX


Design Consultant:



BEACONCOMMS

UNIT E3 PITTS CLEAVE INDUSTRIAL ESTATE, TAVISTOCK, DEVON, PL19 0PW
sales@beaconcomms.co.uk
Tel: +44 (0)1822 610610

Site Name:	PHOENIX CLOSE		
Site ID:	1738951		
Address:	PHOENIX CLOSE HOPWOOD, HEYWOOD GREATER MANCHESTER OL10 2JG		
Title:	100 EXISTING SITE PLAN		
Project:	MBNL NTQR		
Purpose of Issue:	GENERAL ARRANGEMENT		
EE Cell ID:	MBNL Cell ID:	H3G Cell ID:	
33519	ROD200	OL1024	
File name:			
ROD200_33519_OL1024_MBNL_NTQR_GA_A			

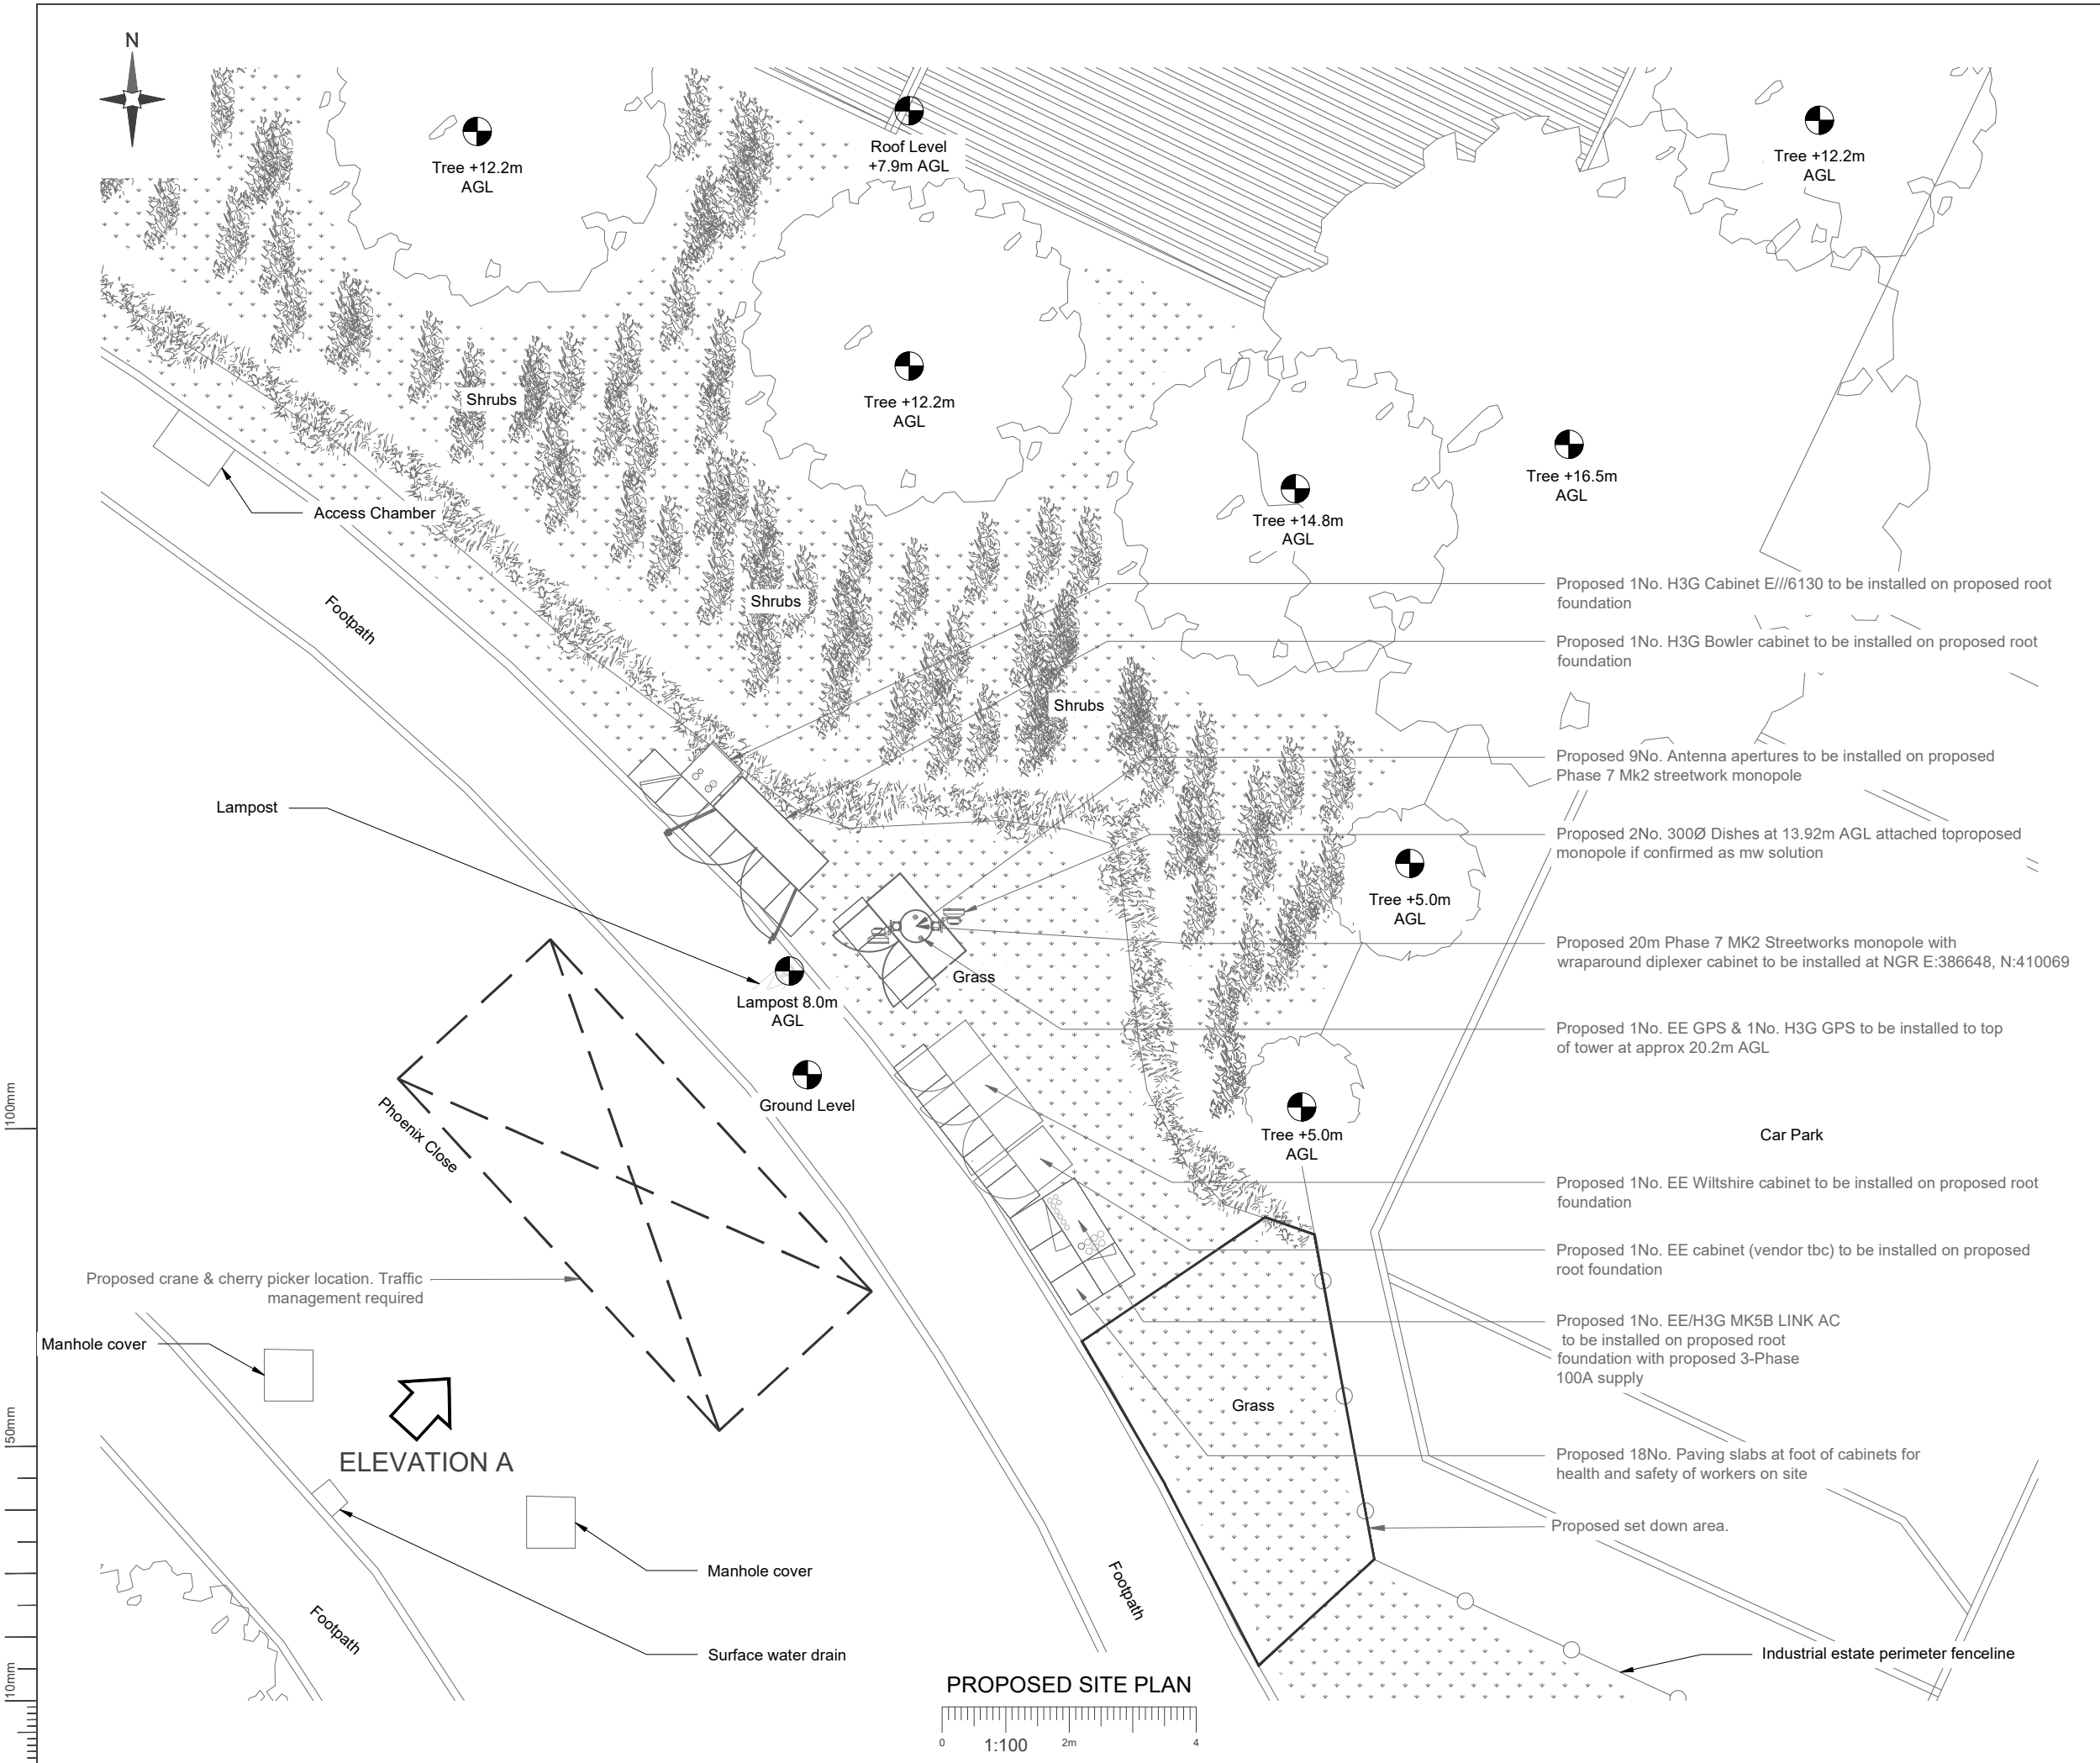

NOTES:

1. ALL DIMENSIONS IN MM UNLESS OTHERWISE NOTED.

Master:	Project:	Purpose of Issue:	Issue:
M001	MBNL NTQR	GA Drawings	A
Date:	04/03/2025	Revision / Upgrade Description:	
Drawn:	J.Halloran	GA Drawings - First Issue	
Checked:	T.Clifford		
Approved:	M.Venner		



Hutchison 3G UK Limited
Green Park, 450 Longwater Avenue
Reading, RG30 3UR
Tel: 01628 785 000
Fax: 01628 785 001

H3G Base Station Information line:
0845 6043000
Available 8am-8pm Monday to Friday



Everything Everywhere
One Braham Street
London
E1 6EE
Tel: 020 7356 5000



Mobile Broadband Network Limited
Sixth Floor, Thames Tower, Station Road, Reading, RG1 1LX

Design Consultant:



BEACONCOMMS

UNIT E3 PITTS CLEAVE INDUSTRIAL ESTATE, TAVISTOCK, DEVON, PL19 0PW
sales@beaconcomms.co.uk Tel: +44 (0)1822 610610

Site Name: PHOENIX CLOSE

Site ID: 1738951

Address: PHOENIX CLOSE
HOPWOOD,
HEYWOOD
GREATER MANCHESTER
OL10 2JG

Title: 150 PROPOSED SITE PLAN

Project: MBNL NTQR

Purpose of Issue: GENERAL ARRANGEMENT


EE Cell ID:	MBNL Cell ID:	H3G Cell ID:
33519	ROD200	OL1024

File name: ROD200_33519_OL1024_MBNL_NTQR_GA_A

100mm
50mm
10mm



 EXISTING SITE ELEVATION A



- NOTES:
1. ALL DIMENSIONS IN MM UNLESS OTHERWISE NOTED.

Master:	Project:		Purpose of Issue:	Issue:
M001	MBNL NTQR		GA Drawings	A
Date:	04/03/2025	Revision / Upgrade Description:		
Drawn:	J.Halloran	GA Drawings - First Issue		
Checked:	T.Clifford			
Approved:	M.Venner			



Hutchison 3G UK Limited
Green Park, 450 Longwater Avenue
Reading, RG30 3UR
Tel: 01628 765 000
Fax: 01628 765 001

H3G Base Station Information line:
0845 6043000
Available 8am-8pm Monday to Friday



Everything Everywhere
One Braham Street
London
E1 8EE

Tel: 020 7356 5000



Mobile Broadband Network Limited
Sixth Floor, Thames Tower, Station Road, Reading, RG1 1LX

Design Consultant:



BEACONCOMMS

UNIT E3 PITTS CLEAVE INDUSTRIAL ESTATE, TAVISTOCK, DEVON, PL19 0PW
sales@beaconcomms.co.uk
Tel: +44 (0)1822 610610

Site Name: PHOENIX CLOSE

Site ID: 1738951

Address: PHOENIX CLOSE
HOPWOOD,
HEYWOOD
GREATER MANCHESTER
OL10 2JG


Title: 200 EXISTING SITE ELEVATION

Project: MBNL NTQR

Purpose of Issue: GENERAL ARRANGEMENT

EE Cell ID:	MBNL Cell ID:	H3G Cell ID:
33519	ROD200	OL1024

File name: ROD200_33519_OL1024_MBNL_NTQR_GA_A

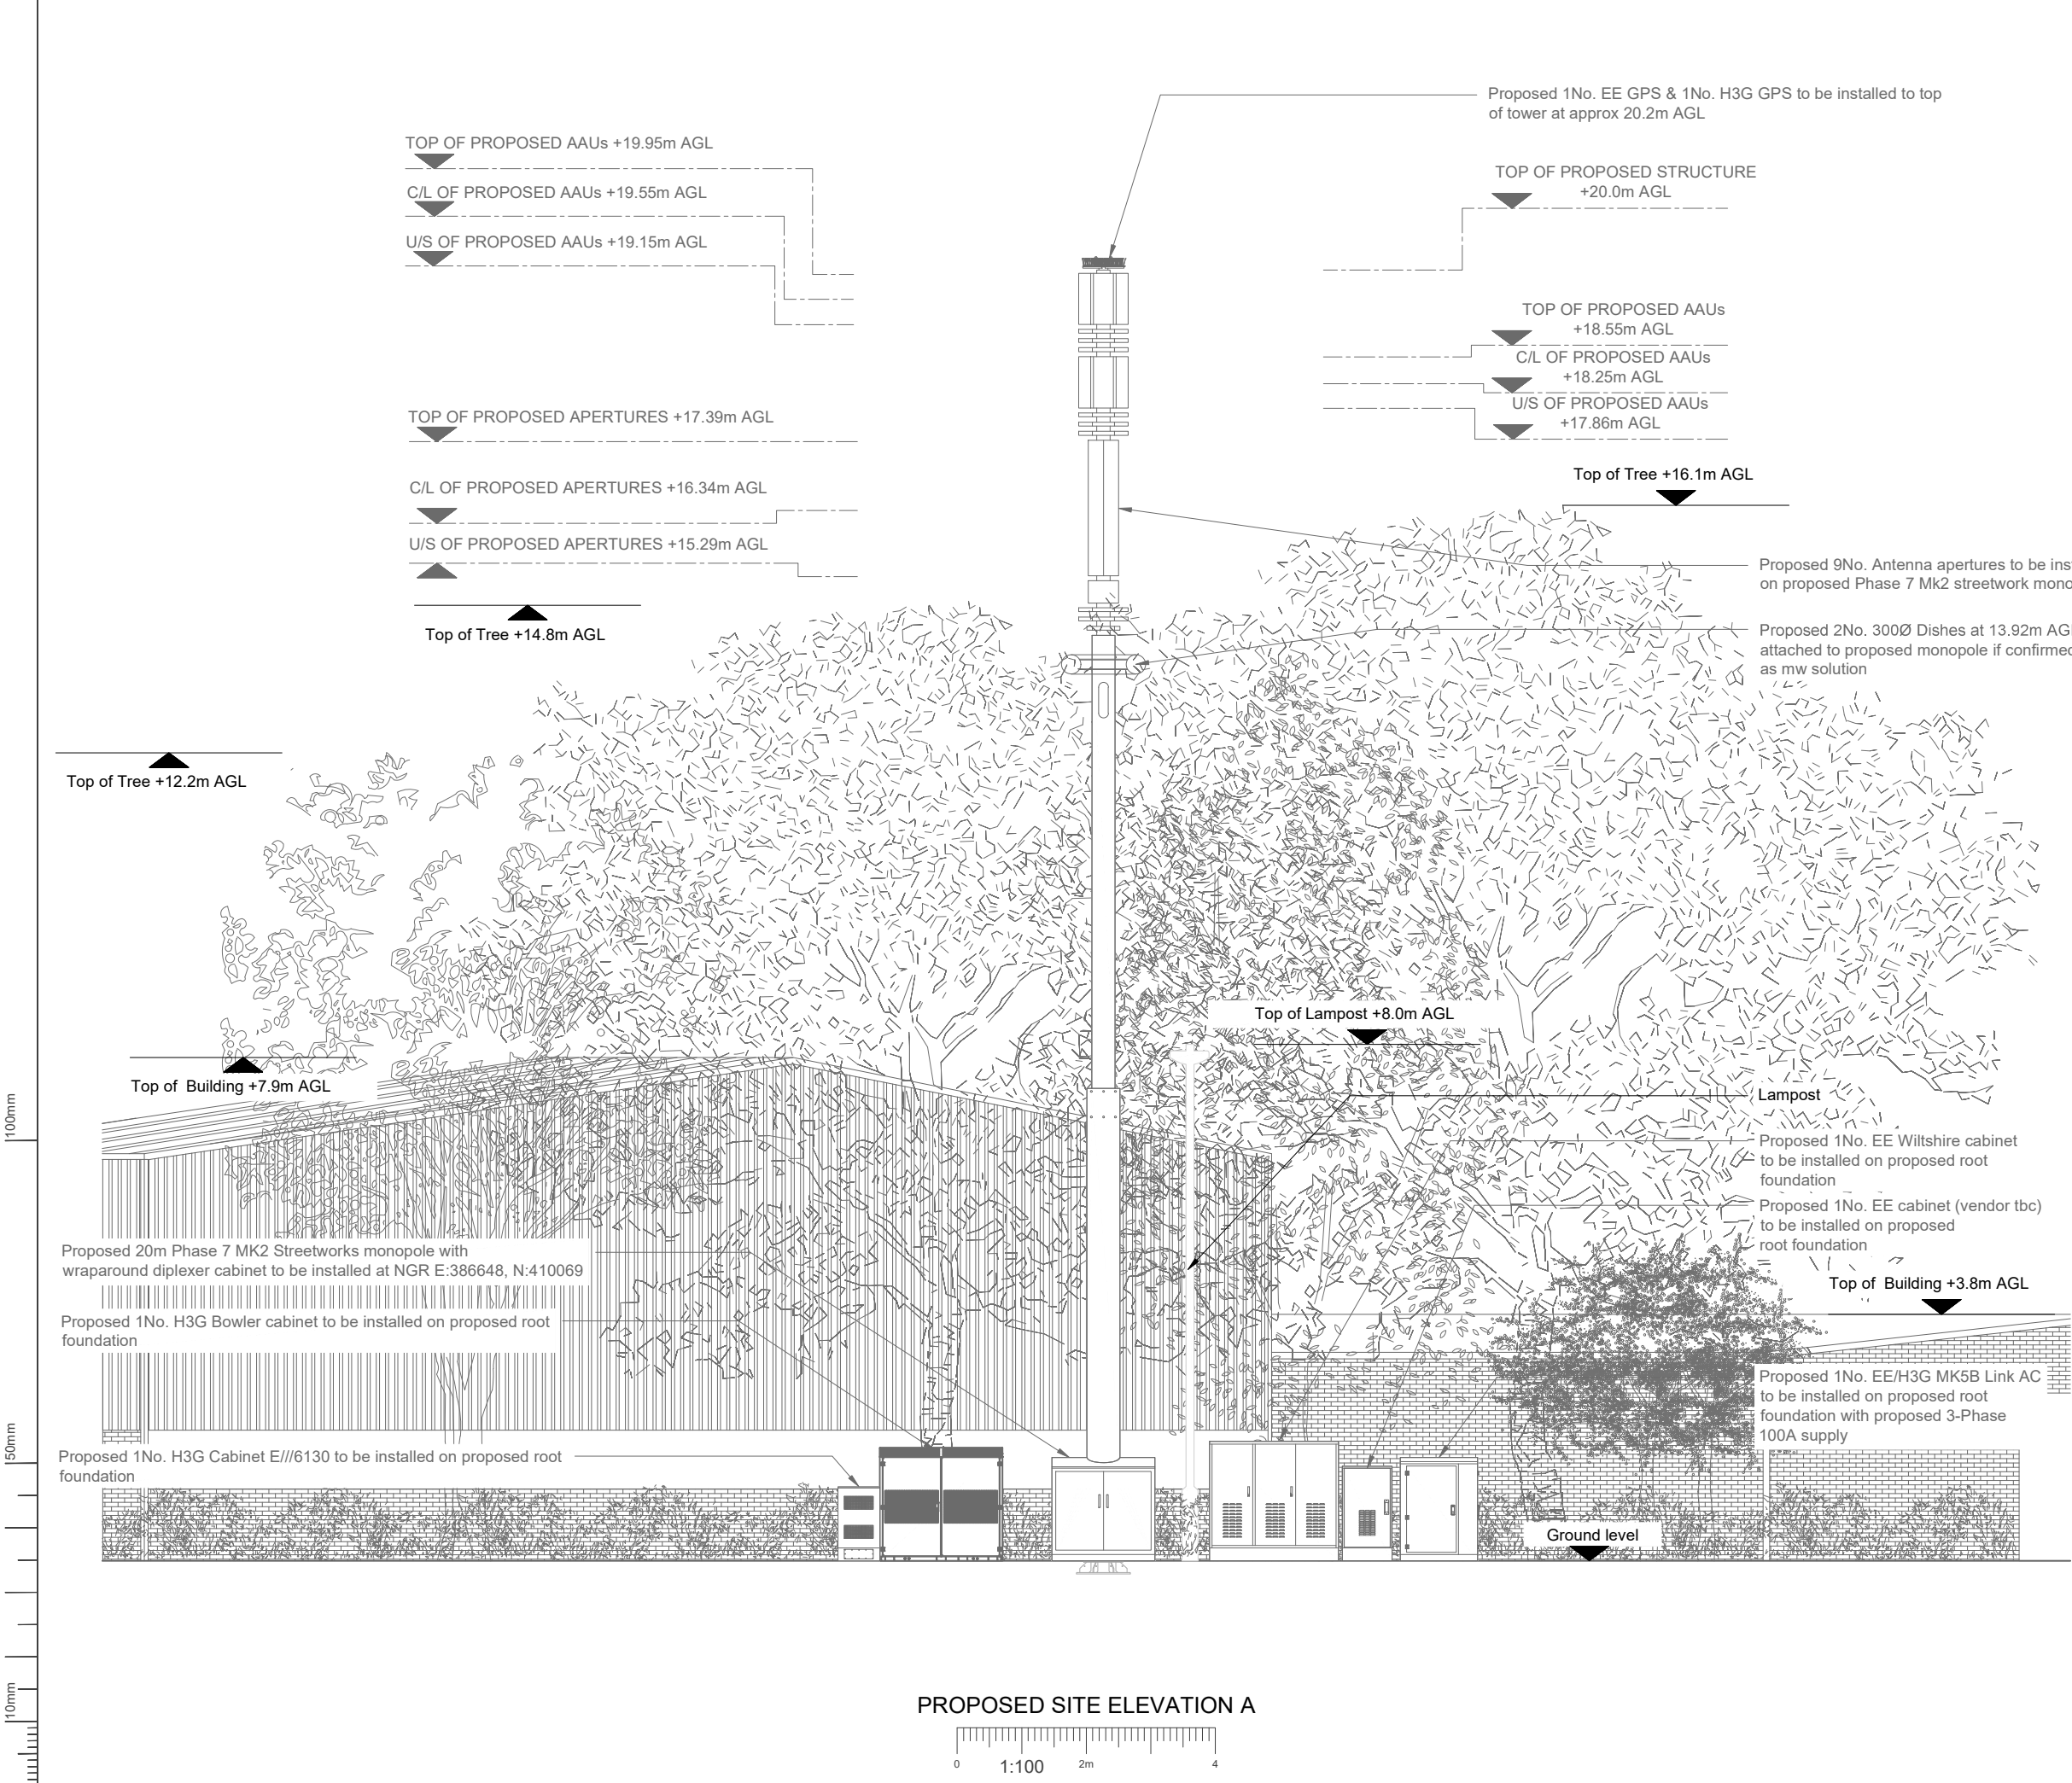

NOTES:

1. ALL DIMENSIONS IN MM UNLESS OTHERWISE NOTED.

Master:	Project:	Purpose of Issue:	Issue:
M001	MBNL NTQR	GA Drawings	A
Date:	04/03/2025	Revision / Upgrade Description:	
Drawn:	J.Halloran	GA Drawings - First Issue	
Checked:	T.Clifford		
Approved:	M.Venner		



Hutchison 3G UK Limited
Green Park, 450 Longwater Avenue
Reading, RG30 3UR
Tel: 01628 765 000
Fax: 01628 765 001

H3G Base Station Information line:
0845 6043000
Available 8am-8pm Monday to Friday



Everything Everywhere
One Braham Street
London
E1 8EE
Tel: 020 7356 5000



Mobile Broadband Network Limited
Sixth Floor, Thames Tower, Station Road, Reading, RG1 1LX

Design Consultant:



BEACONCOMMS

UNIT E3 PITTS CLEAVE INDUSTRIAL ESTATE, TAVISTOCK, DEVON, PL19 0PW
sales@beaconcomms.co.uk Tel: +44 (0)1822 610610

Site Name: PHOENIX CLOSE

Site ID: 1738951

Address: PHOENIX CLOSE
HOPWOOD,
HEYWOOD
GREATER MANCHESTER
OL10 2JG

Title: 250 PROPOSED SITE ELEVATION

Project: MBNL NTQR

Purpose of Issue: GENERAL ARRANGEMENT

EE Cell ID:	MBNL Cell ID:	H3G Cell ID:
33519	ROD200	OL1024

File name: ROD200_33519_OL1024_MBNL_NTQR_GA_A