


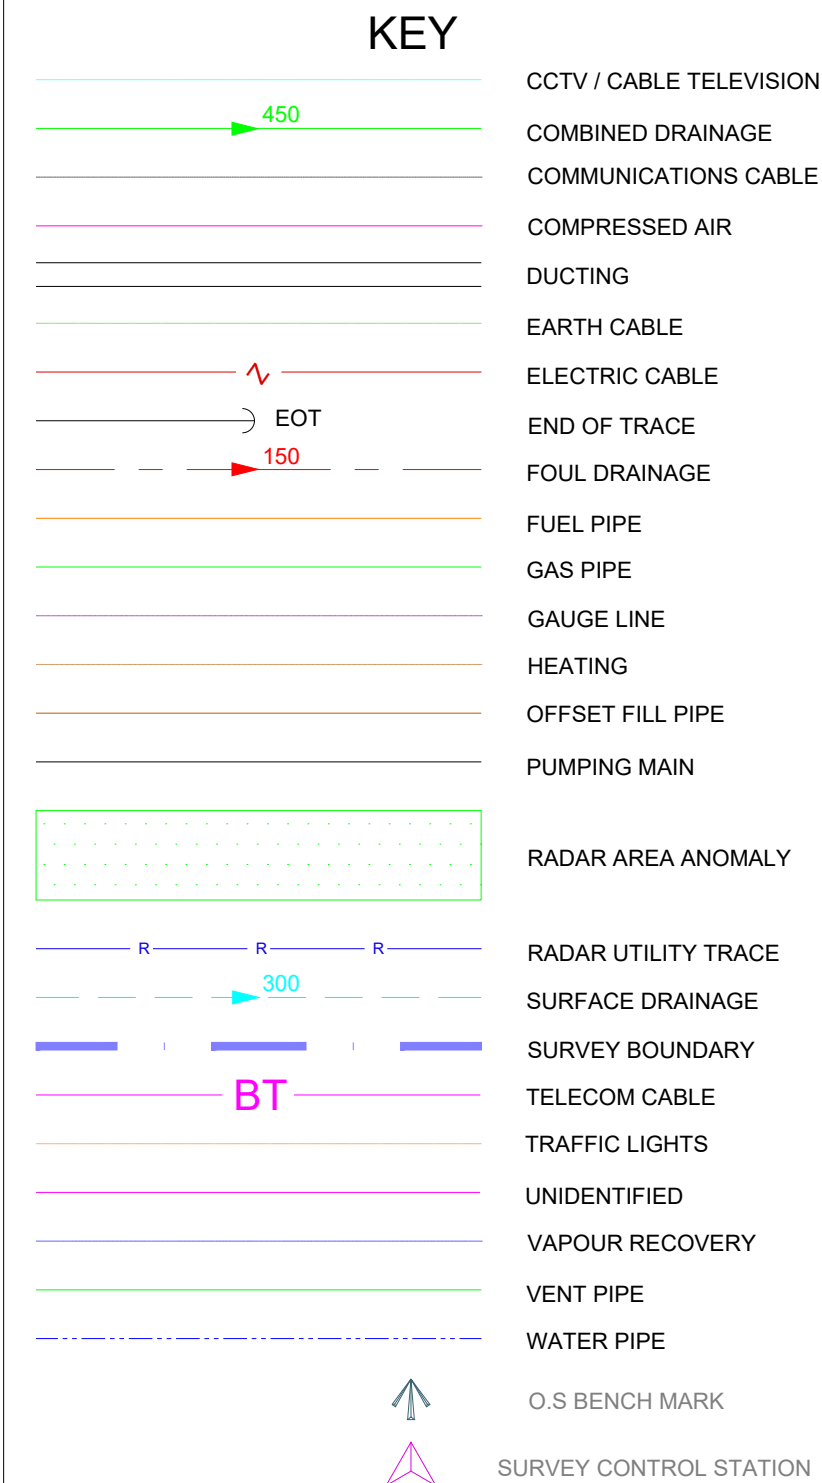

ELECTRICAL LEGEND

(All ductwork will be Black Rigiduct)
 Refer to ENVEVO design details for trench design

— 225Ø — 225Ø —	225mm Ø Electrical Duct
— 150Ø — 150Ø —	150mm Ø Electrical Duct
— 100Ø — 100Ø —	100mm Ø Electrical Duct
— 63Ø — 63Ø —	63mm Ø Electrical Duct
— 50Ø — 50Ø —	50mm Ø Electrical Duct
— HV — HV —	Supplier cable routes as per service provider quotation document

 New 600x600 Electrical inspection chamber (NAL Stakkabox) with C125 composite cover

 → Denotes new CCTV camera for EV monitoring

0 5 10

SCALE - METRES -1:100

WORKING DRAWING



PROJECT
MOTO BIRCH EAST
M62 EASTBOUND JCT 18/19
HEYWOOD, LANCASHIRE
OL10 2QH

DRAWN BY PSB	DATE 17.08.23	SCALE 1/100	PAPER SIZE A1
CHECKED BY MBH	DRAWING NUMBER ENV2268-101		REV. F