


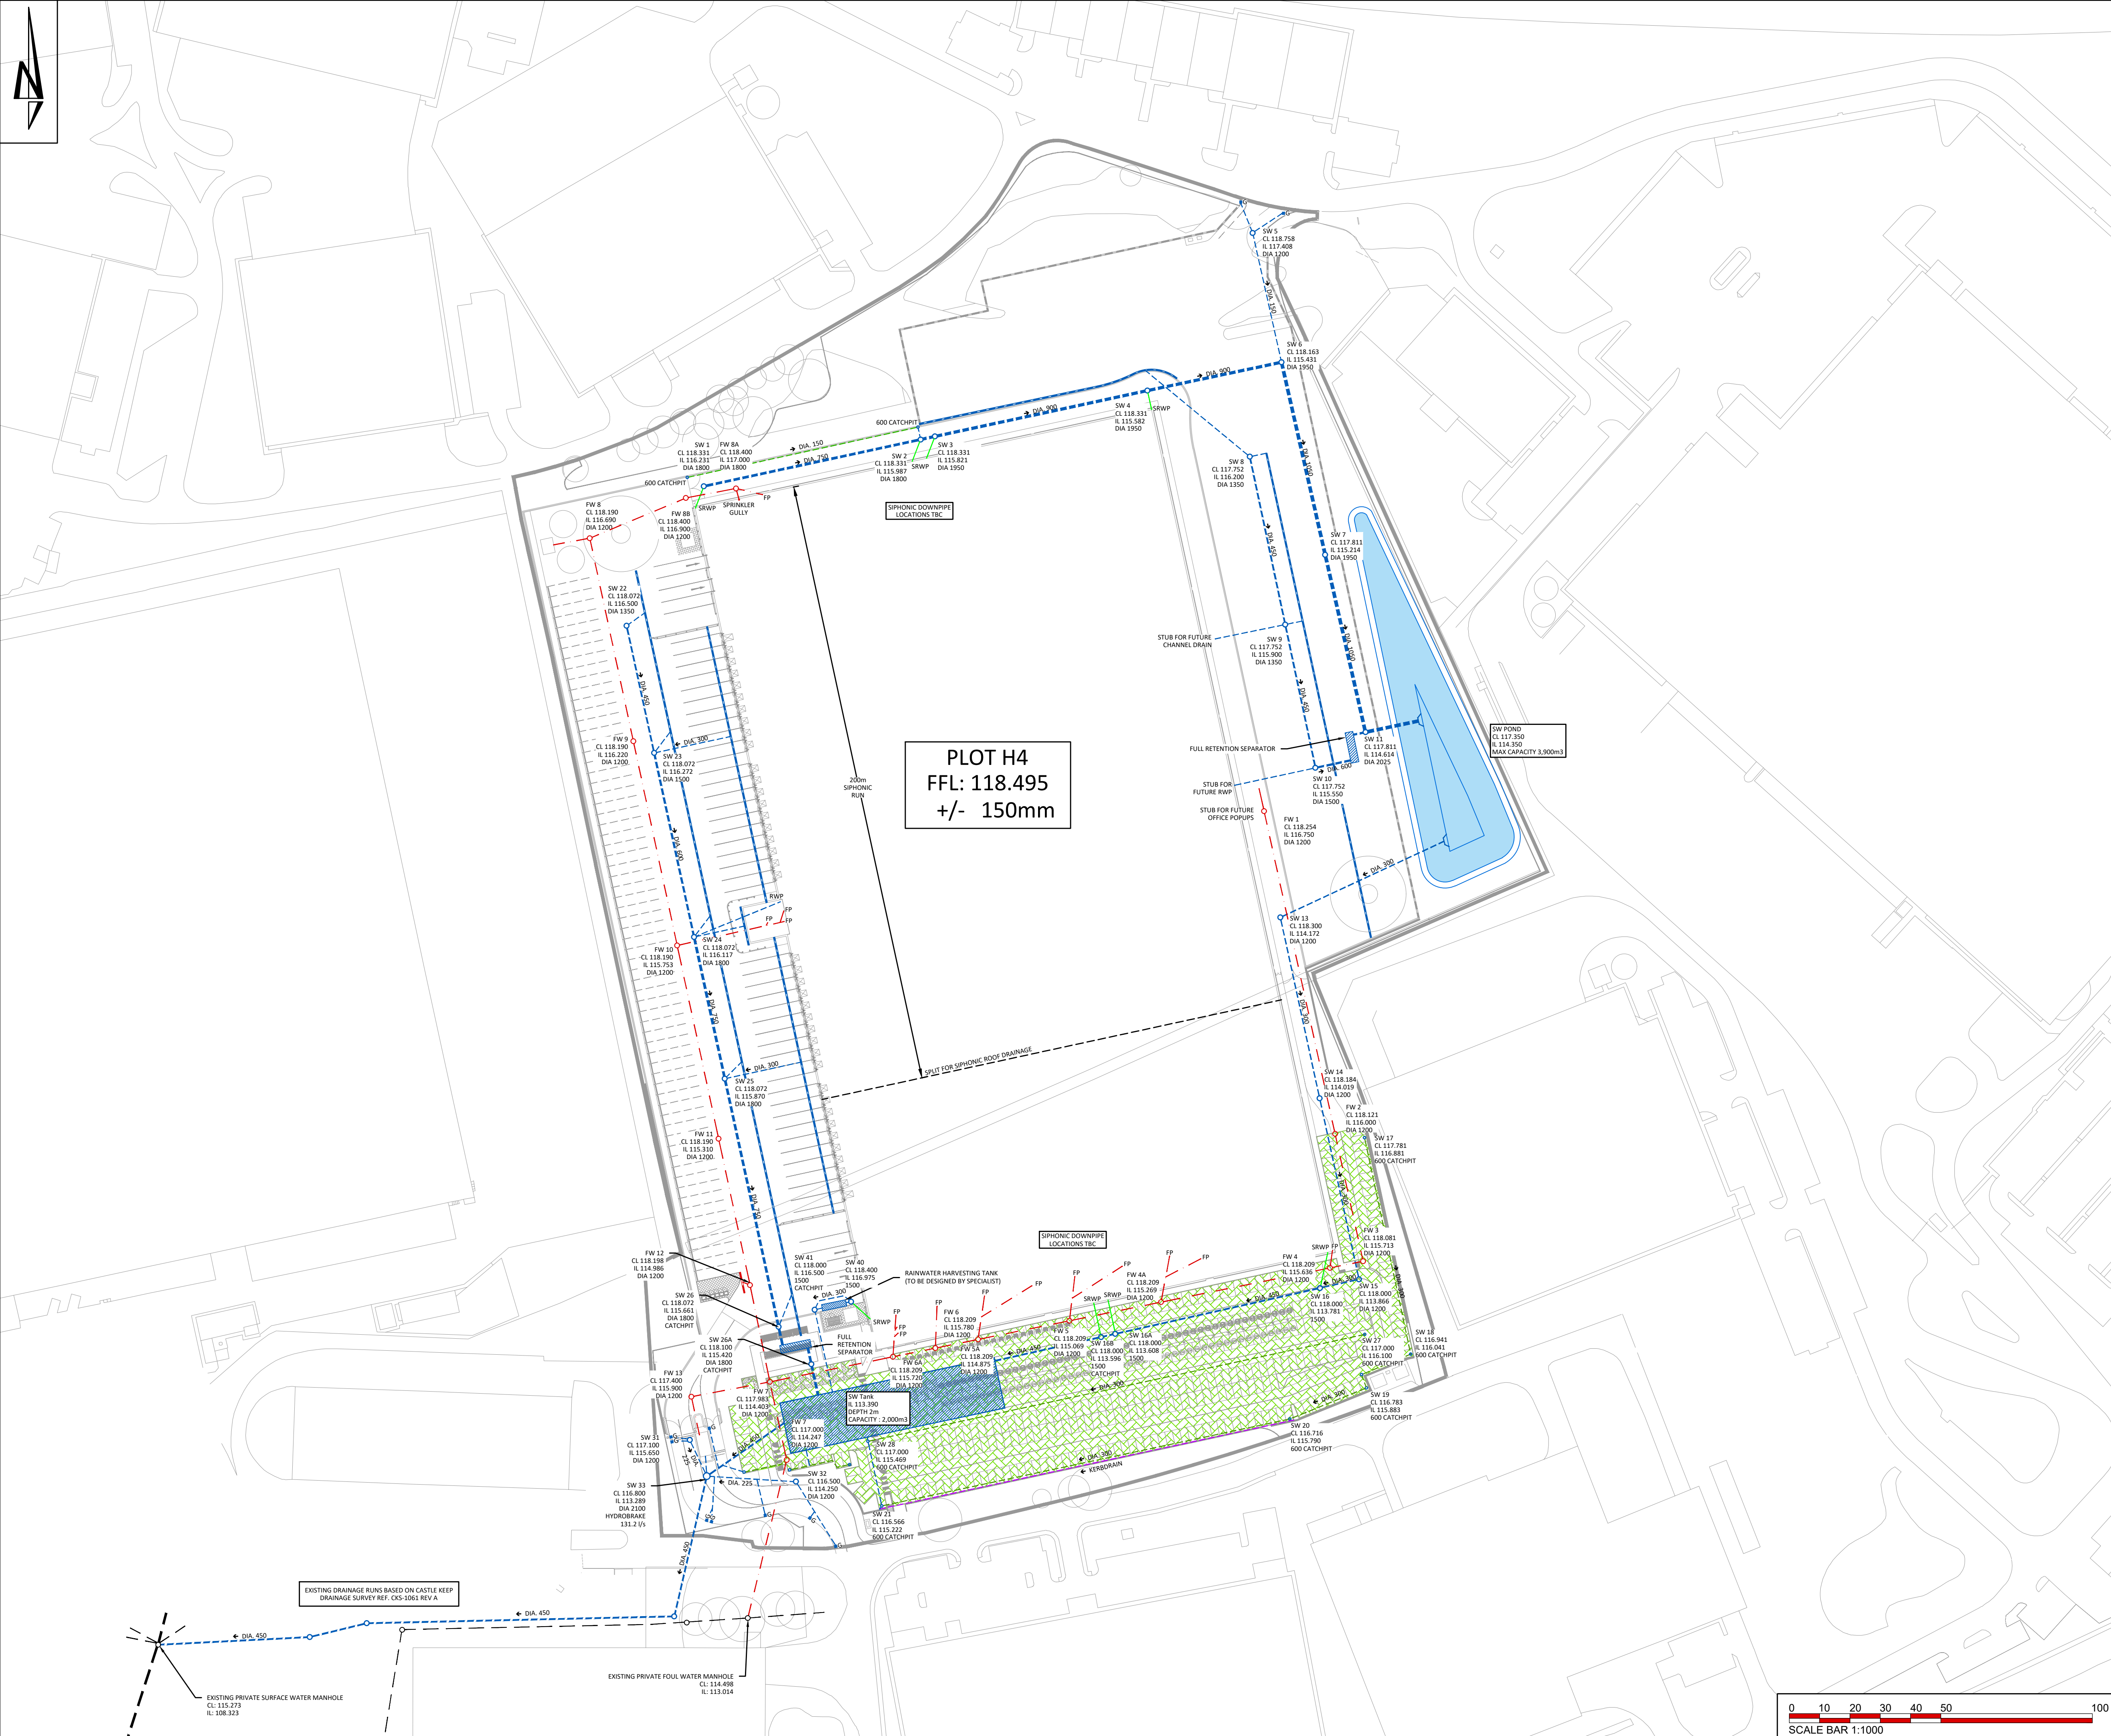

THIS DRAWING IS THE COPYRIGHT OF BURROWS GRAHAM LIMITED.

SAFETY, HEALTH AND ENVIRONMENTAL INFORMATION

IN ADDITION TO THE HAZARDS/RISKS NORMALLY ASSOCIATED WITH THE TYPES OF WORK DETAILED ON THIS DRAWING, NOTE THE FOLLOWING

CONSTRUCTION

MAINTENANCE

DEMOLITION

IT IS ASSUMED THAT ALL WORKS WILL BE CARRIED OUT BY A COMPETENT CONTRACTOR WORKING, WHERE APPROPRIATE, TO AN APPROVED METHOD STATEMENT

GENERAL NOTES:

1. This drawing shall be read in conjunction with all the relevant architects, engineers' and service engineers drawings & specifications.

2. All units in millimeters U.O.N. on the drawing.

3. Do Not Scale off the drawing.

KEY:

Surface Water Drainage

Attenuation pond

Underground Attenuation Tank

Permeable Paving (Lined)

Kerb Drain

Channel Drain

Perforated Drain / Filter Drain

Foul Water Drainage (150mm Dia, Min. Gradient 1:150)

Existing Drainage

P03	19.08.2025	BP	Update to latest layout	JW
P02	27.05.2025	BP	Update to latest layout	JW
P01	01.05.2025	BP	Preliminary Issue	JW
REV	DATE	BY	DESCRIPTION	CHKD

Burrows Graham

North Office:
5 Ambassador Place, Stockport Road,
Altrincham WA15 8DB
Tel: +44 (0)161 804 8046

South Office:
Buckland House, Dower Mews,
High Street, Berthamsted HP4 2BL
Tel: +44 (0)161 804 8046

CLIENT

INDURENT

PROJECT

HEYWOOD

DRAWING TITLE

PLOT H4
DRAINAGE LAYOUT

BGL PROJECT NUMBER	DRAWING STATUS	OFFICE
30042	PRELIMINARY	NORTH
SCALE @ A1	DATE	DRAWN BY
1:1000	01.05.2025	BP
DRAWING No	CHECKED BY	REV
30042-BGL-XX-XX-DR-C-00250	JW	P03