


DO NOT SCALE

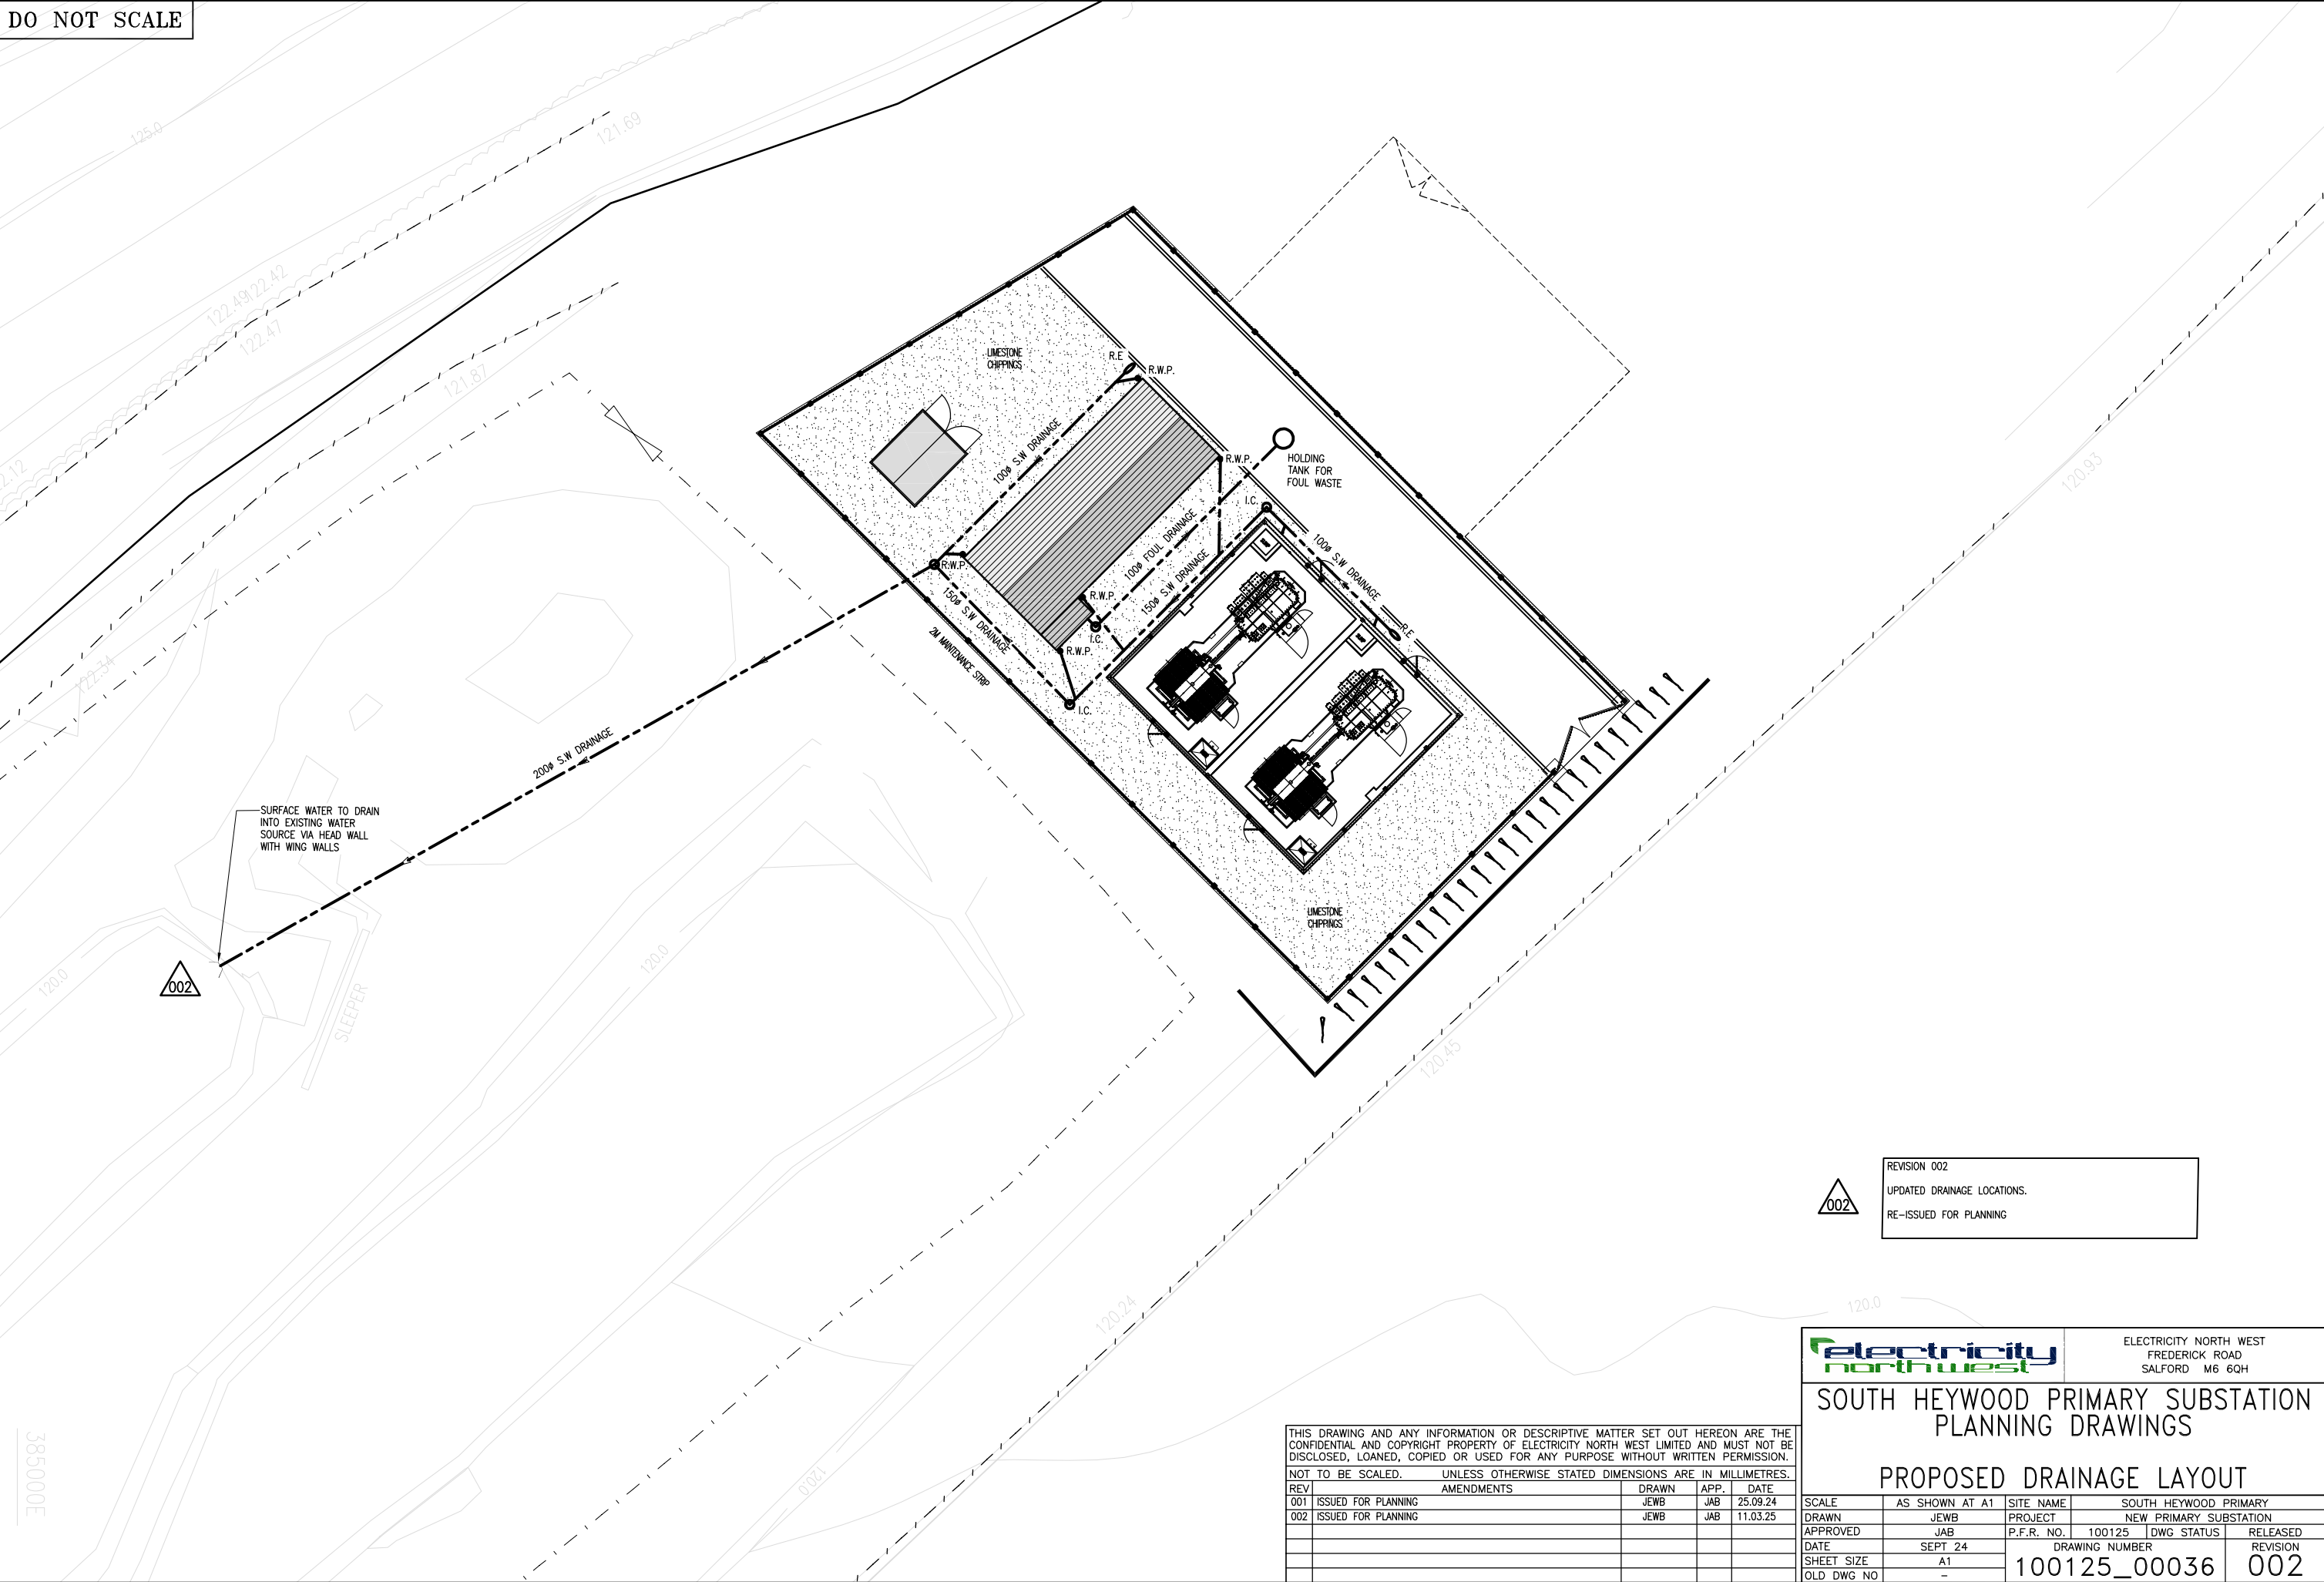

THIS DRAWING AND ANY INFORMATION OR DESCRIPTIVE MATTER SET OUT HEREON ARE THE CONFIDENTIAL AND COPYRIGHT PROPERTY OF ELECTRICITY NORTH WEST LIMITED AND MUST NOT BE DISCLOSED, LOANED, COPIED OR USED FOR ANY PURPOSE WITHOUT WRITTEN PERMISSION.				
NOT TO BE SCALED. UNLESS OTHERWISE STATED DIMENSIONS ARE IN MILLIMETRES.				
REV	AMENDMENTS	DRAWN	APP.	DATE
001	ISSUED FOR PLANNING	JEWB	JAB	25.09.24
002	ISSUED FOR PLANNING	JEWB	JAB	11.03.25



ELECTRICITY NORTH WEST

FREDERICK ROAD

SALFORD M6 6QH

SOUTH HEYWOOD PRIMARY SUBSTATION

PLANNING DRAWINGS

PROPOSED DRAINAGE LAYOUT

SCALE	AS SHOWN AT A1	SITE NAME	SOUTH HEYWOOD PRIMARY	
DRAWN	JEWB	PROJECT	NEW PRIMARY SUBSTATION	
APPROVED	JAB	P.F.R. NO.	100125	DWG STATUS
DATE	SEPT 24	DRAWING NUMBER		RELEASED
SHEET SIZE	A1	100125_00036		REVISION
OLD DWG NO	-			002

385000E