


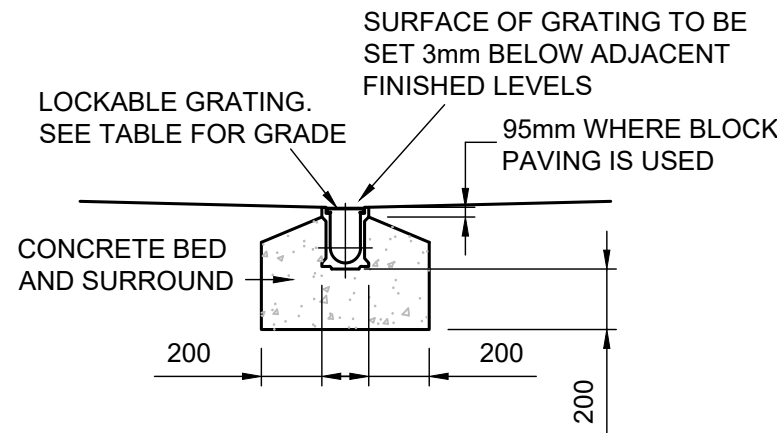
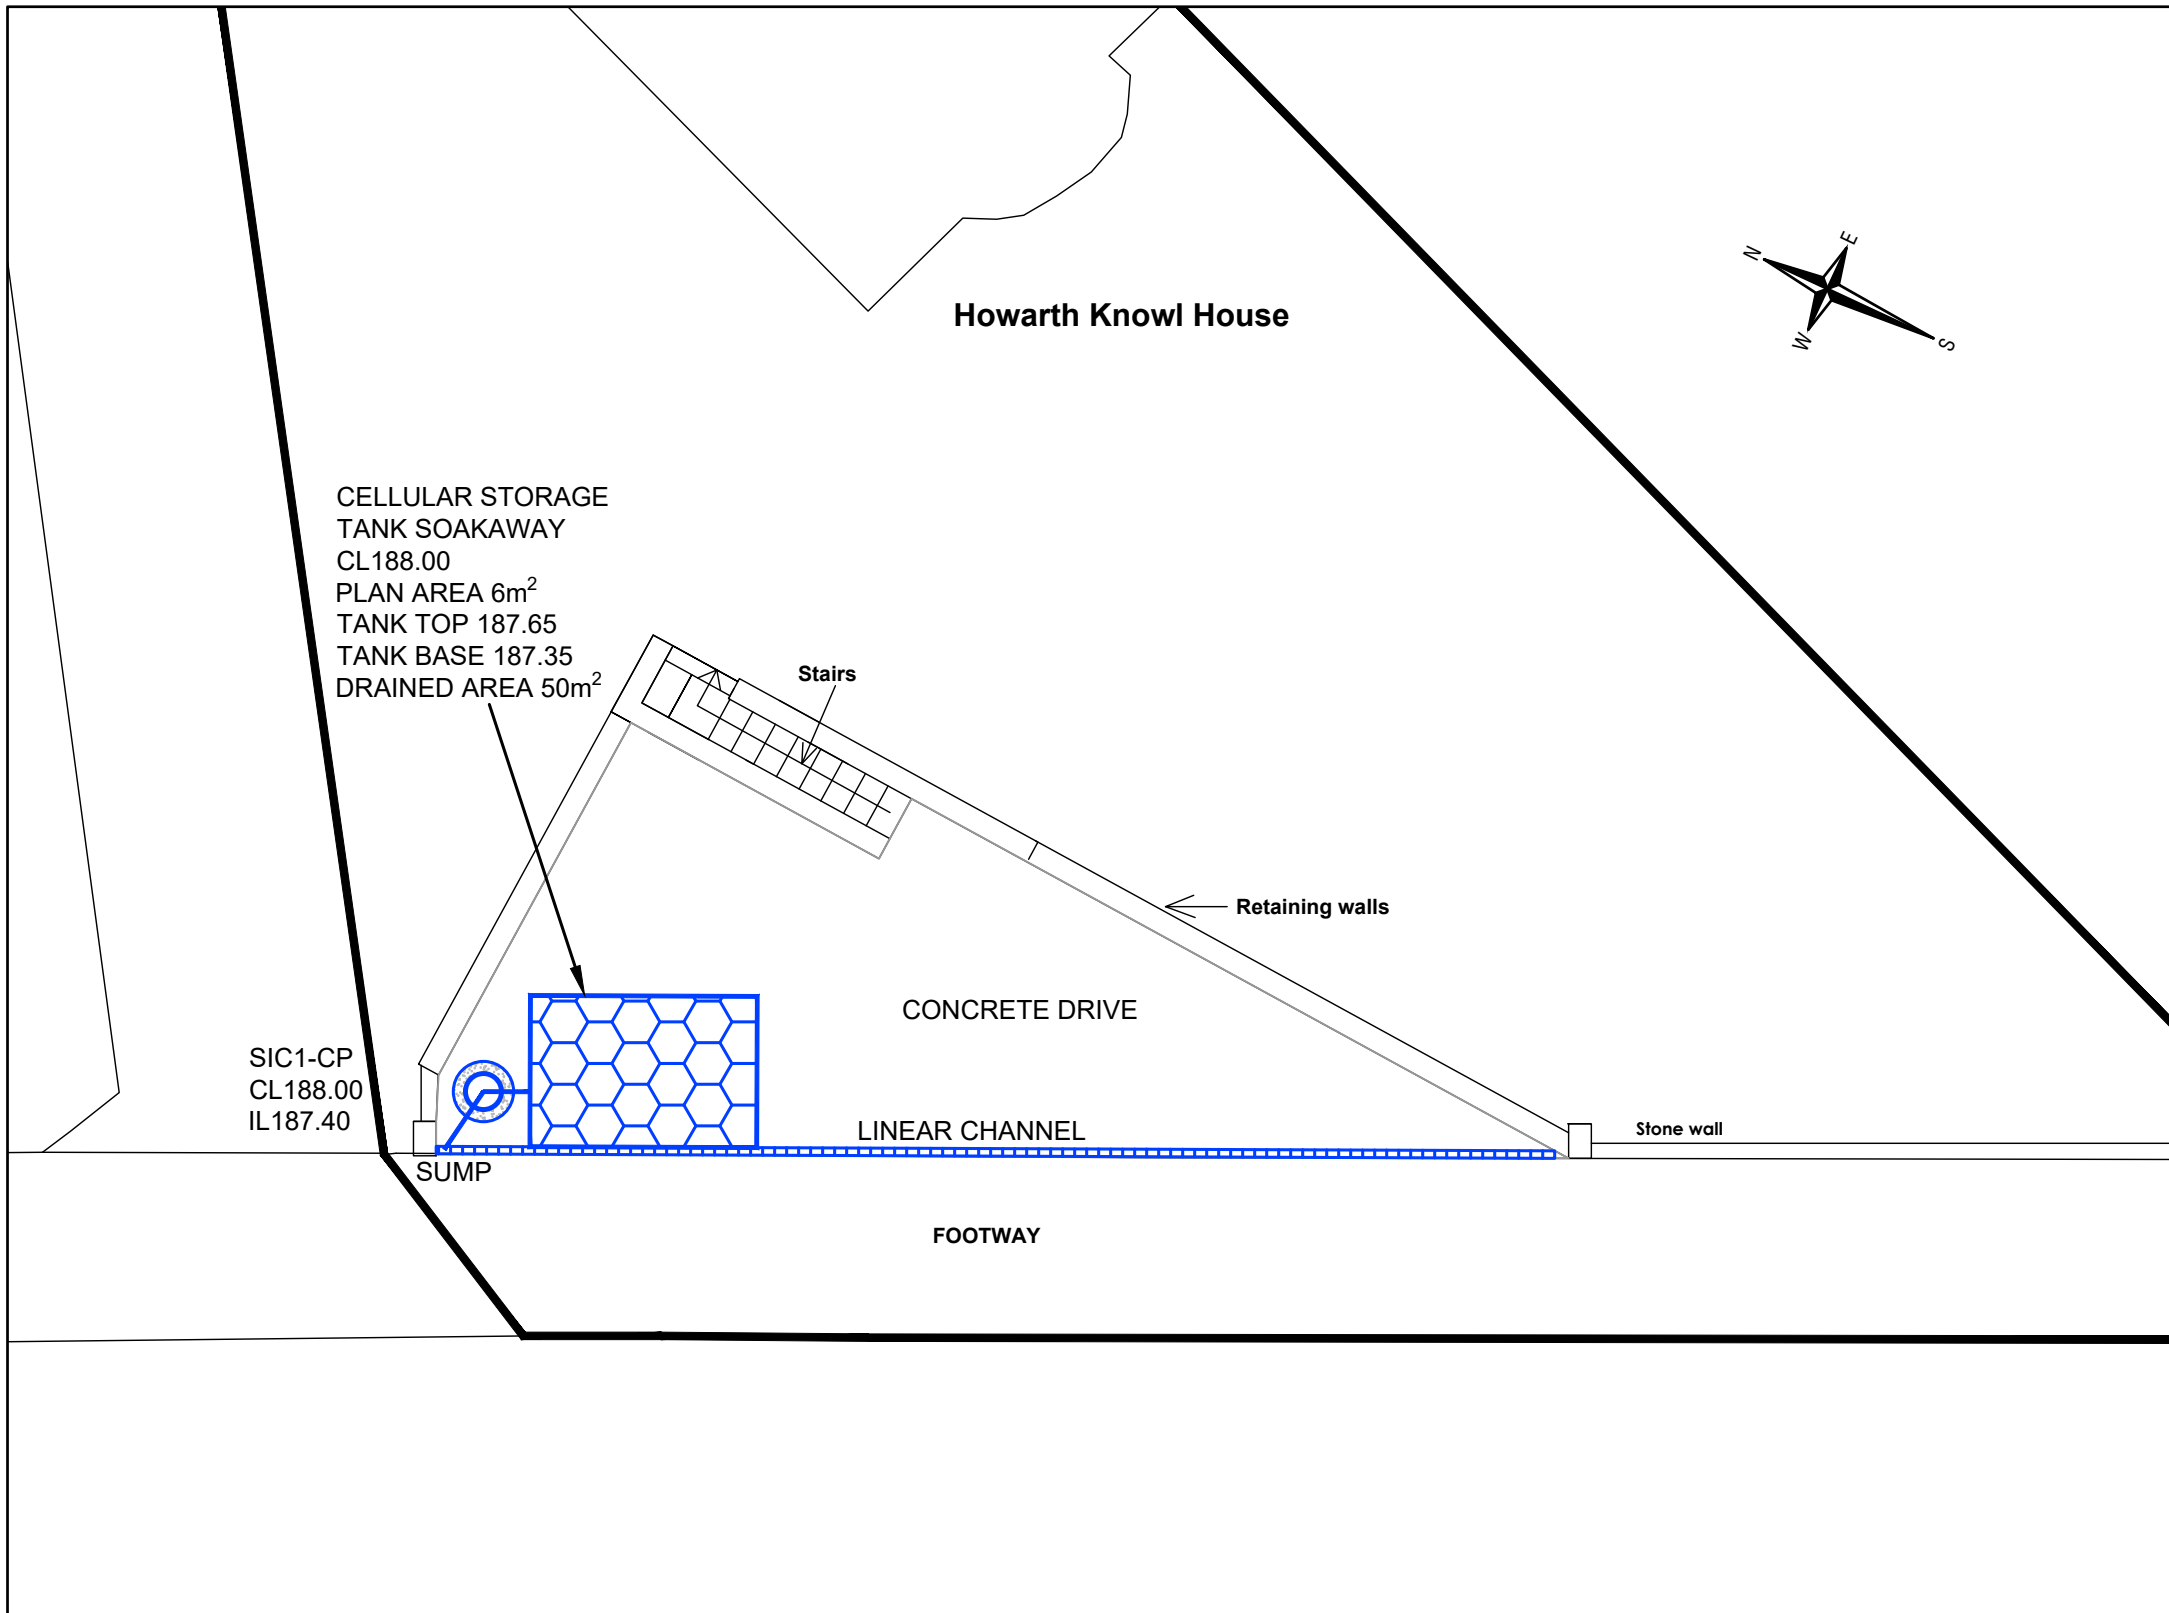
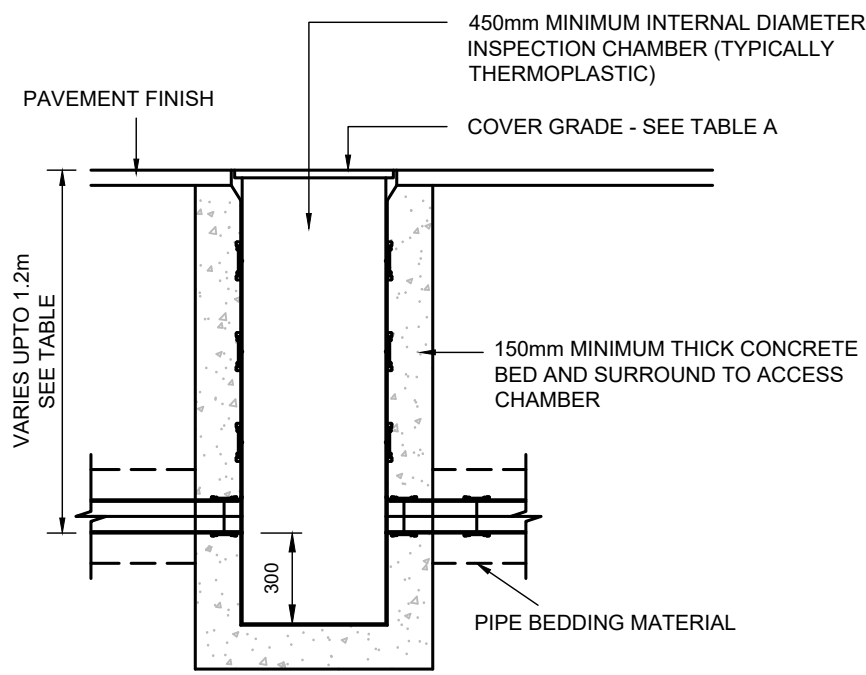


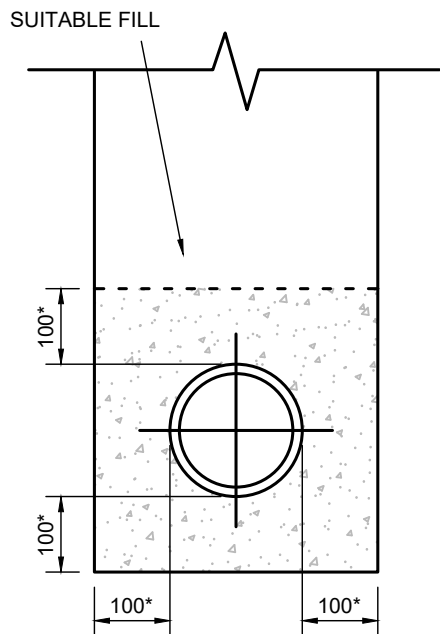

TYPICAL SECTION THROUGH
CHANNEL DRAIN
SCALE 1:25

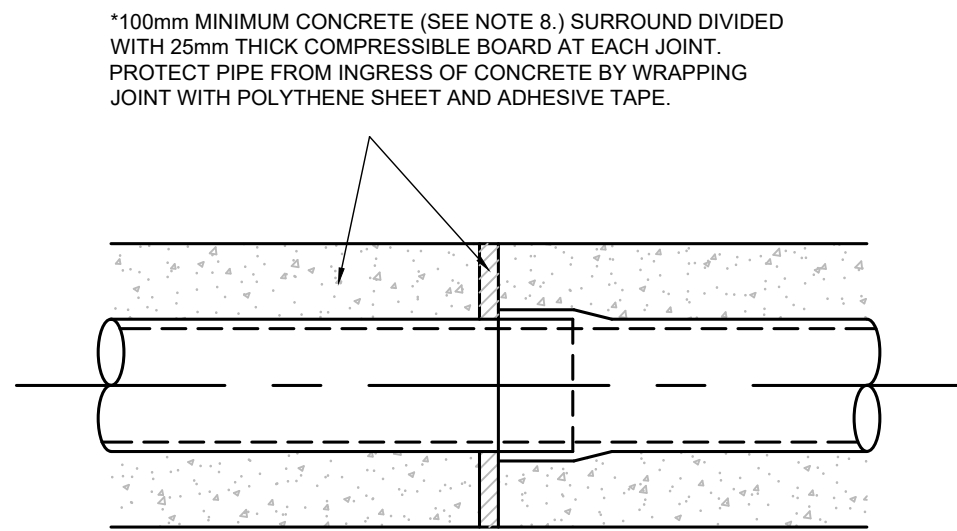


TYPICAL MEDIUM DEPTH PPIC SILT TRAP DETAIL
FOR USE IN DRIVEWAYS/CAR PARKING AREAS
(NOT SUBJECT TO HEAVY VEHICLE LOADING)
SCALE 1:25

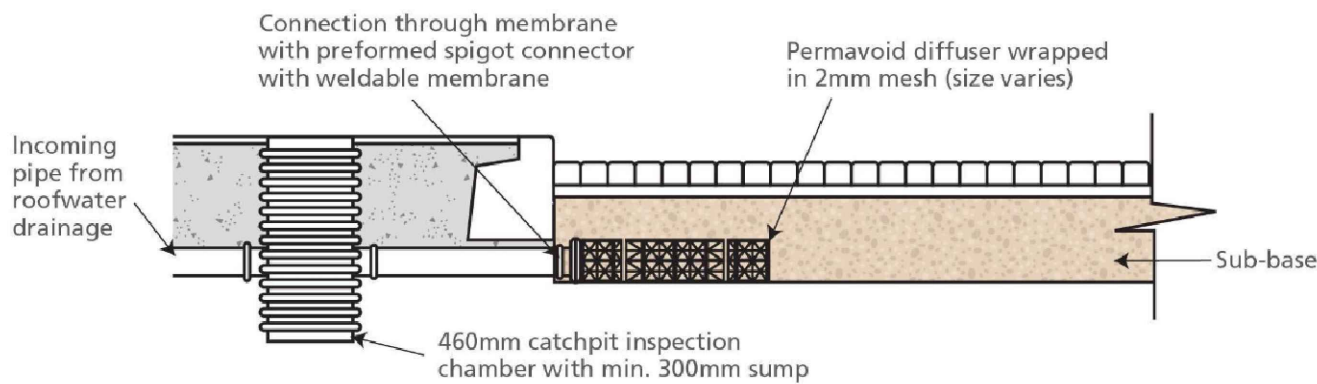

SIDE ELEVATION
TYPE Z BEDDING (CONCRETE ENCASED PIPES) FOR PIPES
WITH LESS THAN 1.2m COVER
NOT TO SCALE

* FOR HEAVY DUTY/INDUSTRIAL APPLICATIONS INCLUDING MAIN ROADS
OR ADOPTABLE ROADS INCREASE CONCRETE TO 150mm

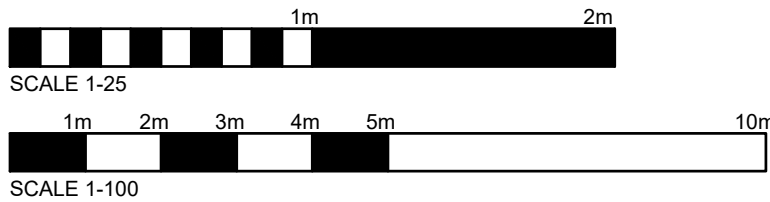

- NOTES
- CONTRACTORS MUST VERIFY ALL DIMENSIONS ON SITE BEFORE COMMENCING ANY WORK ON SHOP DRAWINGS
- DO NOT SCALE FROM THIS DRAWING
- REPORTS 4 PLANNING COPYRIGHT
- NOTES
1. ALL DIMENSIONS IN MILLIMETERS UNLESS NOTED OTHERWISE.
 2. THIS DRAWING TO BE READ IN CONJUNCTION WITH ALL OTHER ENGINEERING DRAWINGS AND CALCULATIONS ASSOCIATED WITH THIS PROJECT.
 3. ALL COMPONENTS AND MATERIALS ARE TO BE MANUFACTURED AND SUPPLIED IN ACCORDANCE WITH THE RELEVANT BRITISH STANDARDS, AND LAID AND BACKFILLED IN ACCORDANCE WITH MANUFACTURER'S INSTRUCTIONS AND THE RELEVANT BRITISH STANDARDS.
 4. THE CONTRACTOR SHALL, BEFORE COMMENCING THE WORKS, VERIFY ALL SITE AND SETTING OUT DIMENSIONS. THE CONTRACTOR SHALL BE RESPONSIBLE FOR THE TRUE AND PROPER SETTING OUT OF THE WORKS AND FOR THE CORRECTNESS OF THE POSITION, LEVELS, DIMENSIONS, AND ALIGNMENT OF ALL PARTS OF THE WORKS.
 5. ALL DRAINAGE TO BE INSTALLED AND TESTED IN COMPLIANCE WITH THE BUILDING REGULATIONS DRAINAGE AND WASTE DISPOSAL APPROVED DOCUMENT H CURRENT EDITION.
 6. SMALL LIGHTWEIGHT ACCESS COVERS SHOULD BE SECURED (FOR EXAMPLE WITH SCREWS) TO DETER UNAUTHORISED ACCESS.
 7. INSITU CONCRETE FOR USE IN GENERAL DRAINAGE WORKS, GRADE TO BS: 5328.
 8. ALL PIPES TO BE 100mm DIAMETER UNLESS NOTED OTHERWISE AND SUBJECT TO DETAILED DESIGN.
 9. ALL WORKS WITHIN THE HIGHWAY ARE TO BE COMPLETED IN ACCORDANCE WITH THE ROCHDALE BOROUGH COUNCIL HIGHWAYS DEPARTMENT SPECIFICATIONS.
 10. THE SURFACE WATER SEWER CONNECTION WILL BE SUBJECT TO A S106 SEWER CONNECTION APPLICATION WITH UNITED UTILITIES.

DRAWING LEGEND	
SURFACE WATER DRAINAGE	
	INSPECTION CHAMBER CP DENOTES CATCHPIT
	SURFACE WATER SEWER
	LINEAR CHANNEL

P2	PRELIMINARY ISSUE.	21.11.2024	RAC
P1	PRELIMINARY ISSUE.	16.04.2024	RAC
REV	AMENDMENT	DATE	CHKD

DRAWING STATUS PRELIMINARY



CLIENT
CHRISTIAN TAYLOR

PROJECT
HOWARTH KNOWL HOUSE
WARDLE ROAD
ROCHDALE, OL12 9JD

DRAWING TITLE
PROPOSED DRAINAGE PLAN

CIVILS

SCALE 1:100 @ A1
1:200 @ A3

DRAWN BY STC

CHECKED RAC

DATE APR 2024

DRAWING NUMBER
6715-CIV-10

REVISION
P2