


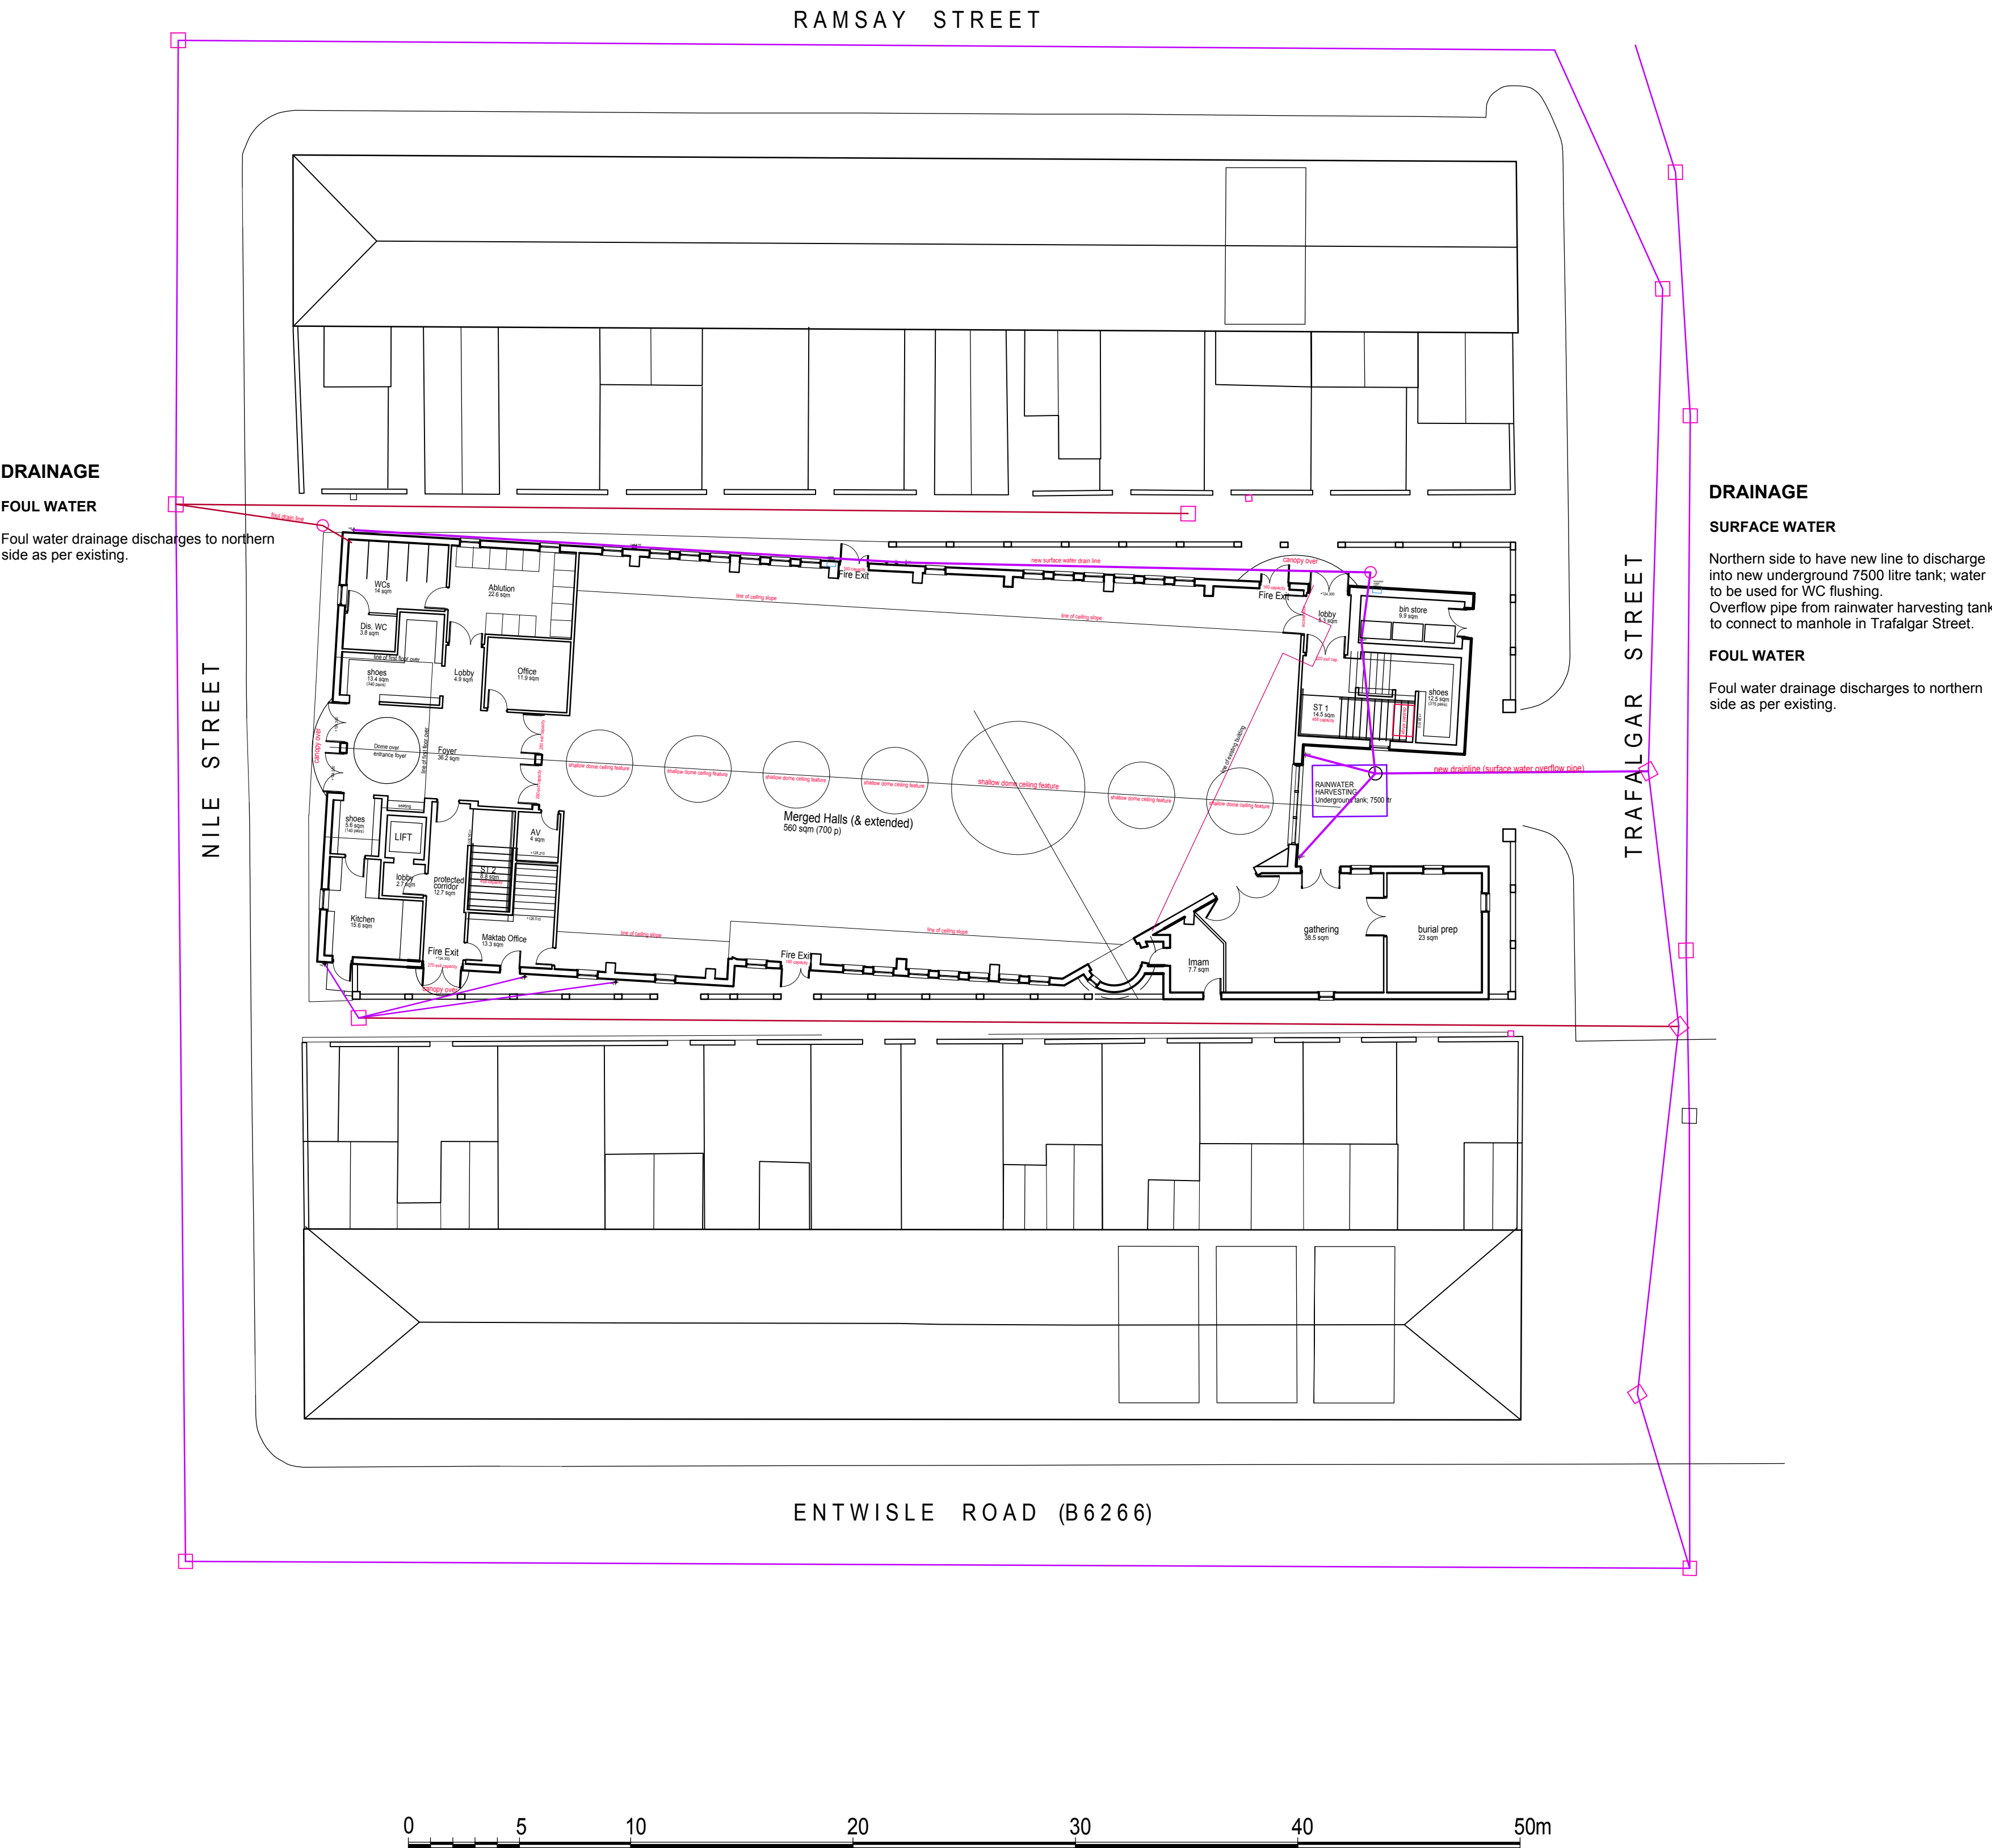

DRAINAGE

FOUL WATER

Foul water drainage discharges to northern side as per existing.

DRAINAGE

SURFACE WATER

Northern side to have new line to discharge into new underground 7500 litre tank; water to be used for WC flushing. Overflow pipe from rainwater harvesting tank to connect to manhole in Trafalgar Street.

FOUL WATER

Foul water drainage discharges to northern side as per existing.

A Planning Application 01.08.25

CLIENT
Jalalia Jaame Mosque

PROJECT
**Ground Floor Remodel,
First Floor Extension
Elevation Changes**

LOCATION
**66 Trafalgar Street
Rochdale
OL16 2EB**

DRAWING TITLE
**PROPOSED
Drainage Plan**

Scale@A1 1:200 Status PL

Project Drawing No. Rev.
2401 Pr-050-DP1 A

© Esmail Architects (trading name of M.E. Architects Ltd)