


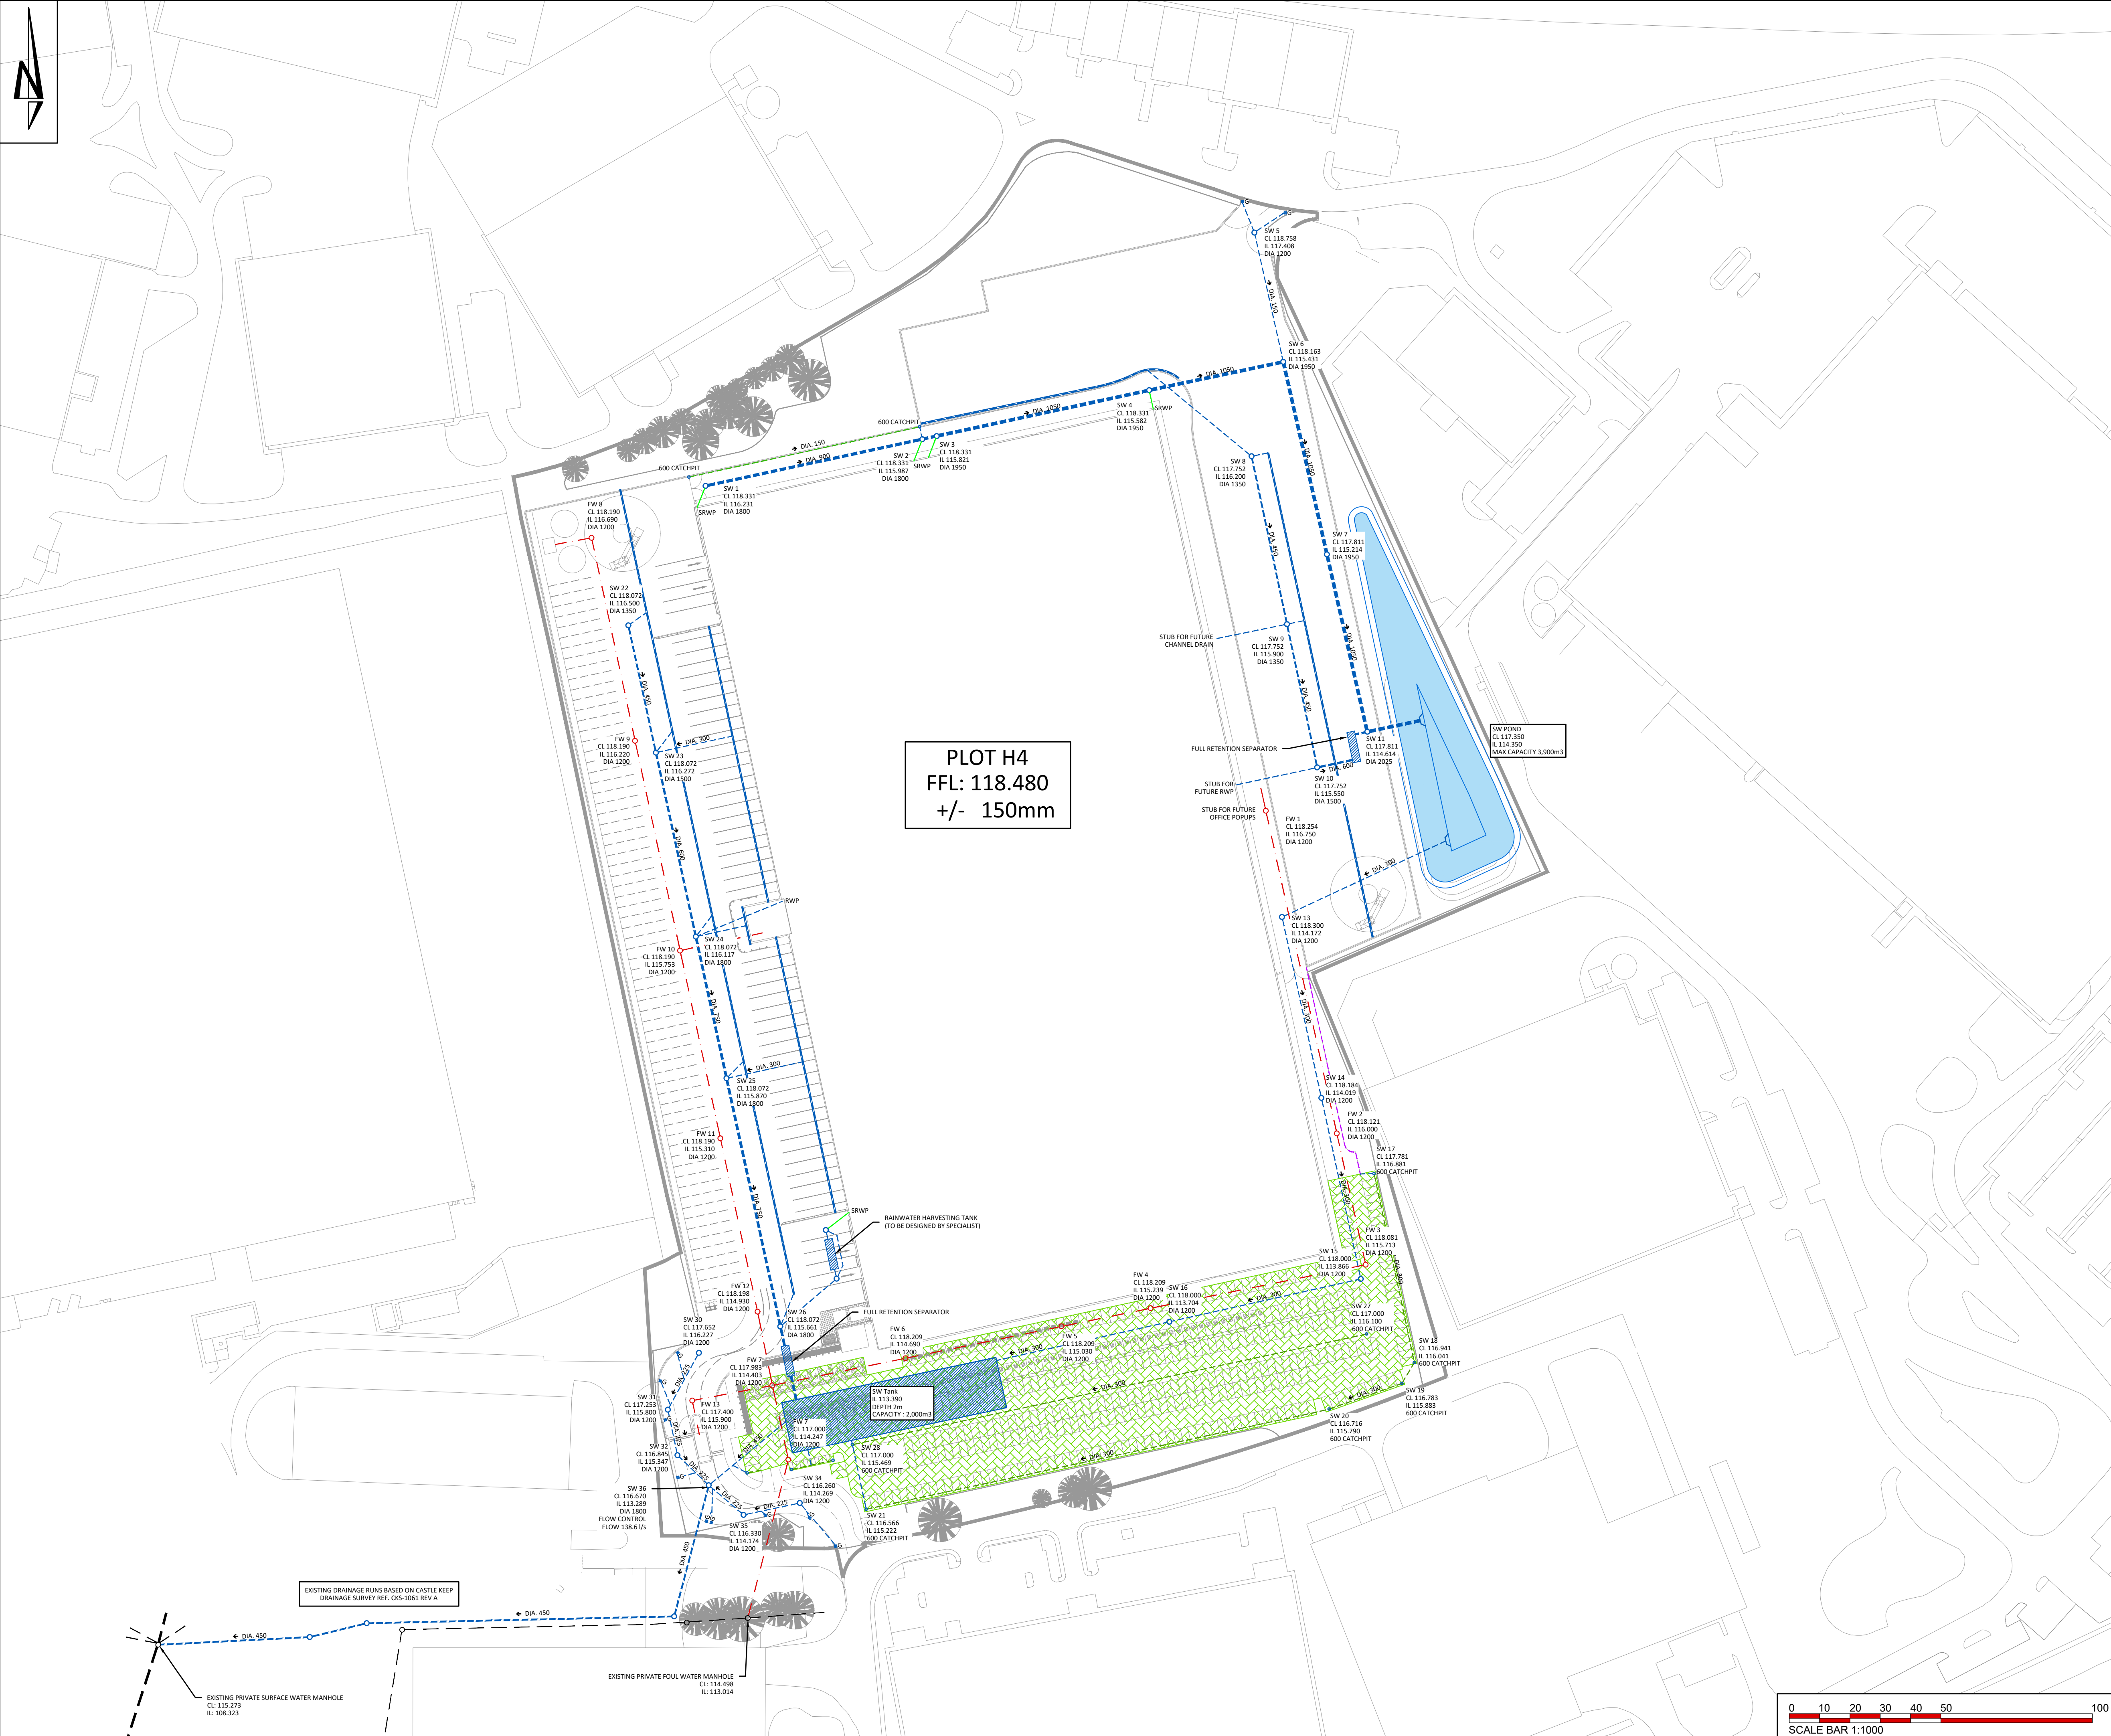

PLOT H4
FFL: 118.480
+/- 150mm

THIS DRAWING IS THE COPYRIGHT OF BURROWS GRAHAM LIMITED.	
SAFETY, HEALTH AND ENVIRONMENTAL INFORMATION	
IN ADDITION TO THE HAZARDS/RISKS NORMALLY ASSOCIATED WITH THE TYPES OF WORK DETAILED ON THIS DRAWING, NOTE THE FOLLOWING	
CONSTRUCTION	
MAINTENANCE	
DEMOLITION	
IT IS ASSUMED THAT ALL WORKS WILL BE CARRIED OUT BY A COMPETENT CONTRACTOR WORKING, WHERE APPROPRIATE, TO AN APPROVED METHOD STATEMENT	
GENERAL NOTES:	
1. This drawing shall be read in conjunction with all the relevant architects, engineers' and service engineers drawings & specifications.	
2. All units in millimeters U.O.N. on the drawing.	
3. Do Not Scale off the drawing.	

KEY:	
	Surface Water Drainage
	Attenuation pond
	Underground Attenuation Tank
	Permeable Paving (Lined)
	Kerb Drain
	Channel Drain
	Perforated Drain / Filter Drain
	Foul Water Drainage (150mm Dia, Min. Gradient 1:150)
	Existing Drainage

P01	01.05.2025	BP	Preliminary Issue	JW
REV	DATE	BY	DESCRIPTION	CHKD

North Office:
5 Ambassador Place, Stockport Road,
Altrincham WA15 8DB
Tel: +44 (0)161 804 8046

South Office:
Buckland House, Dower Mews,
High Street, Benhamstead HP4 2BL
Tel: +44 (0)161 804 8046

CLIENT

PROJECT

HEYWOOD

DRAWING TITLE

PLOT H4
DRAINAGE LAYOUT

BGL PROJECT NUMBER 30042	DRAWING STATUS PRELIMINARY	OFFICE NORTH
SCALE @ A1 1:1000	DATE 01.05.2025	DRAWN BY BP
		CHECKED BY JW

DRAWING No 30042-BGL-XX-XX-DR-C-00250	REV P01
--	------------

