


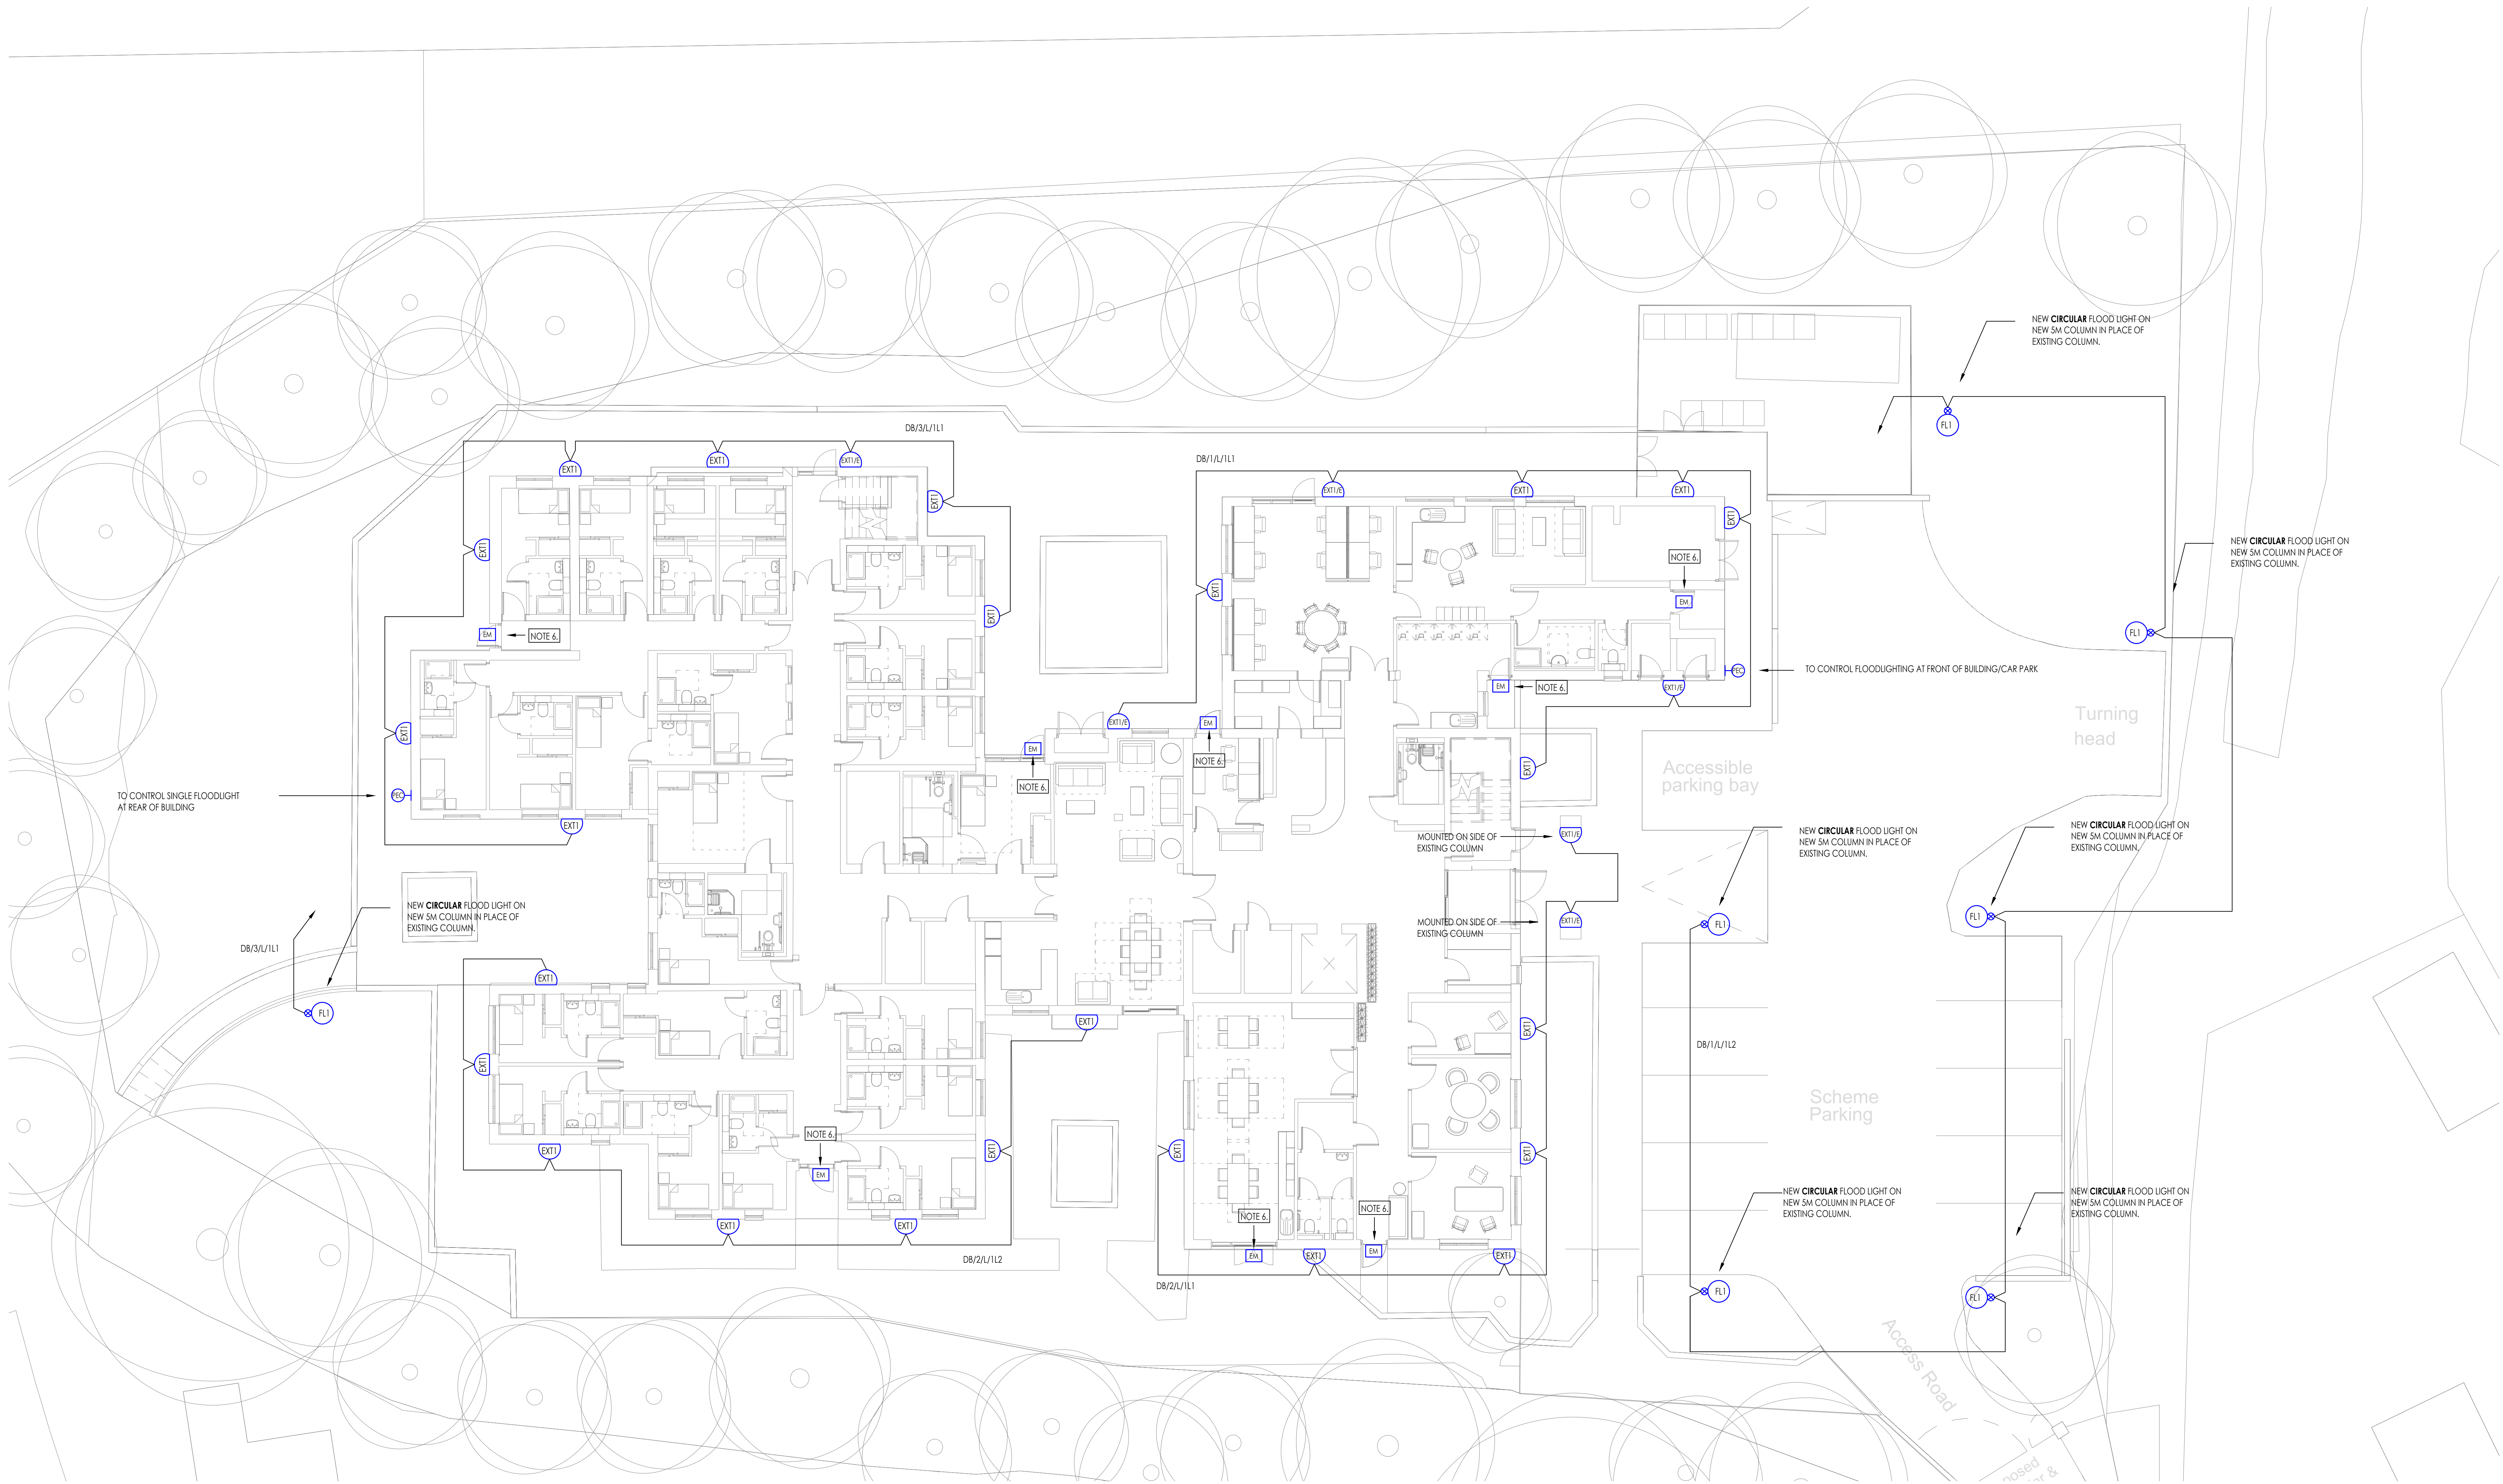

PROPOSED EXTERNAL LIGHTING LAYOUT
SCALE 1:100 @ A0

SYMBOLS LEGEND - EXTERNAL LIGHTING

EXT1 8W, 2773 LUMEN OUTPUT WALL MOUNTED HIGH PERFORMANCE ENERGY EFFICIENT LED LUMINAIRE, IP65, IK10, CRI 80, 2700K C/W IN BUILT PHOTOCELL CONTROL, DIE-CAST ALUMINIUM BODY AND POLYCARBONATE LENS, IN BLACK FINISH, AS MANUFACTURED BY STEON LIGHTING AT THEIR VISTAL GRILLE LED.

NOTE: SUFFIX /E DENOTES 3 HOUR EMERGENCY VERSION OF THE ABOVE.

FL1 20W, 6098 LUMEN OUTPUT 5 METRE COLUMN MOUNTED URBAN FLOOD LIGHT, IP66 60MM SPICOT ENTRY, R09, 2700K, CRI 70, AS MANUFACTURED BY STEON LIGHTING AT THEIR VISTAL GRILLE LED. SHALL BE C/W NEW 5 METRE COLUMN IN BLACK FINISH TO REPLACE THE EXISTING.

EM 3.2W 150 LUMEN OUTPUT, SURFACE MOUNTED 3 HOUR NON-MAINTAINED EMERGENCY LUMINAIRE, IP65, AS MANUFACTURED BY STEON LIGHTING AS THEIR CONTRACT PACK LED.

FE1 EXTERNAL LUMINAIRE CONTROLLED BY PHOTO-ELECTRIC CELL - (DUSK - DAWN) & TIMER WITH OVERRIDE

HAZARD IDENTIFICATION			⚠
REF	HAZARD	DATE	

NOTES

- ALL SERVICES ROUTED ARE APPROXIMATE. THE CONTRACTOR SHALL BE RESPONSIBLE FOR DETERMINING THE EXACT ROUTES AND POSITIONS OF ALL INSTALLED SERVICES AND EQUIPMENT.
- THE EXACT POSITION OF ALL SERVICES AND EQUIPMENT SHALL BE AGREED BY THE CONTRACT ADMINISTRATOR.
- THE CONTRACTOR SHALL BE RESPONSIBLE FOR FULLY CO-ORDINATING ANY SERVICES INSTALLED WITH THE BUILDING FABRIC AND SERVICES INSTALLED BY OTHERS.
- THIS DRAWING SHALL BE READ IN CONJUNCTION WITH ALL CONTRACT DOCUMENTATION AND SPECIFICATION FOR THE WORKS.
- ALL DIMENSIONS SHOWN ARE IN MILLIMETRES.
- CONNECTED TO LOCAL LIGHTING CIRCUIT.

IT	PLANNING	REF	S	IT	13 DEC 2025
Rev	Description	By	Chk	Date	Date

DO NOT SCALE OFF THIS DRAWING. ALL DIMENSIONS SHALL BE VERIFIED ON SITE.

Client
ROCHDALE METROPOLITAN BOROUGH COUNCIL

Project
LEOPOLD COURT

File
PROPOSED EXTERNAL LIGHTING LAYOUT



Robert Whetham Associates ☒		Robert Whetham Associates ☐	
Corple Hill House, 31 Mill Brow		M-Space, Mend Science Park	
Chadderton, Oldham		Gastwen	
Greater Manchester		Ynys Môn / Isle of Anglesey	
OL11 2RT		LW20 6AR	
Tel: 0161 624 5544		Hdn/tel: 01248 544014	
www.robertwhetham.co.uk		email: enquiries@robertwhetham.co.uk	
Drawn by	Checked by	Designed by	Date
RPW	EL	YP	15 DEC 2025
Scale	Quotation/contract	Revision	Sheet
1:100 @ A0	W2368-RWA-00-XX-DR-E-9001		P1