


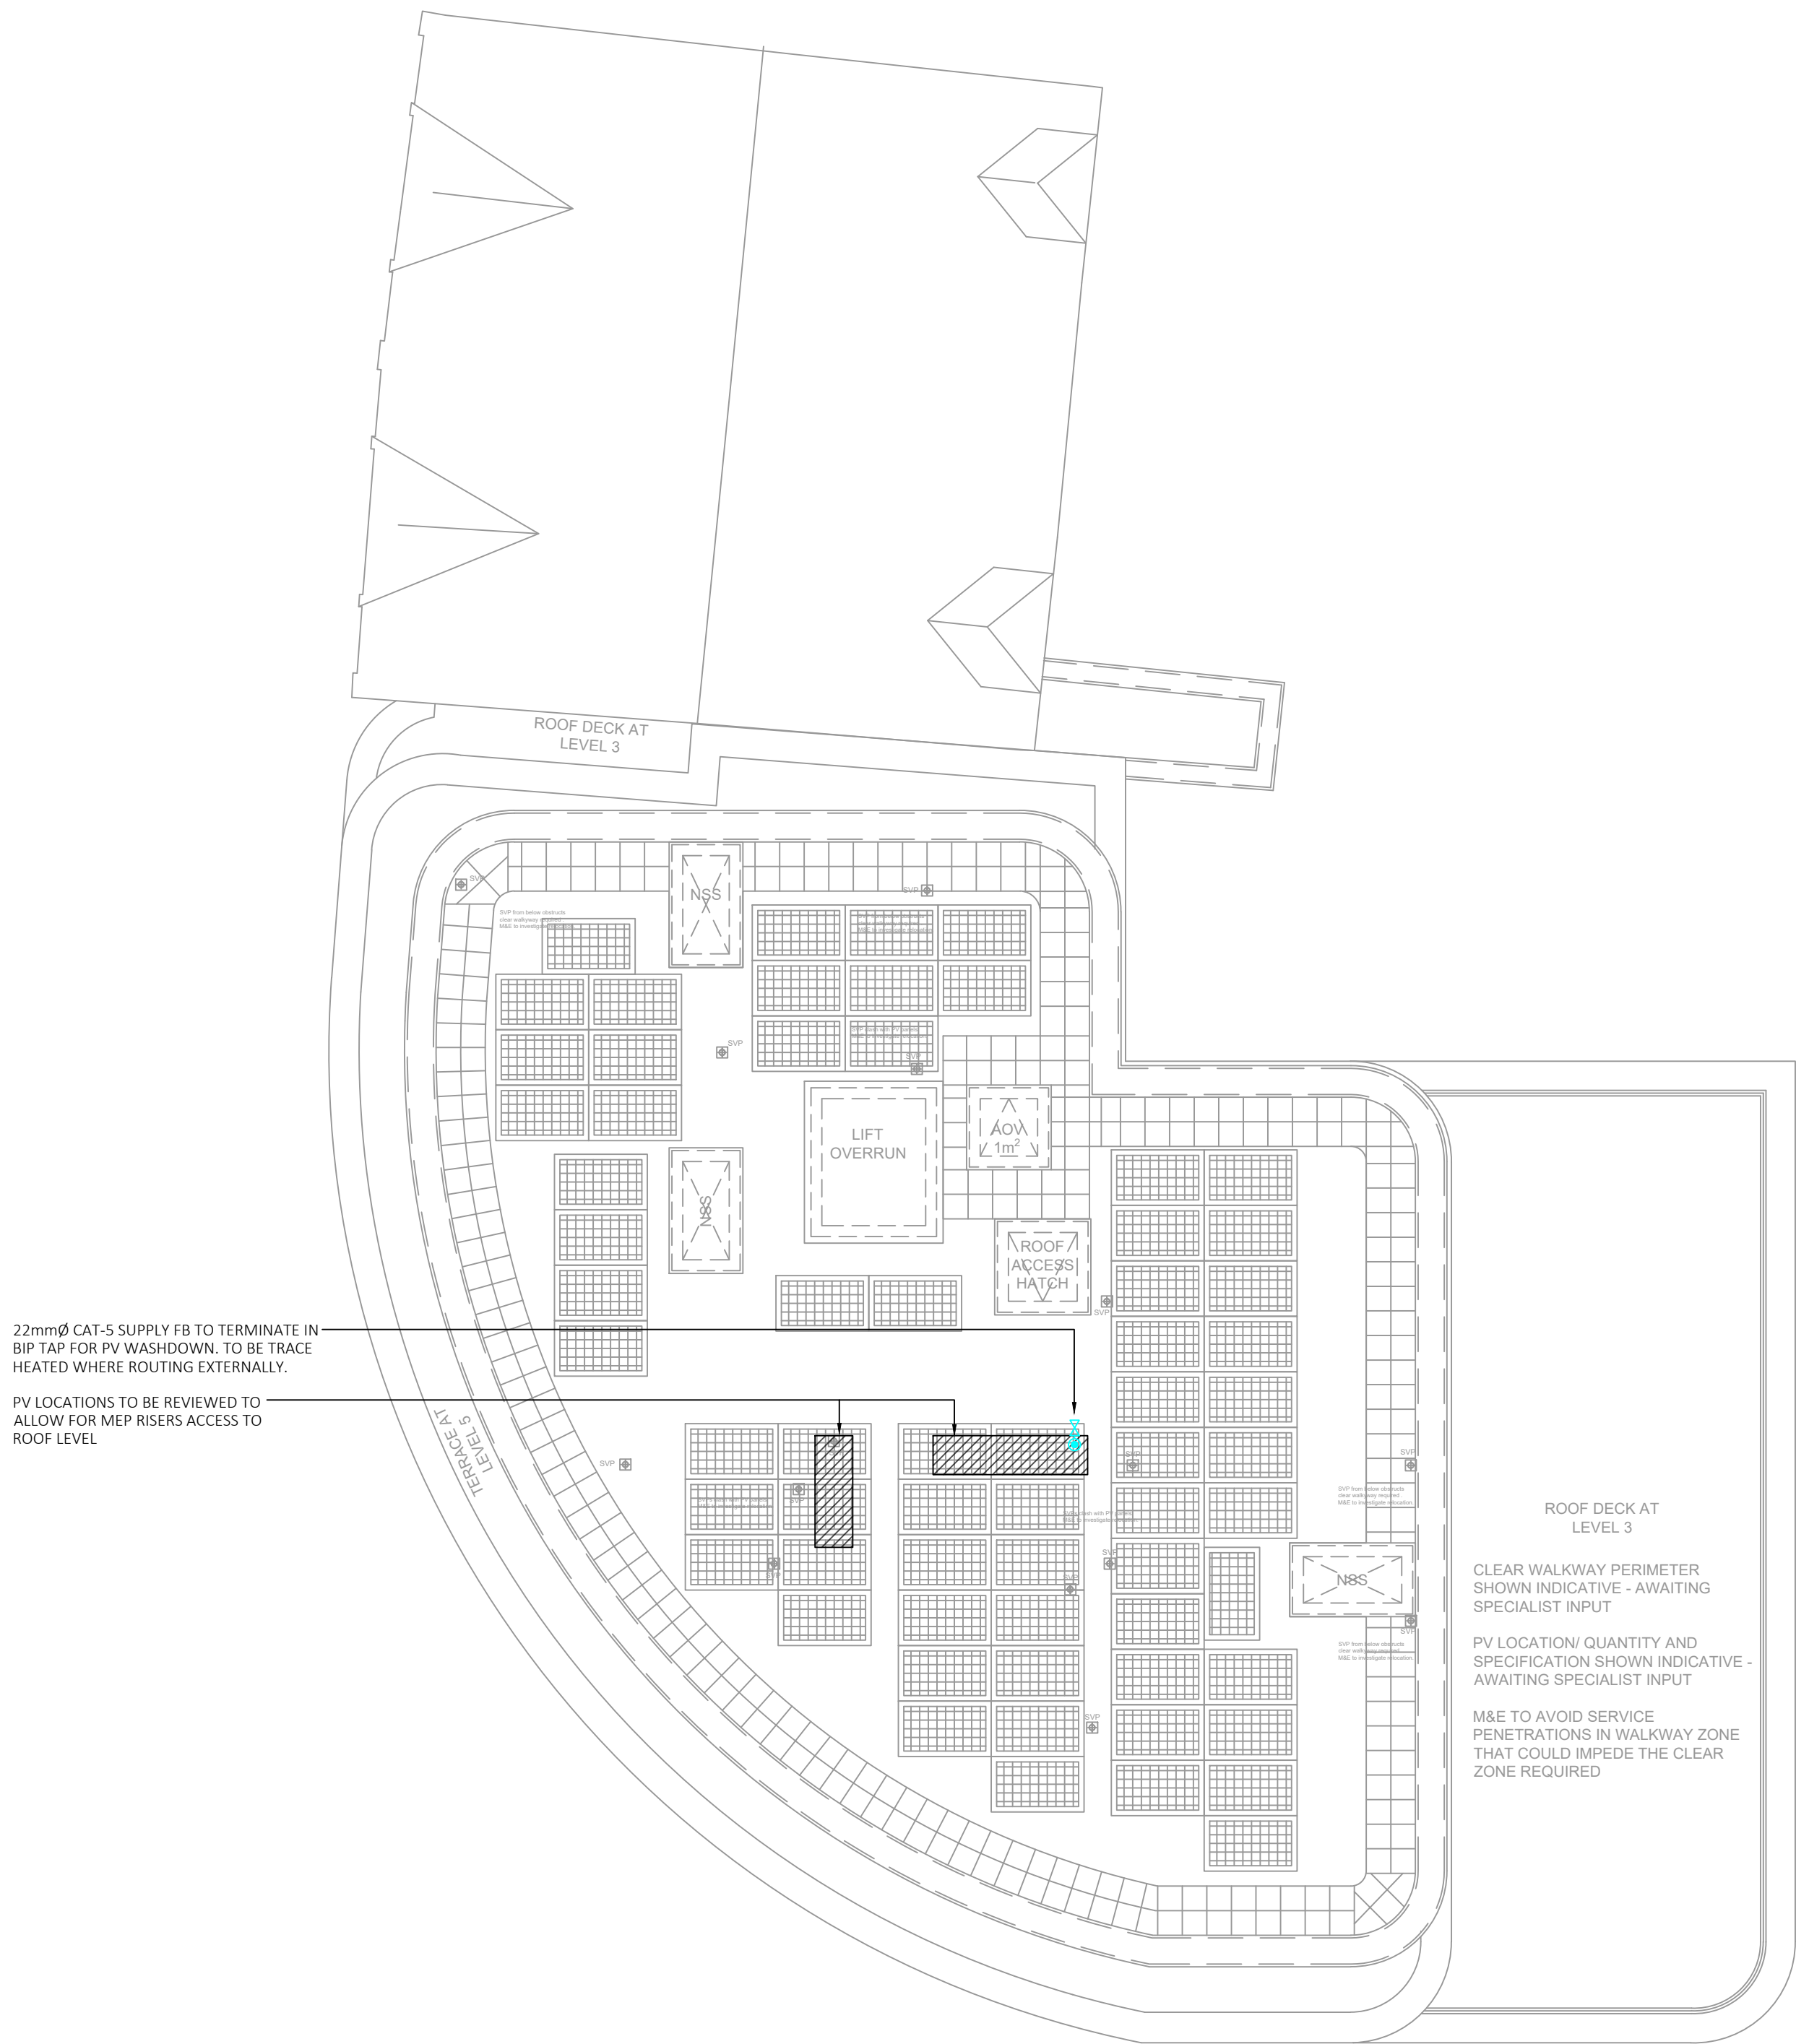

- STANDARD NOTES**
- THIS DRAWING IS SUBJECT TO COPYRIGHT AND IS NOT TO BE REPRODUCED IN PART OR WHOLE WITHOUT APPROVAL.
 - DO NOT SCALE THIS DRAWING - CHECK ALL DIMENSIONS ON SITE.
 - THIS DRAWING SHALL BE READ IN CONJUNCTION WITH THE PROJECT SPECIFICATION(S) AND ALL OTHER CONTRACT DOCUMENTATION.
 - ALL DIMENSIONS ARE IN MILLIMETRES UNLESS OTHERWISE STATED.
 - LOCATION OF ALL EQUIPMENT SHOWN SHALL BE CONFIRMED/APPROVED WITH THE CLIENT/ARCHITECT/ENGINEER PRIOR TO ANY INSTALLATION.
 - THIS DRAWING MUST BE READ IN CONJUNCTION WITH MECHANICAL AND ELECTRICAL PERFORMANCE SPECIFICATIONS AND ALL OTHER DRAWINGS AS ISSUED BY THE ARCHITECT, STRUCTURAL ENGINEER AND WATT ENERGY AND CONSULTING ENGINEERS.
 - THE LOCATION OF EQUIPMENT IS TYPICAL ONLY. THE CONTRACTOR SHALL PERFORM ALL CALCULATIONS TO DETERMINE THE EXACT QUANTITY AND AGREE THE FINAL LOCATIONS WITH THE ARCHITECT.
 - THIS DRAWING SHOWS THE INTENDED LOCATION OF BUILDING SERVICES PLANT AND SERVICE ROUTES IN SUCH DETAIL AS TO INDICATE THE DESIGN. THE DRAWING DOES NOT SHOW ALL COMPONENTS THAT MAY BE NECESSARY TO PROVIDE A FULL WORKING INSTALLATION.
 - THE POSITIONS OF CONNECTION POINTS, ACCESSORIES AND BUILDING SERVICES ITEMS ARE APPROXIMATE AND SHOWN FOR GUIDANCE TO ASSIST DURING THE TENDER PROCESS.
 - FULLY CO-ORDINATED DRAWINGS, CONSTRUCTION DRAWINGS AND BUILDERSWORK DRAWINGS SHALL BE PRODUCED BY THE CONTRACTOR. UNDER NO CIRCUMSTANCES SHALL THE TENDER DRAWINGS BE USED AS INSTALLATION DRAWINGS.
- © CIVIC LIMITED

DOMESTIC LEGEND

- Thermostatic Mixing Valve
- Outlet
- IV
- Isolation Valve
- PIPEWORK RISE / DROP
- AMR WATER METER
- BOOSTER COLD WATER SERVICES (BCWS) HIGH LEVEL IN CEILING VOID
- SPRINKLER PIPEWORK HIGH LEVEL IN CEILING VOID
- INCOMING COLD WATER MAINS BELOW FLOOR
- NOTE A** 22mmØ BCWS ROUTING WITHIN C/V TO ENTER APARTMENT AT HL FIT WITH IV
- HL HIGH LEVEL
- DTLL DOWN TO LOW LEVEL
- DTML DOWN TO MID LEVEL
- RTHL RISE TO HIGH LEVEL
- RTA RISE TO ABOVE
- DTB DOWN TO BELOW
- CV CEILING VOID

C01	TENDER ISSUE	LH	15.12.25
No.	REVISION	ISSUED BY	DATE

CIVIC

team-civic.com

CLIENT
RDA

PROJECT
ROCHDALE STATION - CORNER PLOT

TITLE
DOMESTIC SERVICES LAYOUT
ROOF PLAN

STATUS / SUITABILITY DESCRIPTION	SUITABILITY CODE
TENDER ISSUE	A1

PROJECT STATUS / ISSUE PURPOSE
STAGE 3

SCALE @ A1	Date Created	Drawn by	Checked by	Approved By
1:100	03/11/25	LH	NH	DW

DRAWING No.	REV
71465-CIV-XX-R1-D-P-50007	C01