


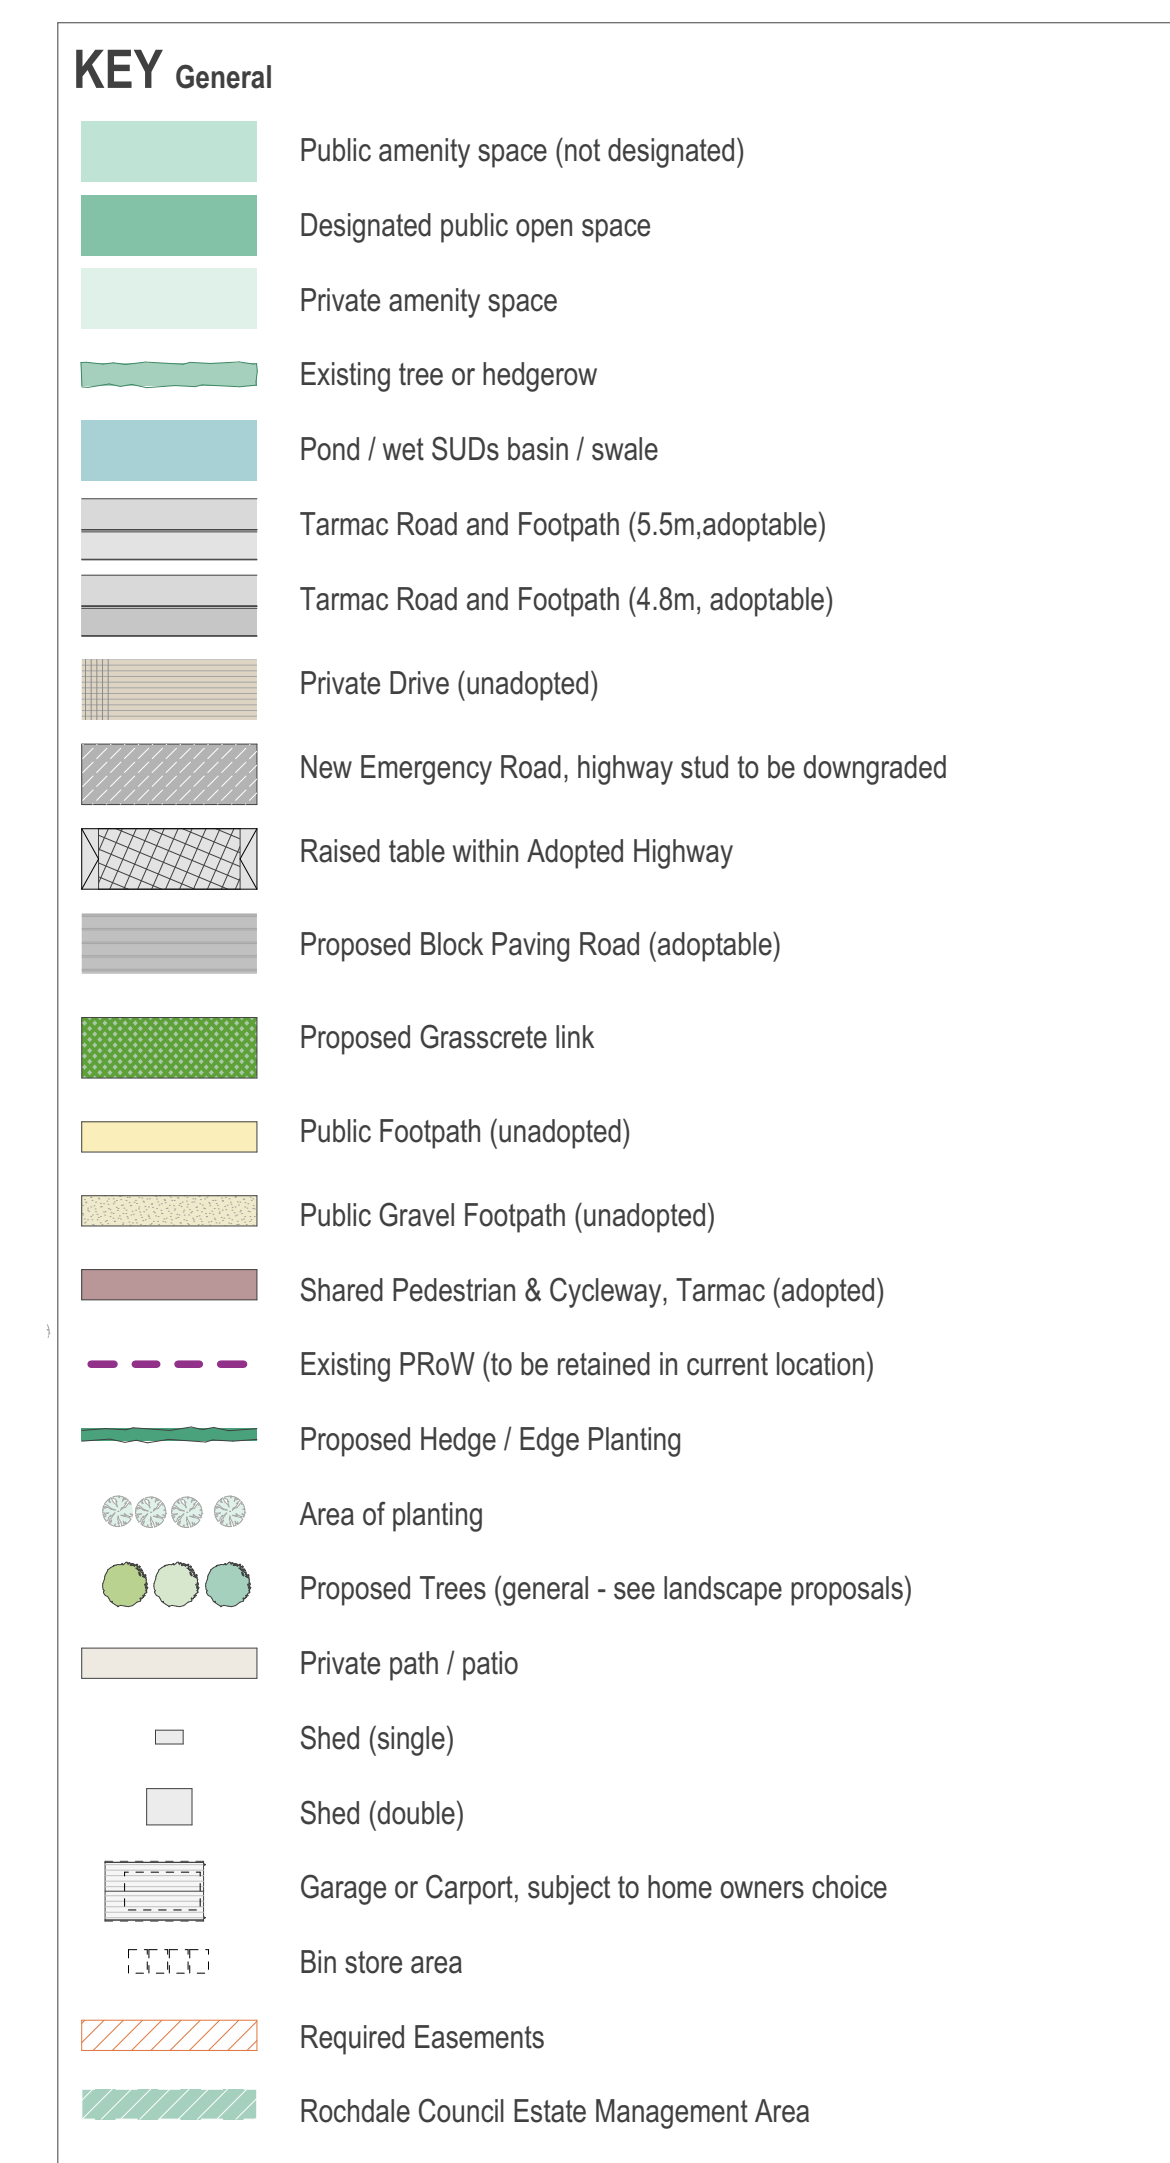

— Proposed new Sub-station
— New pumping station

NORTHSTONE			
Venzet, 1 Old Park Ln Tuxford City M41 7HA			
PLANNING			
Project:			
Harehill Road North, South Heywood			
Drawing Name:			
Proposed Layout			
Scale @ A0: 1:500	Date: July '25	Drawn: SC	Checked: ROB
Drawing No: SH01-P-SL-003			Revision: H

Notes: All specifications, materials and workmanship to be in accordance with current NHBC and Building Regulations. Main drainage to comply with Sewers for Adoption current edition. Highways to be in accordance with Local Authority specification. Do not scale from this drawing. All dimensions to be verified with the drawing office. Print in colour.

Sketch Site Plan
1:500