


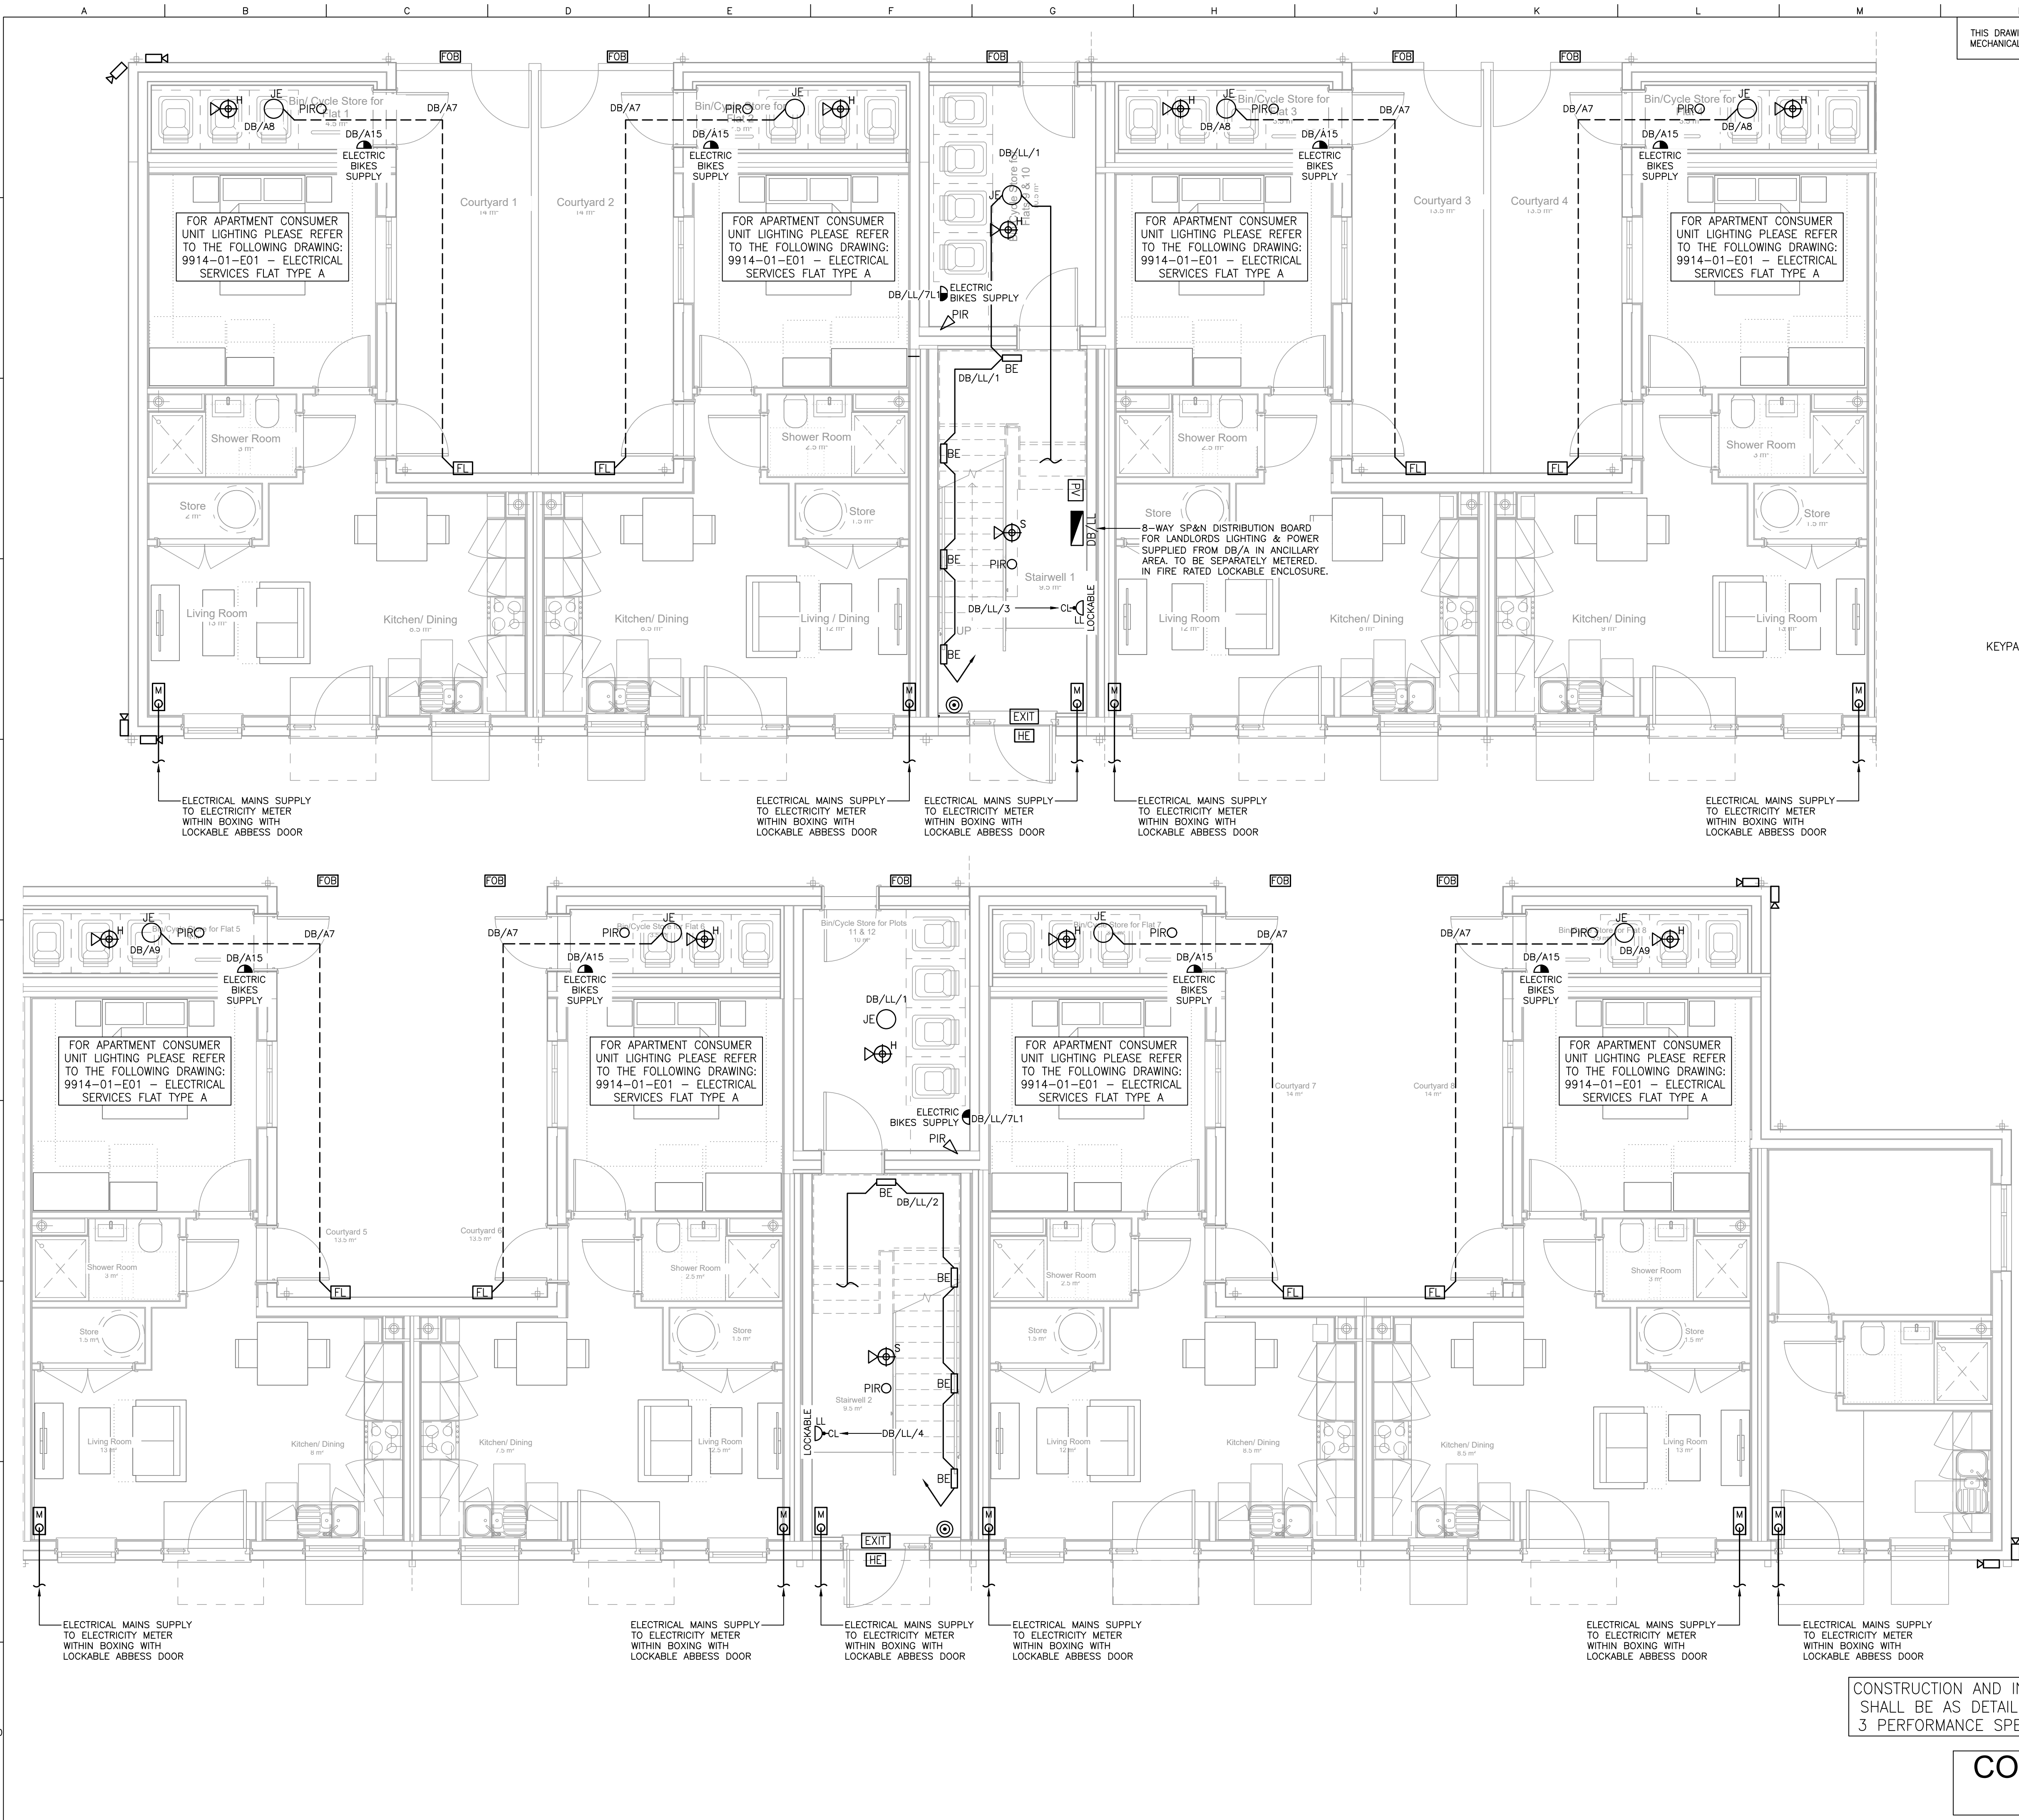

THIS DRAWING MUST BE READ IN CONJUNCTION WITH THE MECHANICAL AND ELECTRICAL SPECIFICATION.

- SMALL POWER LEGEND**

 - DOUBLE SWITCHED SOCKET OUTLET
 - SINGLE SWITCHED SOCKET OUTLET
 - CLEANERS SOCKET
 - SP&N ISOLATOR
 - SWITCHED FUSED CONNECTION UNIT
 - UNSWITCHED FUSED CONNECTION UNIT
 - TWIN DATA OUTLET
 - HOB & COOKER TIMED CONTROLLER
 - CONSUMER UNIT
 - COOKER SWITCH
 - DOUBLE SWITCHED SOCKET OUTLET WITH USB
 - TV AERIAL/COAX
 - SPN DISTRIBUTION BOARD
 - DOUBLE POLE ISOLATION SWITCHES FOR THE FOLLOWING EQUIPMENT:
 - COOKER
 - COOKER HOOD
 - FRIDGE/FREEZER
 - WASHING MACHINE/DRYER
 - HOB
- FIRE ALARM LEGEND**

 - HEAT DETECTOR WITH SOUNDER BASE
 - SMOKE DETECTOR WITH SOUNDER BASE
 - FIRE ALARM PANEL
 - MANUAL CALL POINT

LIGHTING LEGEND

 - LIGHT SWITCH
 - LIGHT SWITCH DENOTES NUMBER OF WAYS
 - KEY SWITCH
 - DIMMER LIGHT SWITCH

COMMUNICATIONS & SECURITY LEGEND

 - IDS PANEL
 - IDS KEYPAD
 - FOB ACCESS READER
 - PASSIVE INFRARED SENSOR
 - INTERCOM UNIT
 - CCTV CAMERA
- JCC - FIREGUARD - GU10 - IP20 DOWNLIGHT - WHITE (JC010010/WH) - C/W INTEGRAL LED - GU10 - PAR16 - DIMMABLE - 3.6W - 2700K (ILGU10DC109)**

JCC - RADIOLED RAPID EMERGENCY - SELF-TEST - 24W LED BULKHEAD - 4000K - IP65 WITH RIM (BODY: JC070156 + MODULE: JC070177ST)

JCC - EMERGENCY DOWNLIGHT - SELF-TEST - 2W - IP20 - 6000K - NON-MAINTAINED - OPEN/CORRIDOR LENSES (JC110007)

JCC - FIREGUARD - GU10 - IP65 DOWNLIGHT - WHITE (JC010016/WH) - C/W INTEGRAL LED - GU10 - PAR16 - DIMMABLE - 3.6W - 2700K (ILGU10DC109)

JCC - EMERGENCY BULKHEAD - SELF-TEST - 3W - IP65 - 6000K - NON-MAINTAINED - C/W LEGENDS (JC110005)

RADIOLED RAPID LED MODULE 24W 4000K MICROWAVE ON/OFF EMERGENCY SELF-TEST (BODY: JC070156 + MODULE: JC070181ST)

JCC RADIOLED RAPID IP65 12W LED - JC070076

JCC - RADIOLED RAPID EMERGENCY - SELF-TEST - 12W LED BULKHEAD - IP65 - MICROWAVE ON/OFF WITH RIM (BODY: JC070156 + MODULE: JC070159ST)

JCC - EMERGENCY BULKHEAD - SELF-TEST - 3W - IP65 - 6000K - NON-MAINTAINED - C/W LEGENDS (JC110005)

PIRO PASSIVE INFRARED SENSOR

PCO PHOTOCELL LIGHTING CONTROL

INDICATES EMERGENCY VERSION OF LUMINAIRE WITH 3-HOUR INTEGRAL BATTERY

ABBREVIATIONS

- BT - BRITISH TELECOM TELEPHONE POINT
- CV - CEILING VOID
- FDR - FIRE DOOR RELEASE
- HL - HIGH LEVEL
- LL - LOW LEVEL
- ML - MEDIUM LEVEL
- TR - TOWEL RAIL
- TV - TELEVISION
- WM - WASHING MACHINE
- DQ - DISHWASHER
- MO - MICROWAVE OVEN
- EH - EXTRACT HOOD
- FF - FRIDGE FREEZER
- DA - DISABLED ALARM
- DAP - DISABLED ALARM PANEL
- EVC - EMERGENCY VOICE COMMUNICATION PANEL
- IL - INDUCTION LOOP
- HRVU - HEAT RECOVERY VENTILATION UNIT
- MVHR - MECHANICAL HEAT RECOVERY UNIT
- DCF - DOOR CURTAIN FAN
- EF - EXTRACT FAN
- PRU - PRESSURISATION UNIT
- HB - HEATER BATTERY
- WBS - WATER BOOSTER SET
- WS - WATER SOFTENER
- OJ - OUTDOOR UNIT
- BCB - BC BOX
- CL - CLEANERS SOCKET
- FAP - FIRE ALARM PANEL
- HD - HAND DRYER
- ST - SENSOR TAP
- IDS - INTRUDER DETECTION SYSTEM
- WP - WEATHERPROOF

CONSTRUCTION AND INSTALLATION STANDARDS SHALL BE AS DETAILED IN THE RIBA STAGE 3 PERFORMANCE SPECIFICATION DOCUMENTS

CONSTRUCTION ISSUE

C3	CONSTRUCTION ISSUE	RD	LF	25/07/25	
C2	CONSTRUCTION ISSUE	RD	LF	25/10/24	
C1	CONTRACT ISSUE	RD	LF	30/08/24	
REV	DESCRIPTION	BY	CHKD	APP	DATE



KEATE HOUSE,
1 SCHOLAR GREEN ROAD,
COBRA COURT, TRAFFORD PARK
MANCHESTER, M32 0TR

Tel: 0161 848 9955
Fax: 0161 848 9966
E-mail: info@charlesandrews.co.uk
www.charlesandrews.co.uk

CA Filename: PROJECTS\9914\DRAWINGS\ELECTRICAL\E05		
Design: LF	CAD: RD	Checked: LF
Date: DEC 2023	Scale: 1:100@A1	
Project Title: HORNBY STREET STAGE 4/5		
Drawing Title: GROUND FLOOR ELECTRICAL SERVICES		
Drg. No: 9914-01-E05		Rev: C3