


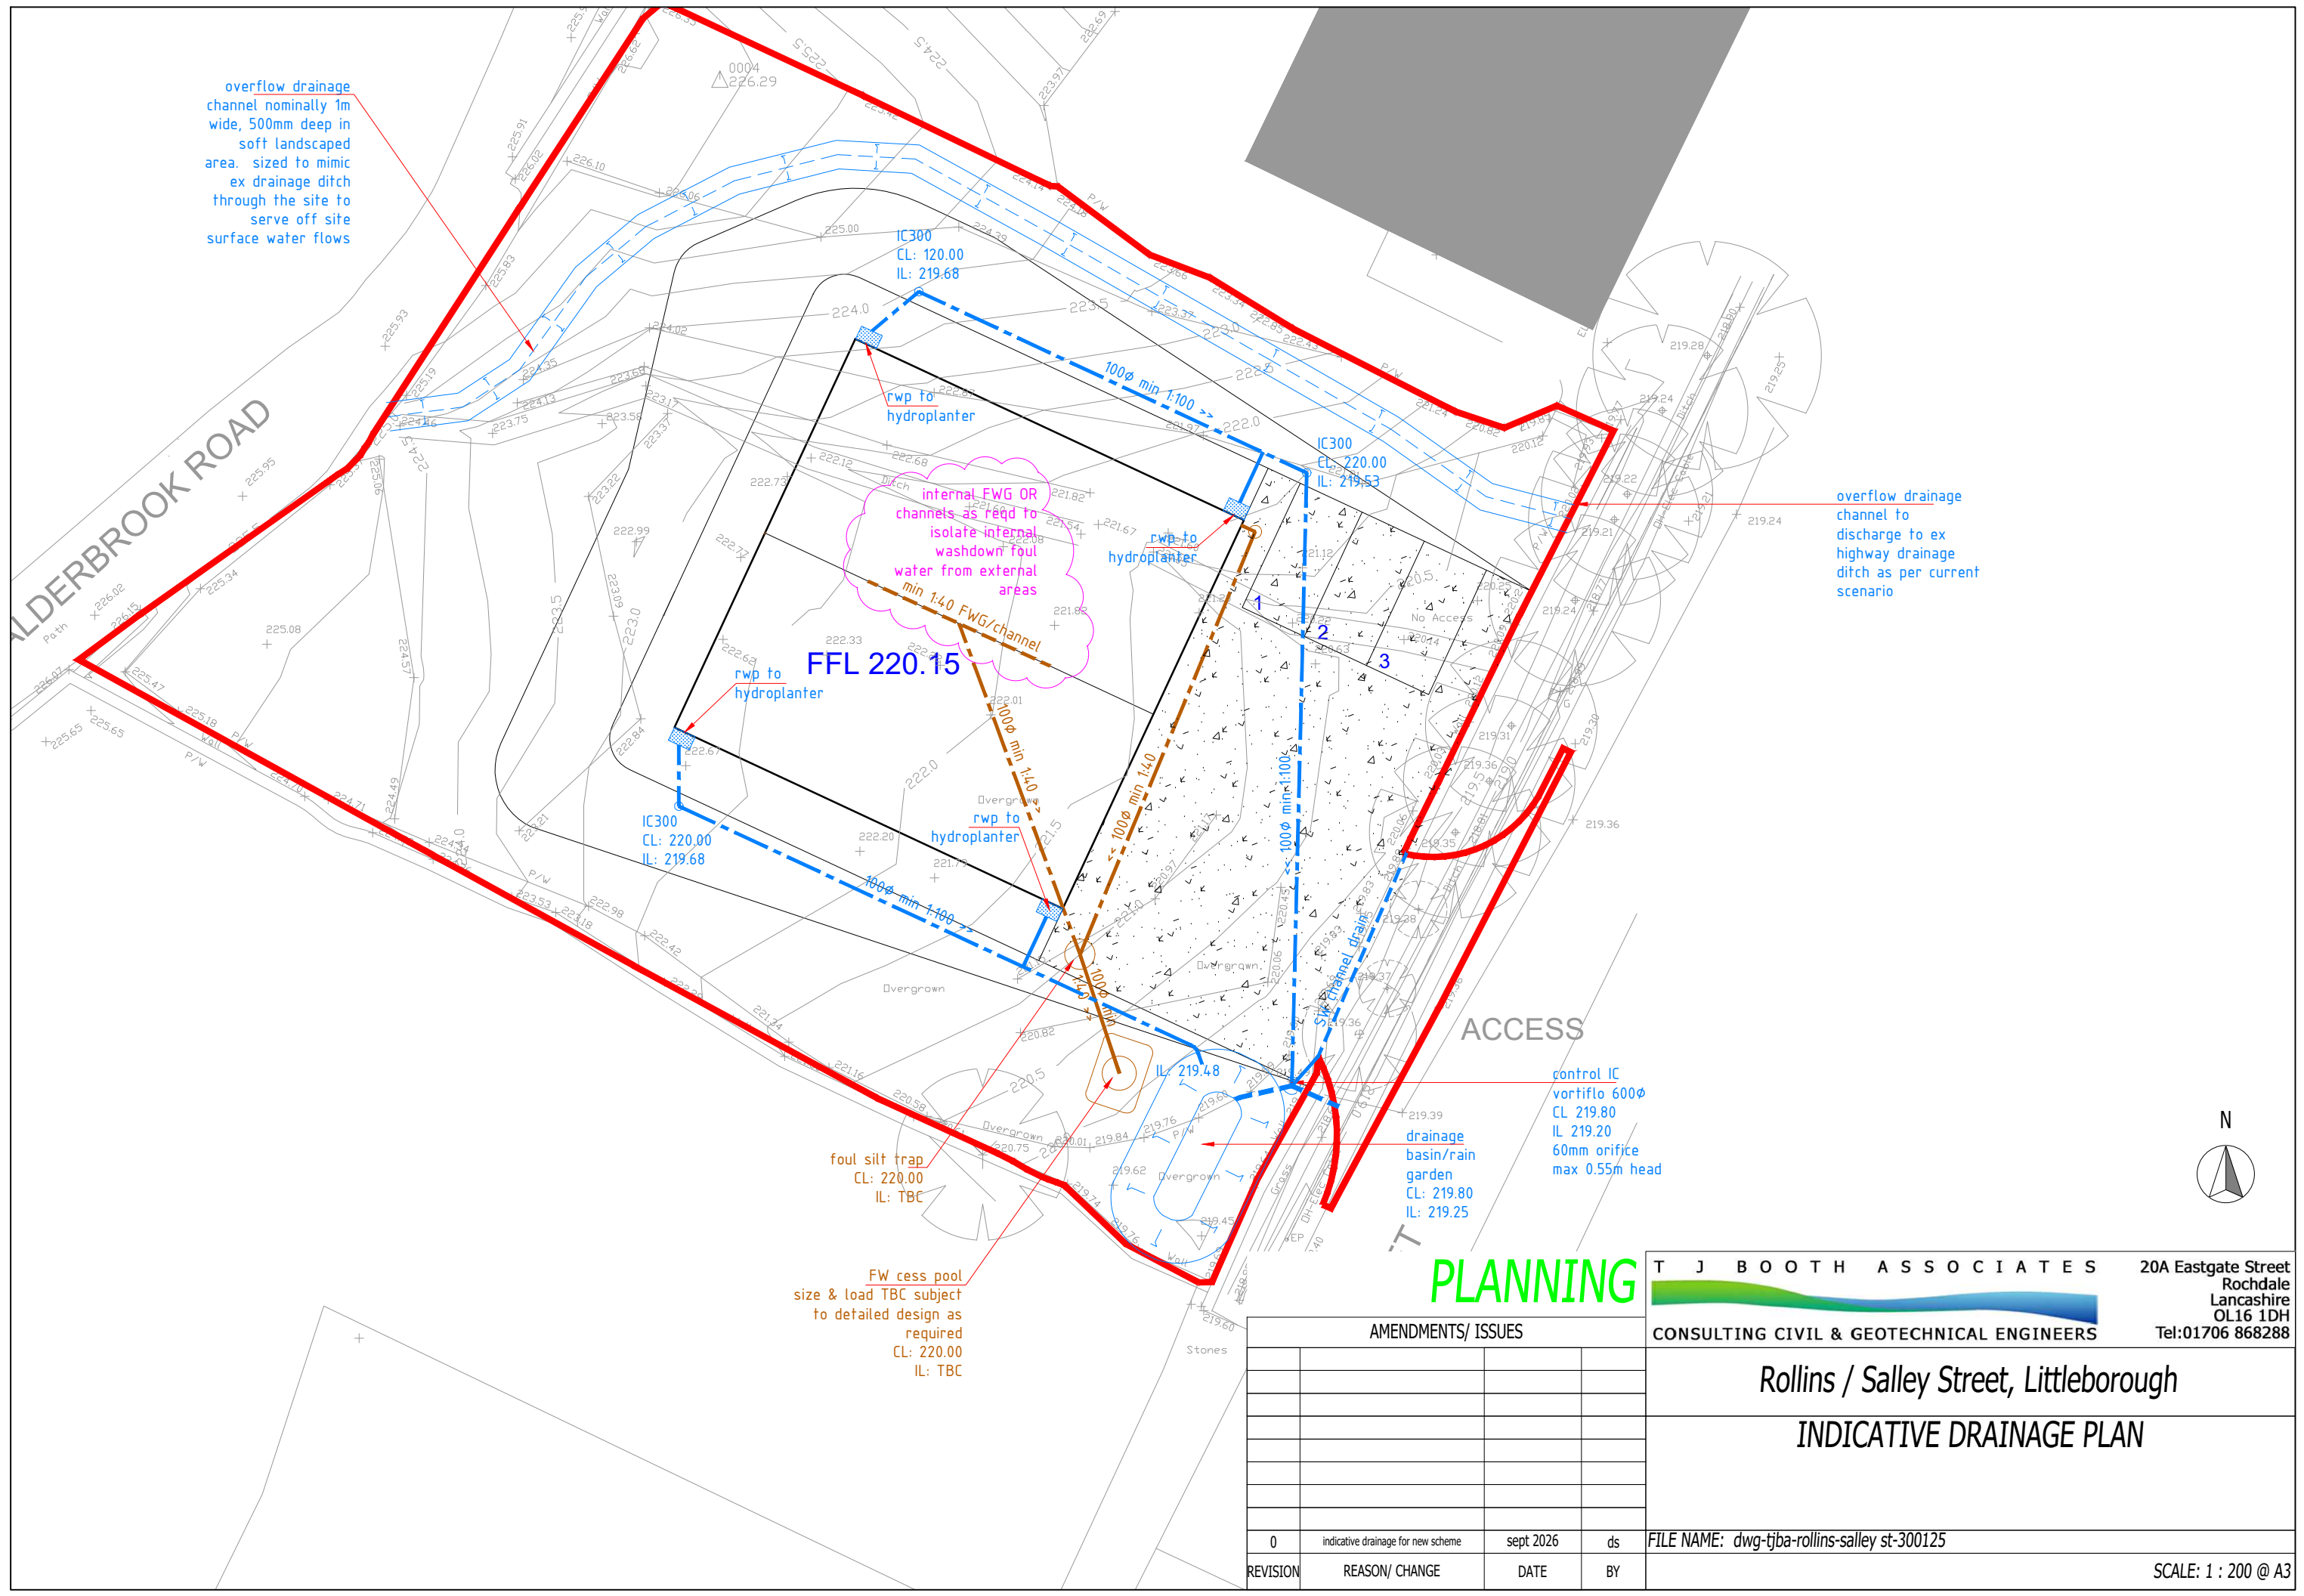

control IC
vortiflo 600φ
CL 219.80
IL 219.20
60mm orifice
max 0.55m head

T J B O O T H A S S O C I A T E S  CONSULTING CIVIL & GEOTECHNICAL ENGINEERS	20A Eastgate Street Rochdale Lancashire OL16 1DH Tel:01706 868288
---	--

AMENDMENTS/ ISSUES			
0	indicative drainage for new scheme	sept 2026	ds
REVISION	REASON/ CHANGE	DATE	BY

<i>Rollins / Salley Street, Littleborough</i> INDICATIVE DRAINAGE PLAN	
FILE NAME: dwg-tjba-rollins-salley st-300125	SCALE: 1 : 200 @ A3